

**PHILIPPINE
PORTS
AUTHORITY**




PORT MANAGEMENT OFFICE - MARINDUQUE/QUEZON

CONSTRUCTION DRAWINGS

**MAINTENANCE OF RRTF FACILITIES
AT GATES 2 AND 4**

PORT OF LUCENA

LUCENA CITY


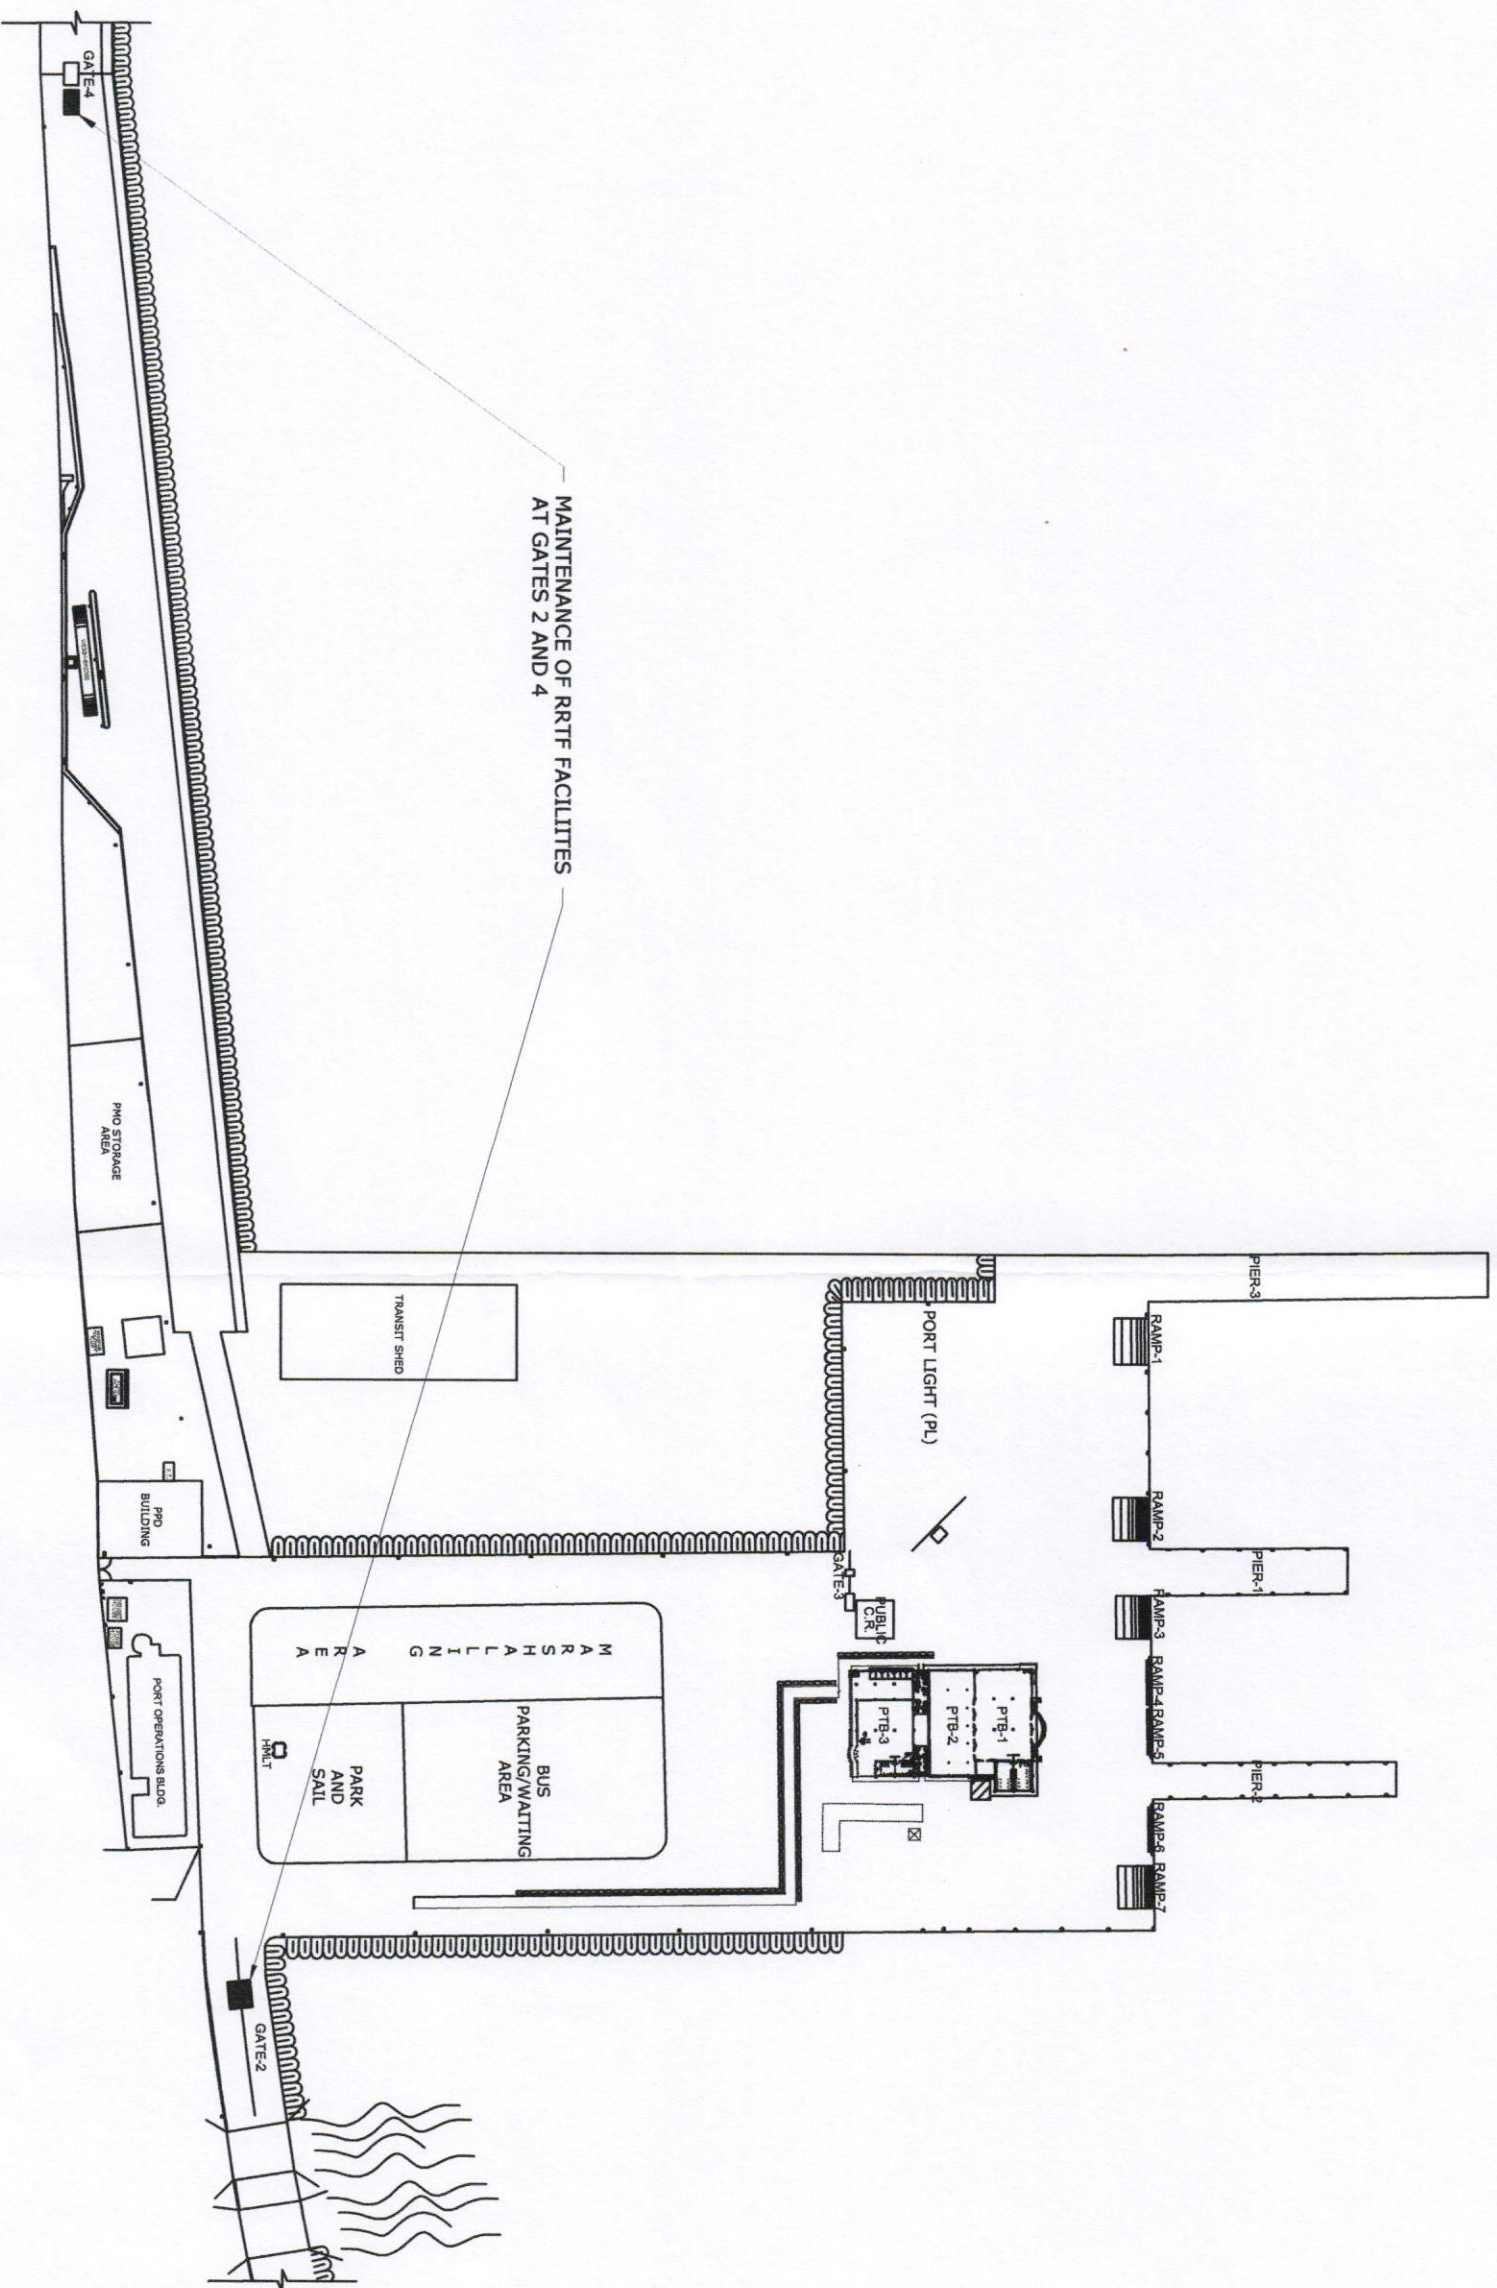


DEVELOPMENT PLAN


SCALE

1:2000


PHILIPPINE PORTS AUTHORITY  PORT MANAGEMENT OFFICE - MARQUEZ	PROJECT/LOCATION: MAINTENANCE OF RRTF FACILITIES AT GATES 2 AND 4 PORT OF LUCENA LUCENA CITY	PREPARED BY: MARK ANDREW S. PIÑEDA ACTING SUPERVISING ENGINEER A	CHECKED/REVIEWED BY: GERILIE D. TABOCO PRINCIPAL ENGINEER A	RECOMMENDED BY: PAULA A. LIBATIQUE ESD MANAGER	APPROVED BY: ANNA THERESA M. BISCOCHO ACTING PORT MANAGER	SHEET CONTENT: • DEVELOPMENT PLAN 1 / 7
---	---	--	---	--	---	--

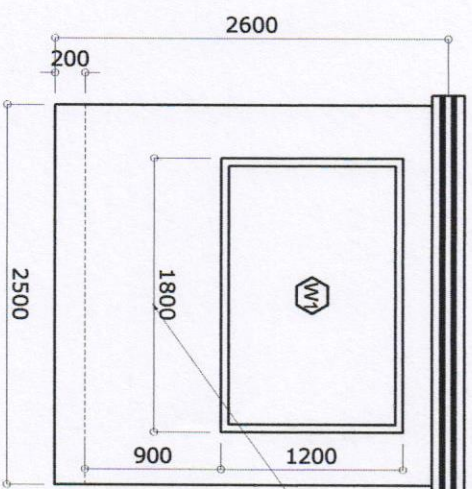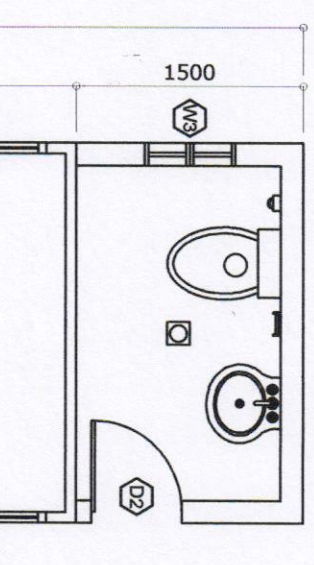

FRONT ELEVATION
SCALE 1:50

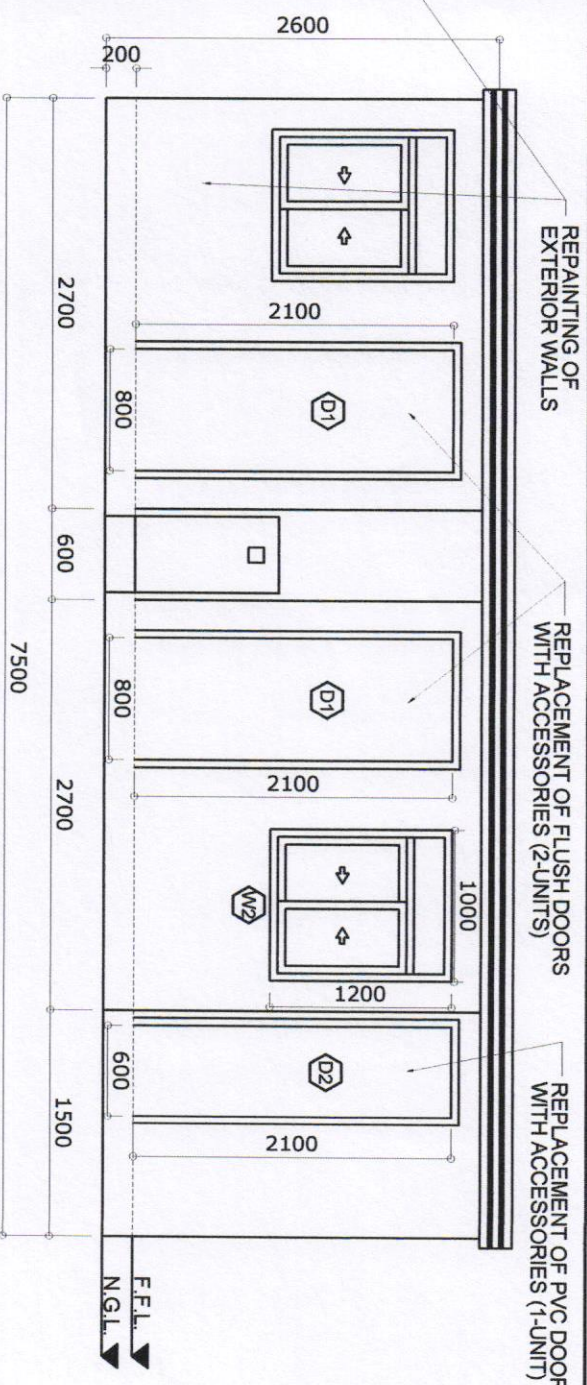


RIGHT SIDE ELEVATION
SCALE 1:50

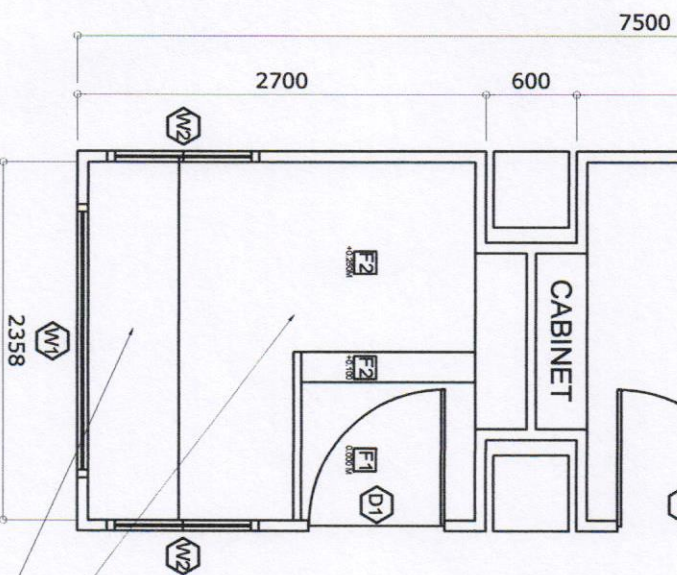


PLAN
SCALE 1:50

REAR ELEVATION
SCALE 1:50

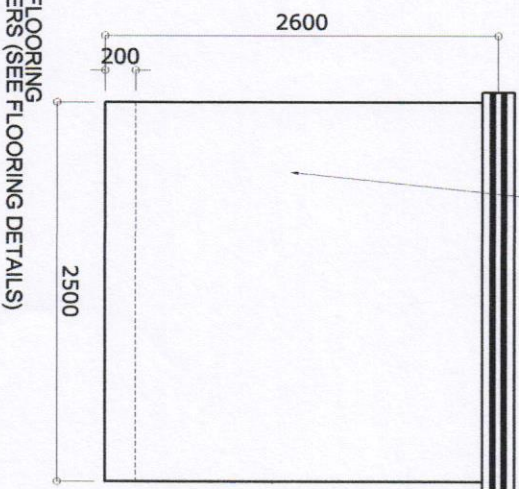


LEFT SIDE ELEVATION
SCALE 1:50

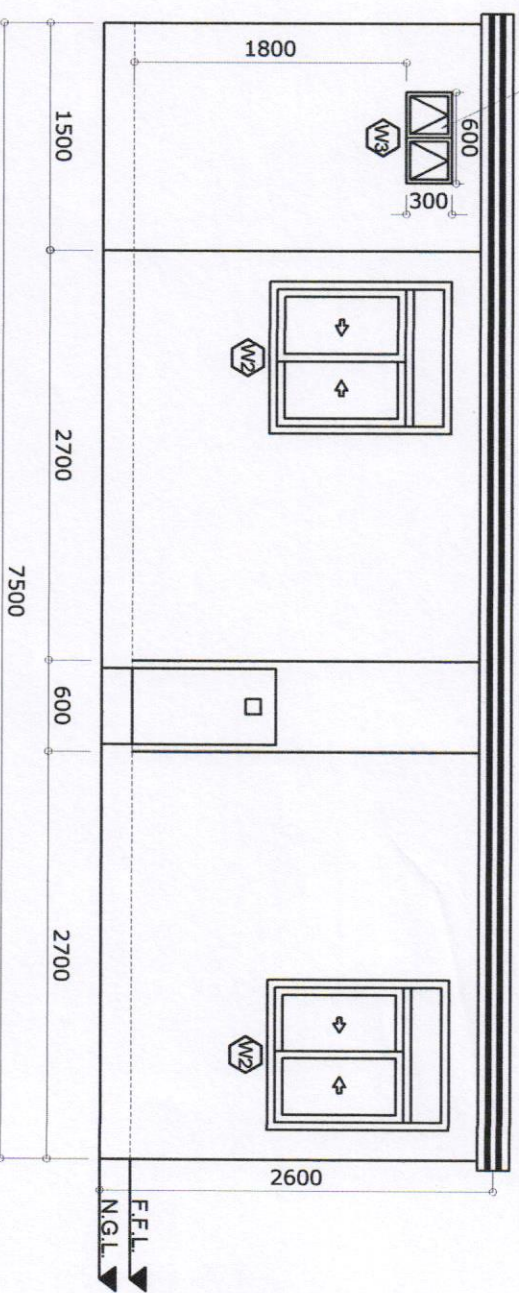


* TOP COAT COLOR TO BE APPROVED BY PMO

PHILIPPINE PORTS AUTHORITY PORT MANAGEMENT OFFICE - MARQUEZ	PROJECT/LOCATION: MAINTENANCE OF RRTF FACILITIES AT GATES 2 AND 4 LUCENA CITY	PREPARED BY: MARK ANDREW S. PIÑEDA ACTING SUPERVISING ENGINEER A	CHECKED/REVIEWED BY: GERLIE D. TABOCO PRINCIPAL ENGINEER A	RECOMMENDED BY: RAUL A. LIBATIQUE ESD MANAGER	APPROVED BY: ANNA THERESA M. BISCOCHO ACTING PORT MANAGER	SHEET CONTENT: ● PLAN ● FRONT ELEVATION ● REAR ELEVATION ● LEFT SIDE ELEVATION ● RIGHT SIDE ELEVATION 217
---	---	--	--	---	---	---

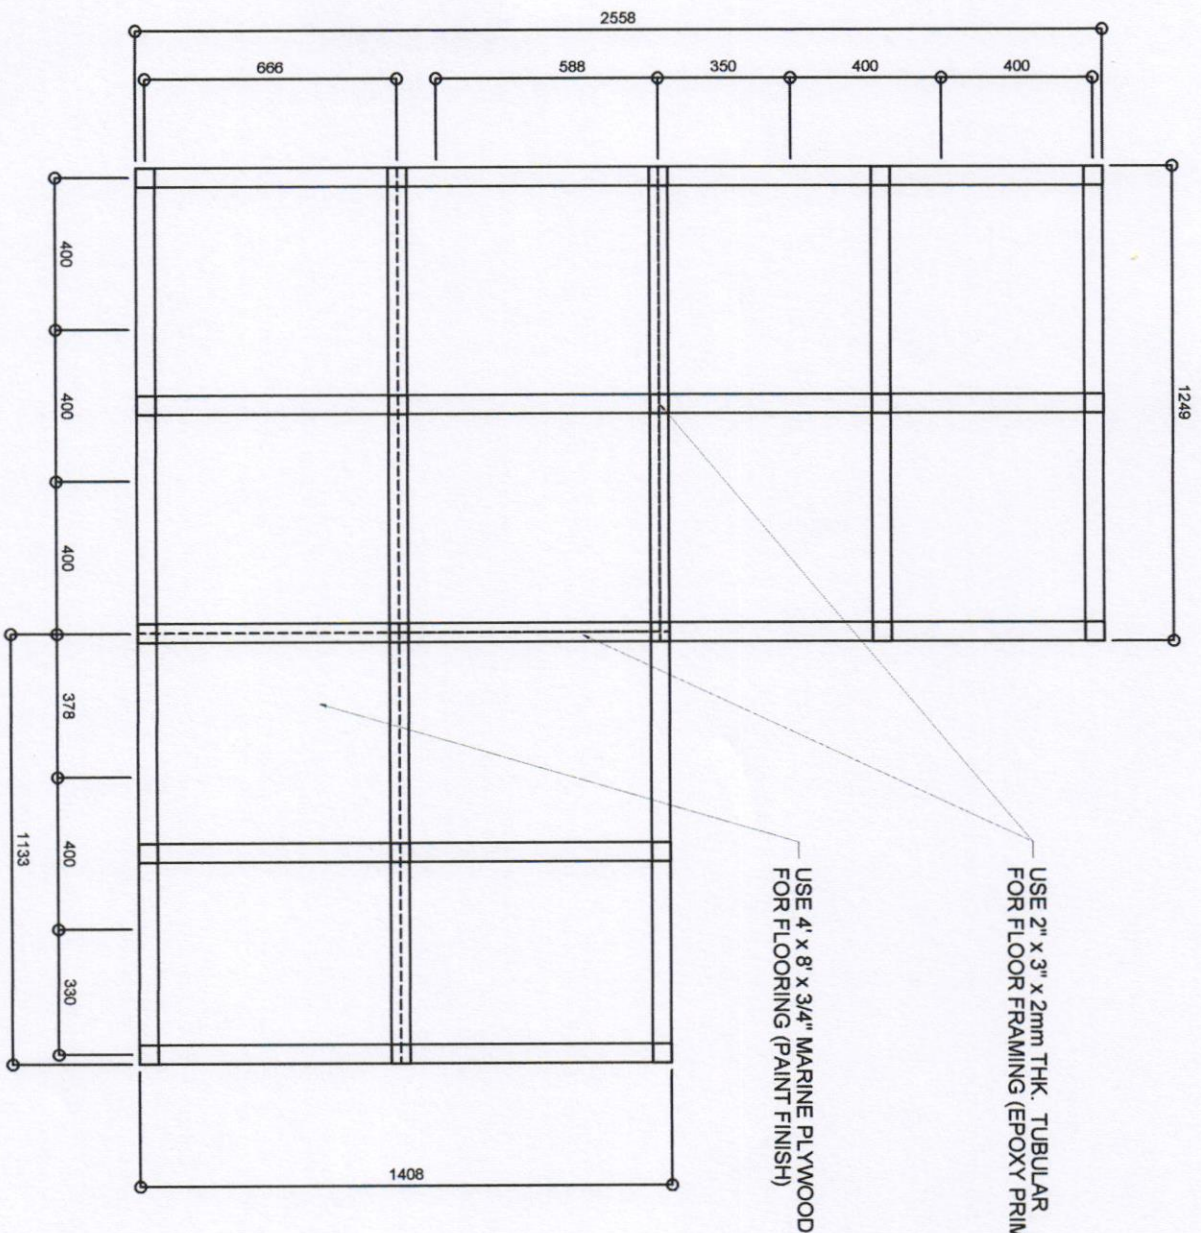

FLOOR FRAMING PLAN
SCALE 1:20

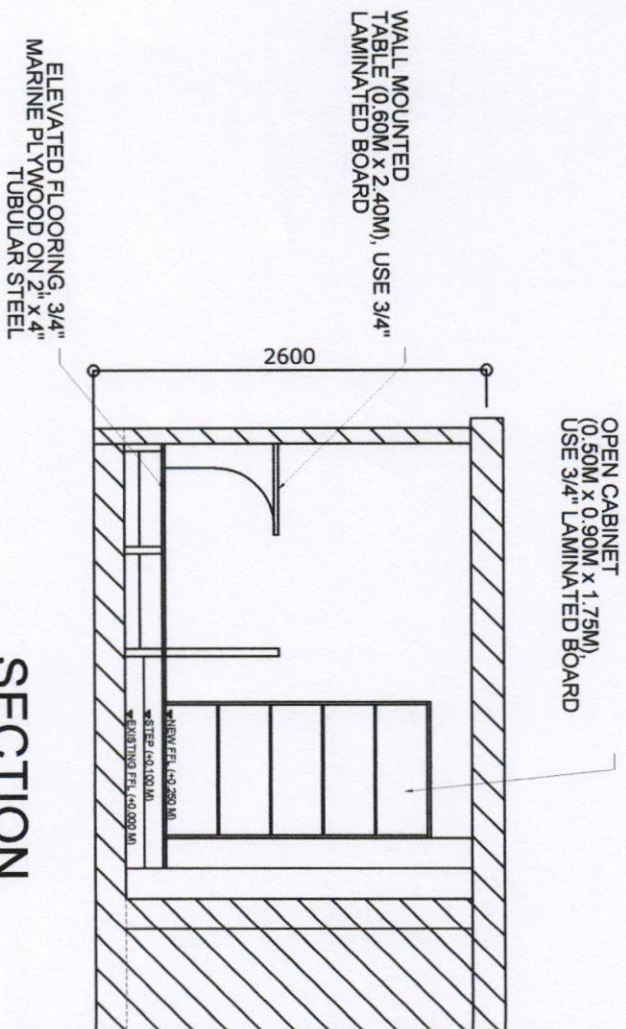


SECTION
SCALE 1:50

TYPE: MARINE PLYWOOD LOCATION: FINISH FLUSH DOOR SET: RRTF, PPA & MPTI TWO (2)	TYPE: MARINE PLYWOOD LOCATION: FINISH FLUSH DOOR SET: RRTF, C.R. ONE (1)	TYPE: 1.5 mm THK. ALUMINUM FRAMED LOCATION: SLIDING TYPE WINDOW-POWDER COATED SET: RRTF, MPTI ONE (1)
---	---	--

SCHEDULE OF DOORS AND WINDOW
SCALE 1:50

PROJECT/LOCATION:		PREPARED BY:		CHECKED/REVIEWED BY:		RECOMMENDED BY:		APPROVED BY:		SHEET CONTENT:	
PHILIPPINE PORTS AUTHORITY		MAINTENANCE OF RRTF FACILITIES AT GATES 2 AND 4		MARK ANDREW S. PIÑEDA ACTING SUPERVISING ENGINEER A		GERLIE D. TABOCO PRINCIPAL ENGINEER A		RAUL A. LIBATIQUE ESD MANAGER		ANNA THERESA M. BISCOCHO ACTING PORT MANAGER	
PORT MANAGEMENT OFFICE - MARQUEZ		PORT OF LUCENA		LUCENA CITY						● FLOOR FRAMING PLAN ● SECTION ● SCHEDULE OF DOORS AND WINDOWS	
										3 / 7	

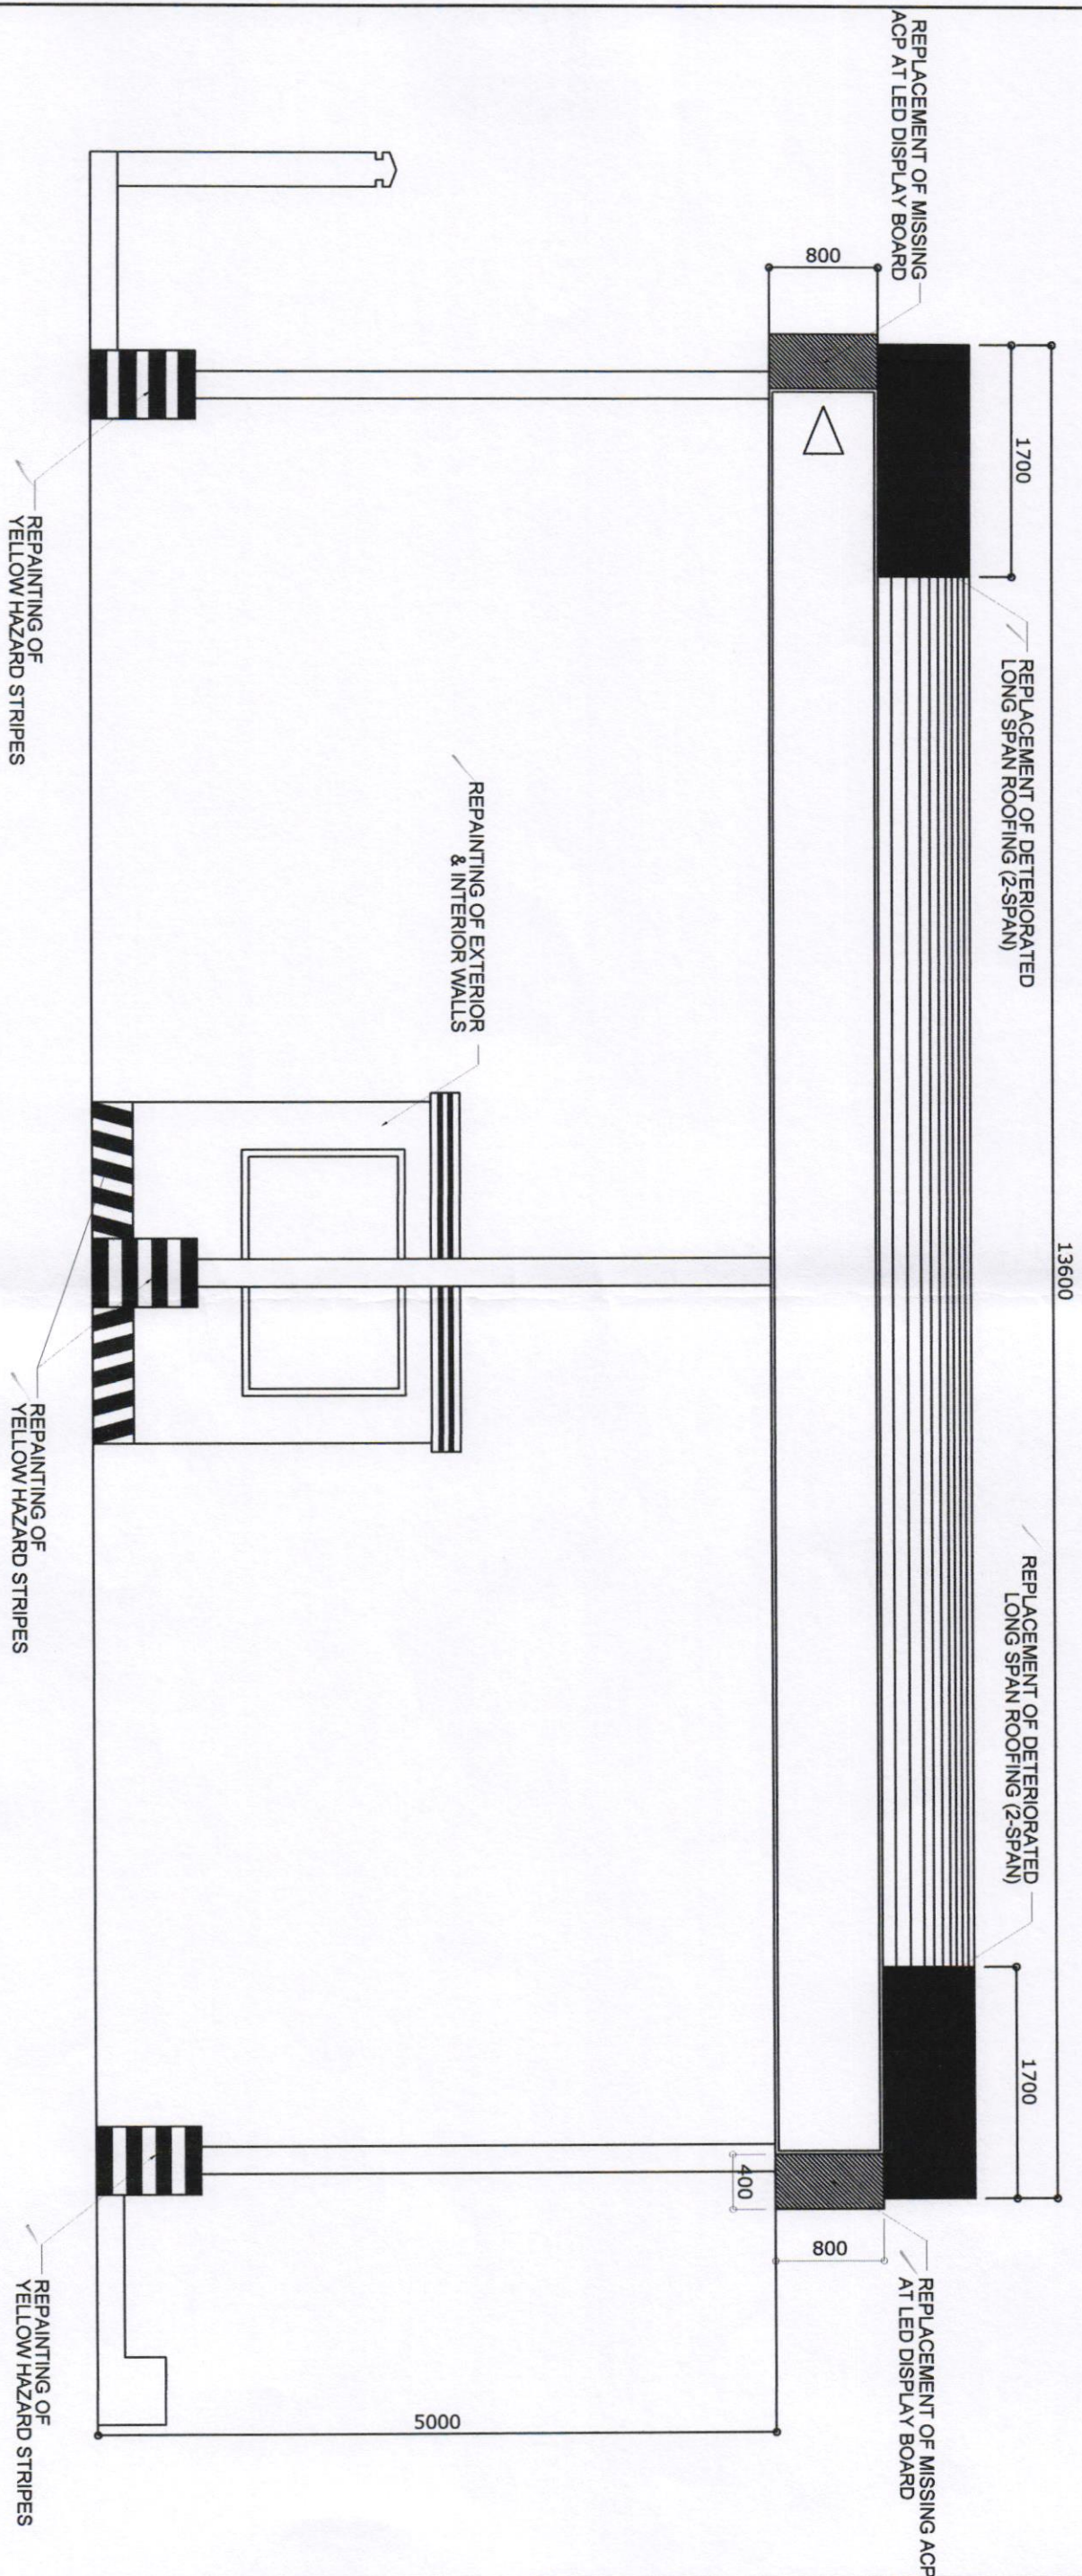

FRONT ELEVATION

SCALE 1:50

PROJECT/LOCATION:

PREPARED BY:

CHECKED/REVIEWED BY:

RECOMMENDED BY:

APPROVED BY:

SHEET CONTENT:

PHILIPPINE
PORTS
AUTHORITY

MAINTENANCE OF RRTF
FACILITIES AT GATES 2 AND 4

PORT OF LUCENA

LUCENA CITY

MARK ANDREW S. PIÑEDA
ACTING SUPERVISING ENGINEER A


GERLIE D. TABOCO
PRINCIPAL ENGINEER A

RAUL A. LIBATIQUE
ESD MANAGER

ANNA TURTOS M. BISCOCHO
ACTING PORT MANAGER

FRONT ELEVATION OF
RRTF AT GATE 2


4 / 7

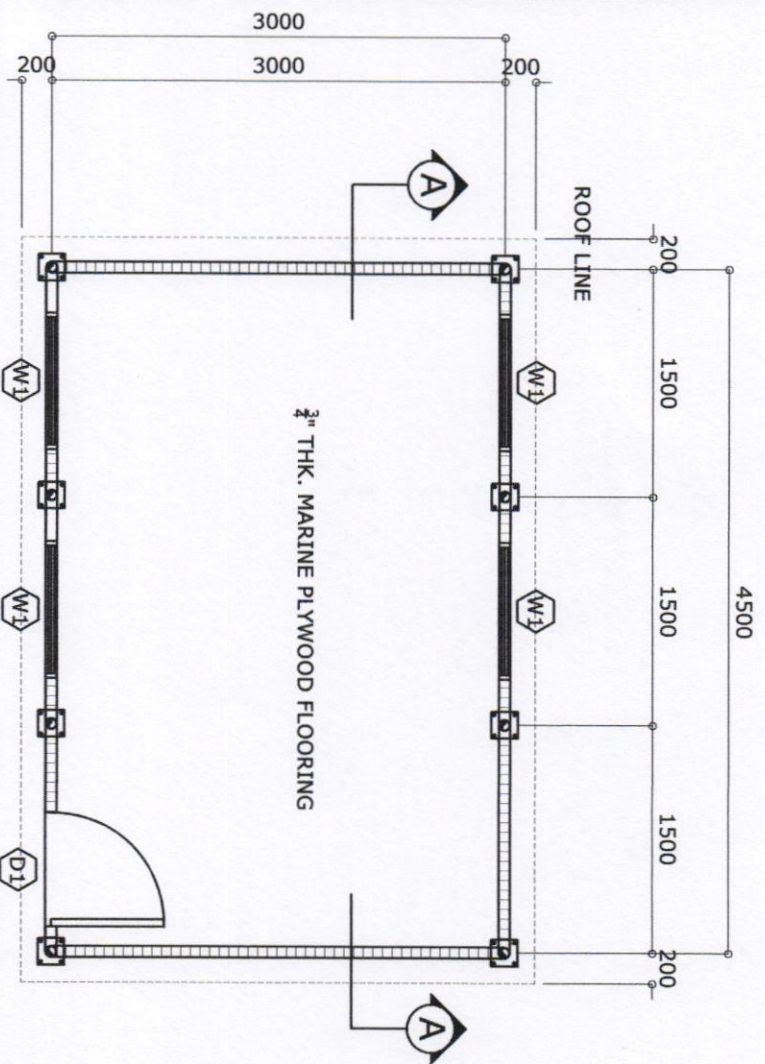

FLOOR PLAN OF RRTF FACILITY @GATE 4

SCALE


1:50

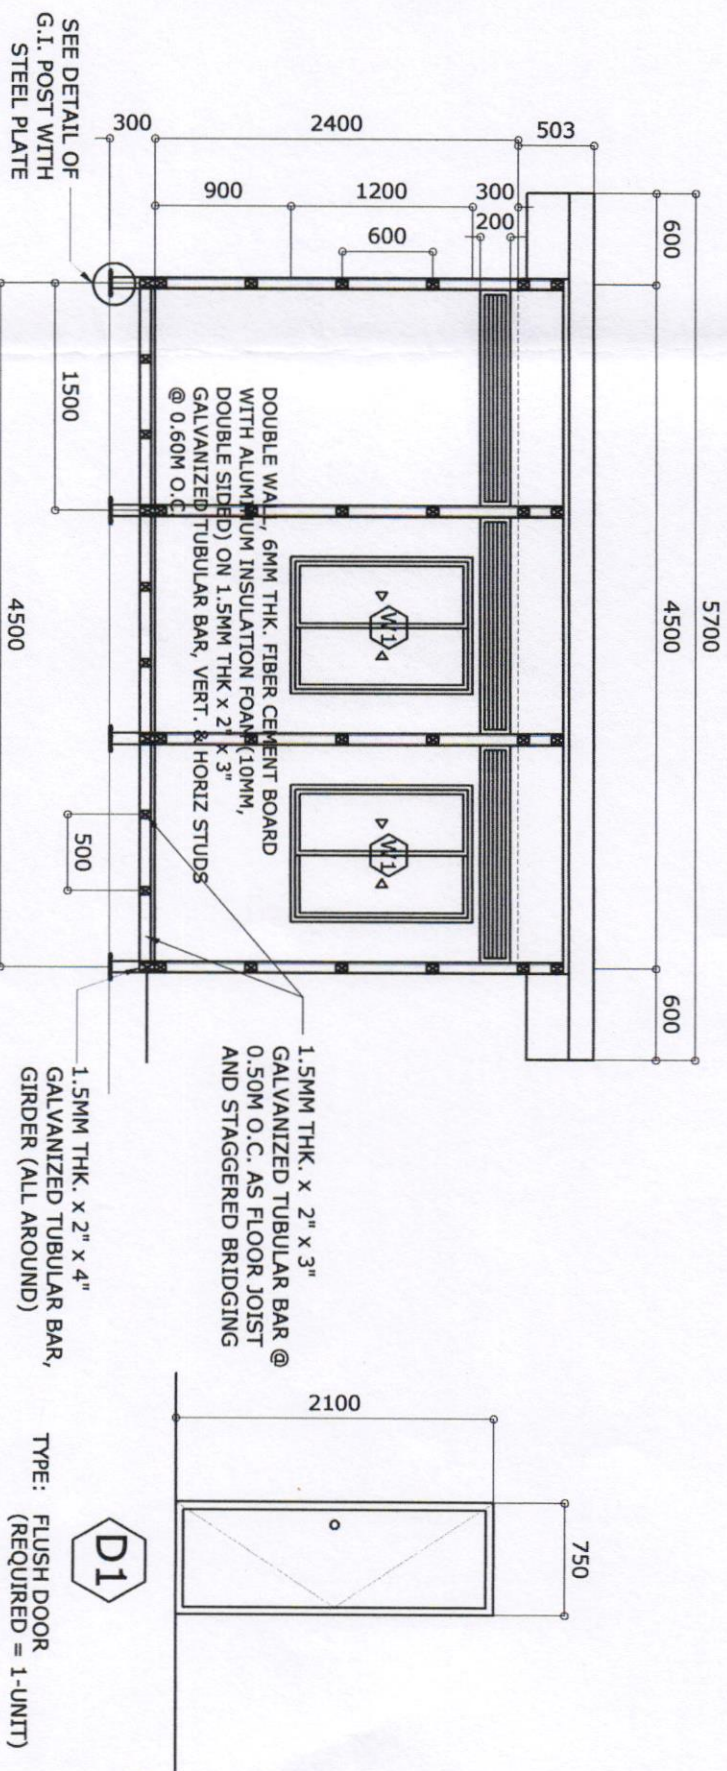

FRONT ELEVATION

SCALE


1:50

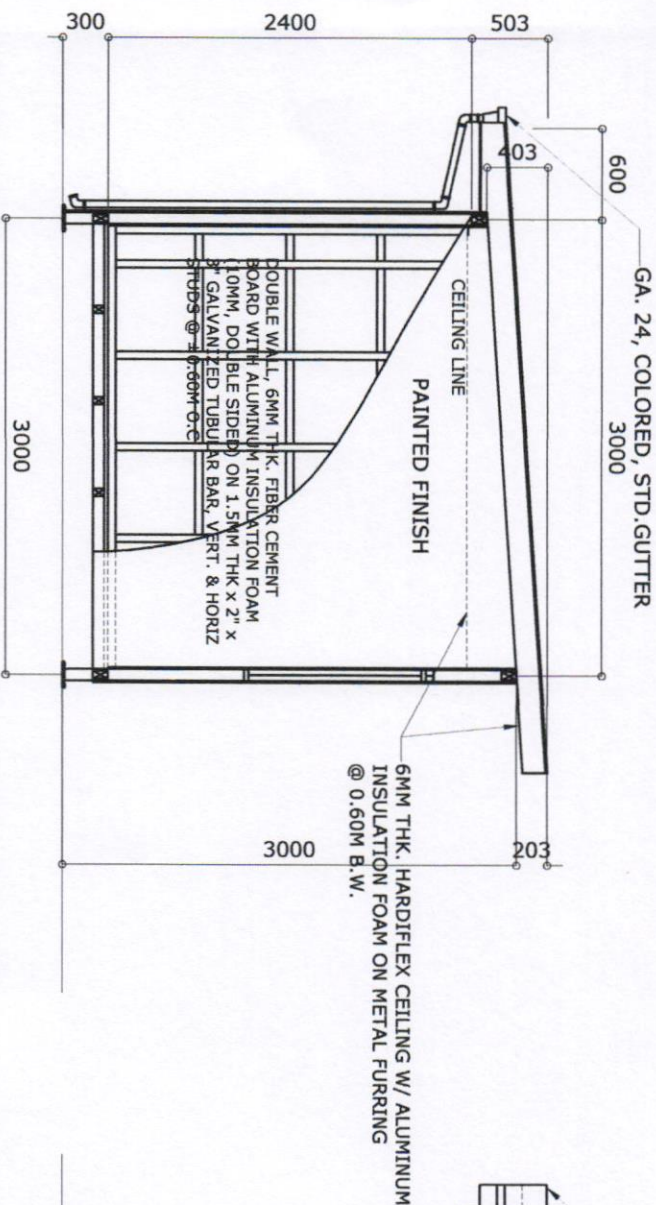

TYP. SIDE ELEVATION & DETAILS

SCALE


1:50

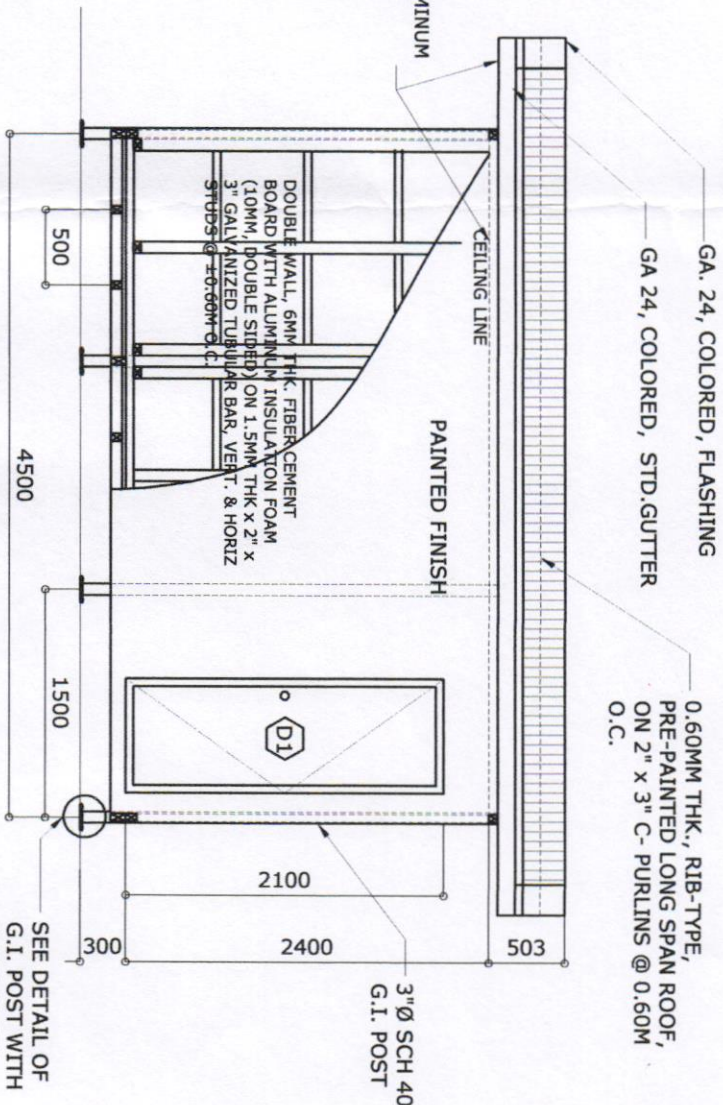

REAR ELEVATION

SCALE

1:50

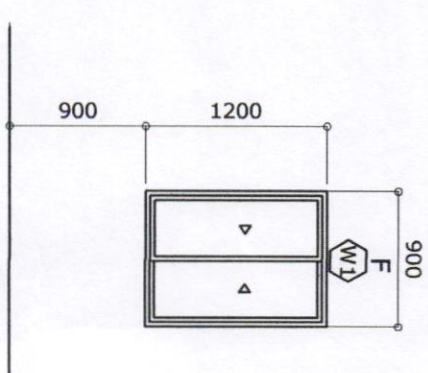


SCHEDULE OF DOOR & WINDOWS


SCALE

1:50

PHILIPPINE PORTS AUTHORITY PORT MANAGEMENT OFFICE - MARQUEZ	PROJECT/LOCATION: MAINTENANCE OF RRTF FACILITIES AT GATES 2 AND 4 PORT OF LUCENA	PREPARED BY: MARK ANDREW S. PINEDA ACTING SUPERVISING ENGINEER A	CHECKED/REVIEWED BY: GERLIE D. TABOCO PRINCIPAL ENGINEER A	RECOMMENDED BY: RAUL A. LIBATIQUE EST. MANAGER	APPROVED BY: ANNA THERESA M. BISCOCHO ACTING PORT MANAGER	SHEET CONTENT: FLOOR PLAN OF RRTF FACILITY TYPICAL SIDE ELEVATION & DETAILS REAR ELEVATION SCHEDULE OF DOORS & WINDOWS 5 / 7
---	---	---	---	---	--	--

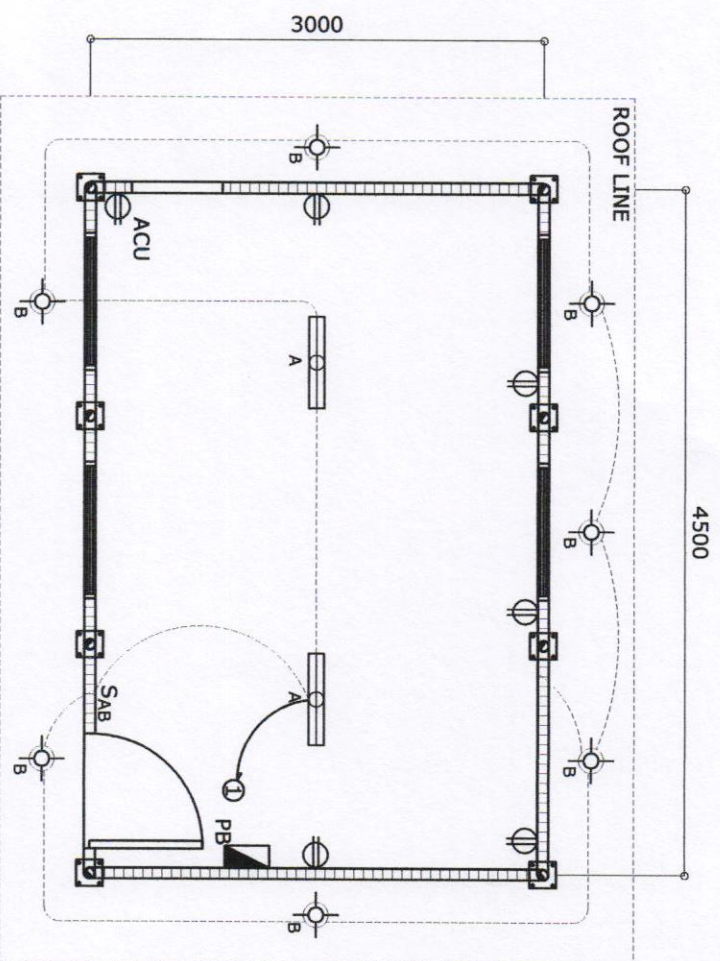

LIGHTING LAYOUT
SCALE 1:50

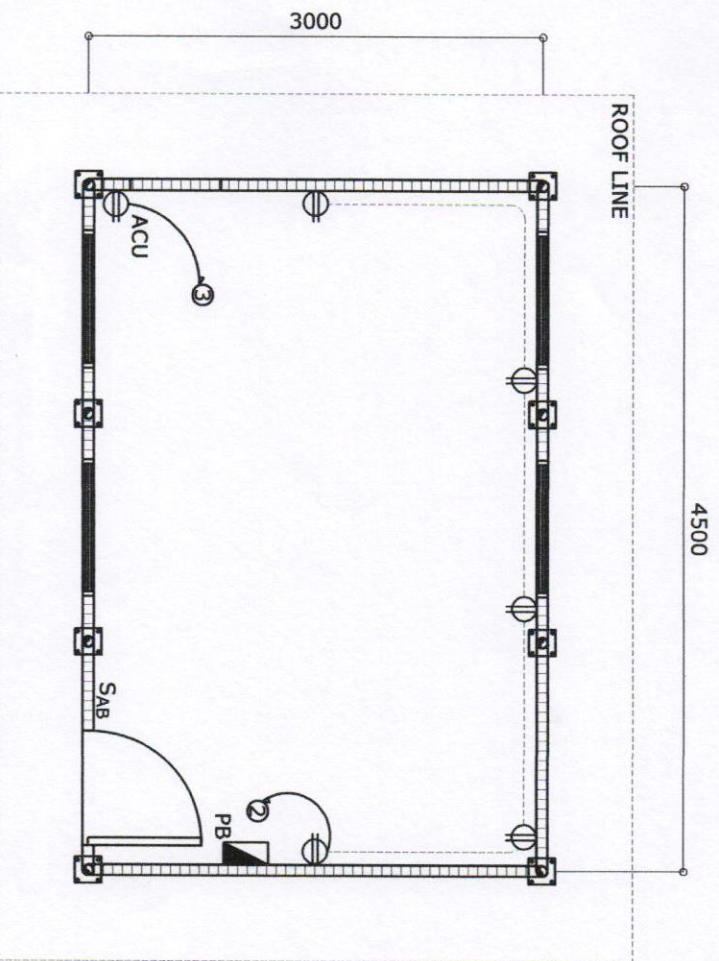


POWER LAYOUT
SCALE 1:50

LEGEND:

- NEMA ELECTRICAL PANEL BOARD WITH MAIN 40A CB, 2P, 230V, 1-30A, 230V, 2P; 3-20A, 230V, 2P
- ACU OUTLET
- ONE GANG SWITCH
- TWO GANG SWITCH
- CIRCUIT BREAKER BOLT-ON TYPE
- DUPLEX CONVENIENCE OUTLET (WEATHERPROOF)
- 18 WATTS LED BULB
- 40 WATTS FLUORESCENT LAMP (BOX TYPE)

LOAD SCHEDULE:

	QTY	W	V	A	PROTECTION	WIRE
1	LO	9	230	3.91	20A, 230V, 2P	2-3.5MM ² THHN STANDED WIRE
2	CO	5	230	4.38	20A, 230V, 2P	2-3.5MM ² THHN STANDED WIRE
3	ACU	1	230	3.24	30A, 230V, 2P	2-3.5MM ² THHN STANDED WIRE
4	SPARE	-	230	-	20A, 230V, 2P	-
		2,646	230	11.53		

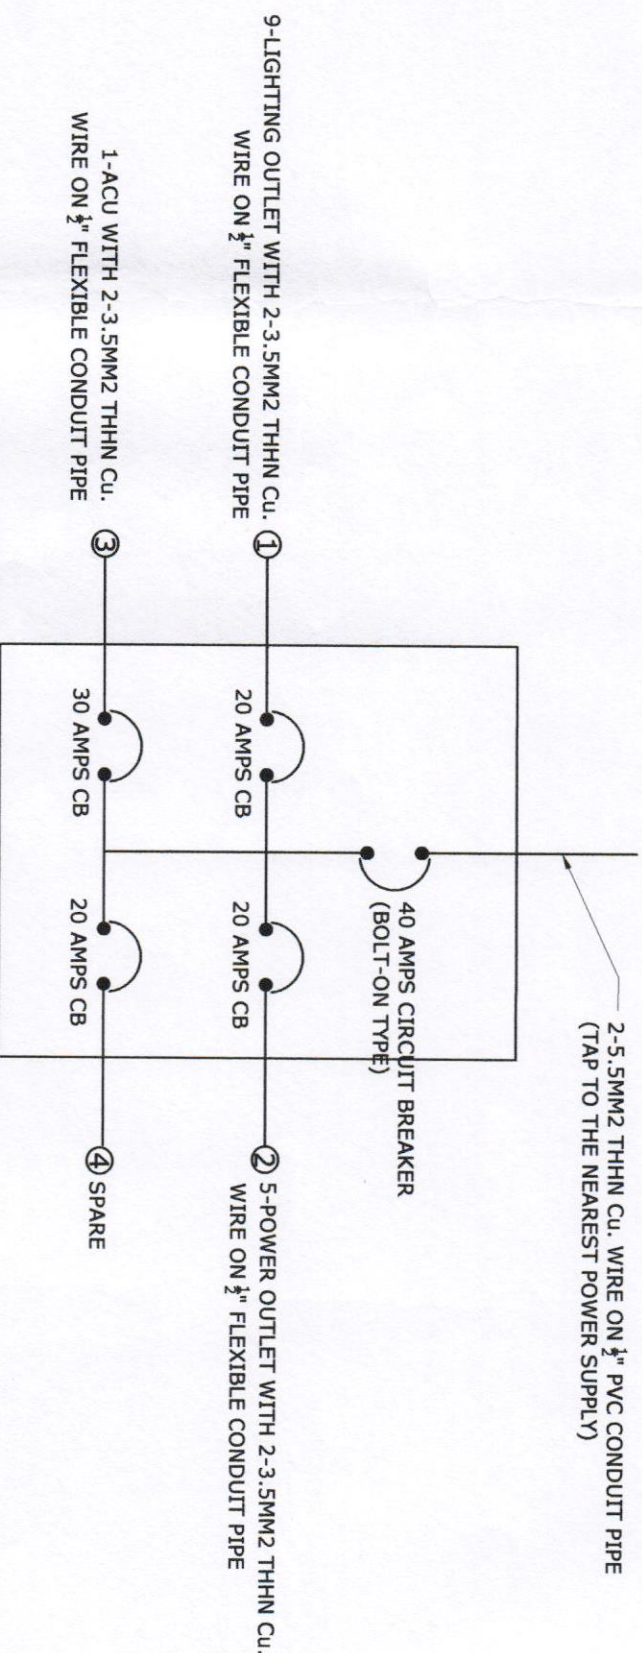

PANEL BOARD DIAGRAM

PROJECT/LOCATION:

SCALE 1:50

PREPARED BY:

CHECKED/REVIEWED BY:

RECOMMENDED BY:

APPROVED BY:

SHEET CONTENT:



PORT MANAGEMENT OFFICE - MARQUEZ

MAINTENANCE OF RRTF
FACILITIES AT GATES 2 AND 4

MARK ANDREW S. PIÑEDA
ACTING SUPERVISING ENGINEER A

GERLIE D. TABOCO
PRINCIPAL ENGINEER A

RAUL A. LIBATIQUE
ESD MANAGER

ANNA THOMAS M. BISCOCHO
ACTING PORT MANAGER

7 / 7