

**PHILIPPINE
PORTS
AUTHORITY**



PORT MANAGEMENT OFFICE - MARINDUQUE/AQUEZON

CONSTRUCTION DRAWINGS


**MAINTENANCE OF FACILITIES AT PTB-1,
PERIMETER WALL AND DRAINAGE COVER**

PORT OF BALANACAN

MARINDUQUE



VICINITY MAP
NOT TO SCALE

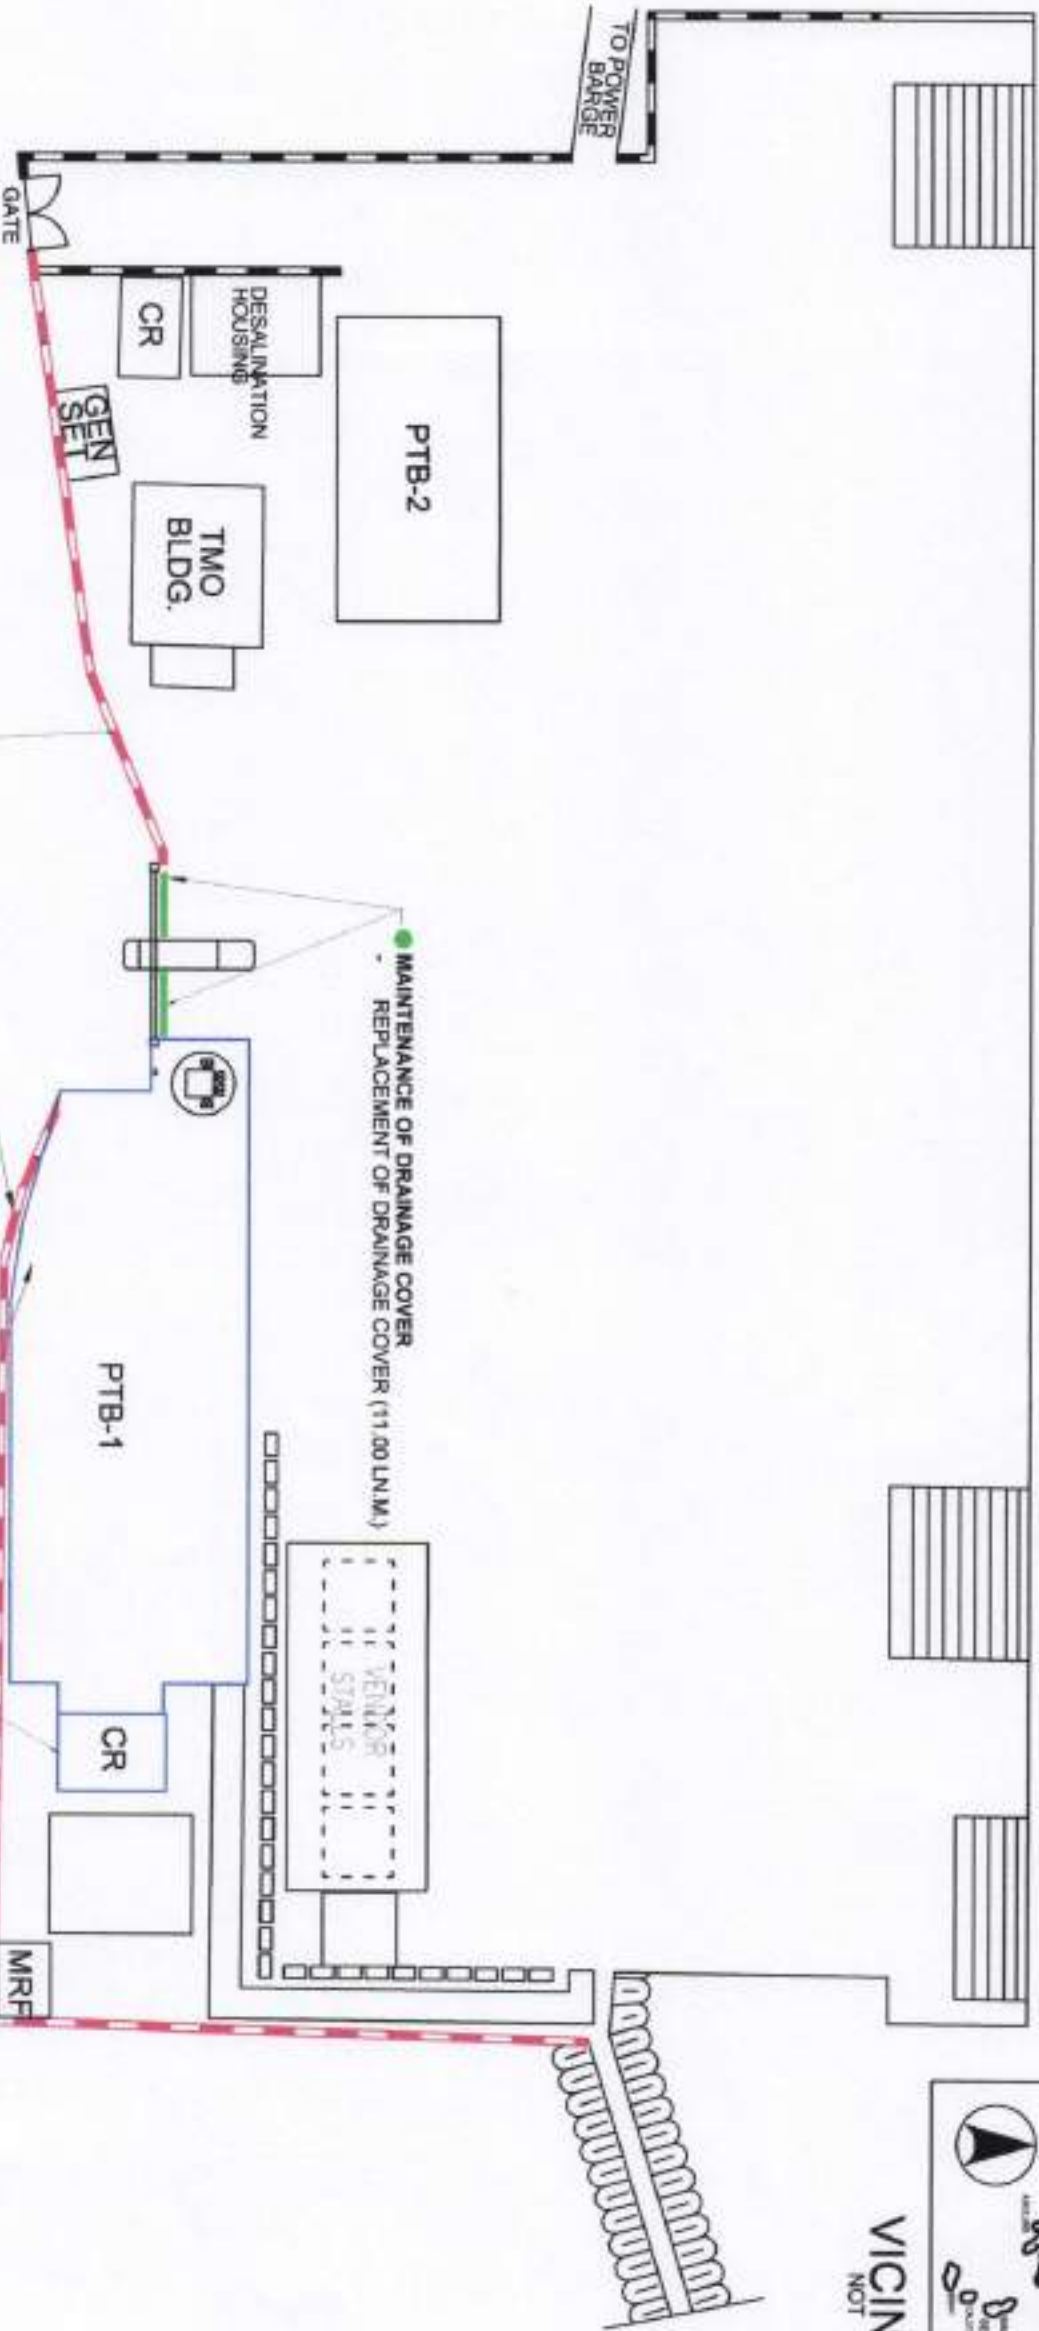


● MAINTENANCE OF PERIMETER WALL
- GAP FILLING AND PLASTERING OF PERIMETER WALL
- REPAINTING OF PERIMETER WALL AND STEEL FENCE

● MAINTENANCE OF DRAINAGE COVER
- REPLACEMENT OF DRAINAGE COVER (11.00 LN.M.)



● MAINTENANCE OF FACILITIES AT PTB-1
- MAINTENANCE OF ELECTRICAL AND TICKETING ROOM
- MAINTENANCE OF COMFORT ROOMS
- REPLACEMENT OF CEILING


DEVELOPMENT PLAN

SCALE 1:500

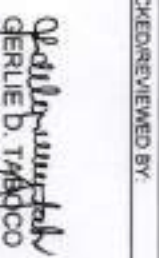 PHILIPPINE PORTS AUTHORITY PORT MANAGEMENT OFFICE - MARQUEZ	PROJECT LOCATION: MAINTENANCE OF FACILITIES AT PTB-1 PERIMETER WALL AND DRAINAGE COVER PORT OF BALANACAN MARINDUQUE	PREPARED BY:  MARK ANDRIANTS, PINEDA ACTING SUPERVISING ENGINEER A	CHECKED/REVIEWED BY:  GERLIE D. TABORCO PRINCIPAL ENGINEER A	RECOMMENDED BY:  RAULA LIBATIQUE ESD MANAGER	APPROVED BY:  ANNA T. BISCOCHO ACTING PORT MANAGER	SHEET CONTENT: DEVELOPMENT PLAN 1 / 8
---	---	---	---	---	---	--

SCHEDULE OF DOOR

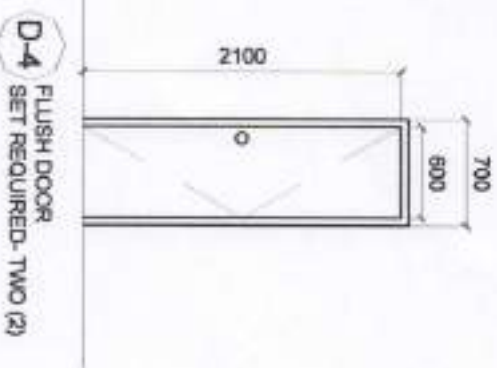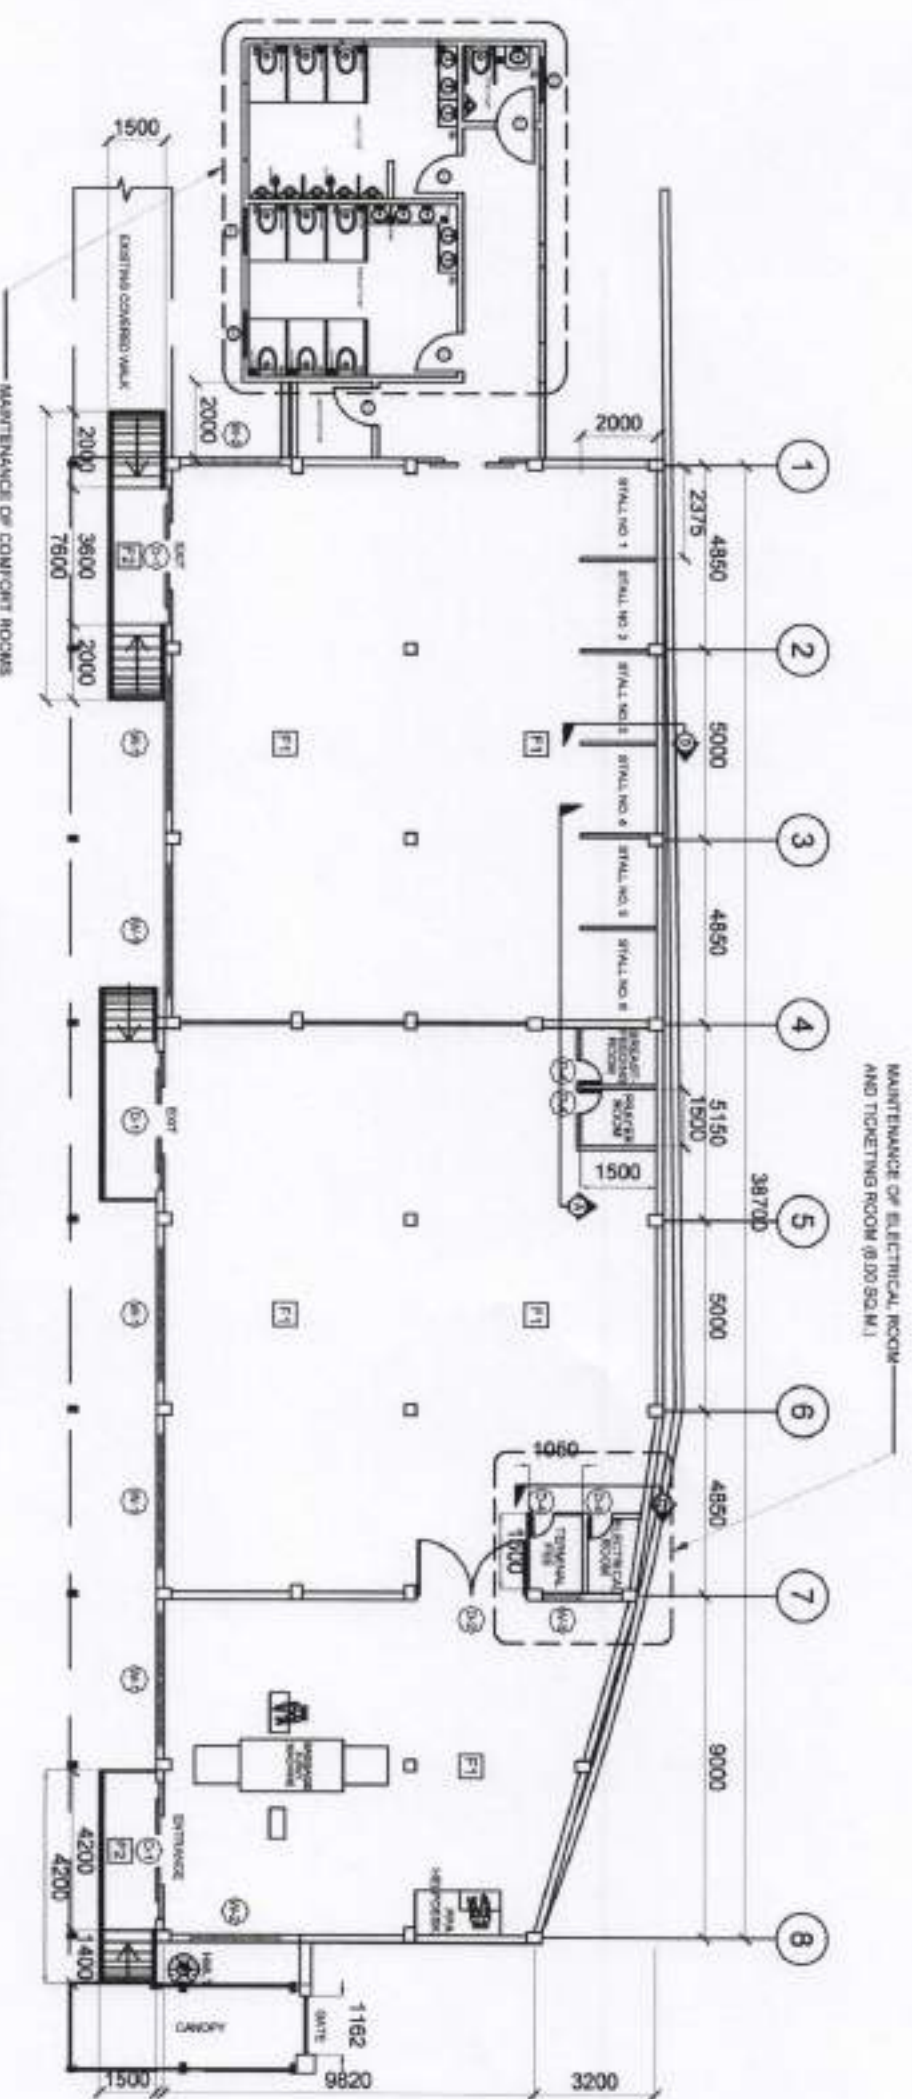PTB-1 FLOOR PLAN
SCALE 1:200

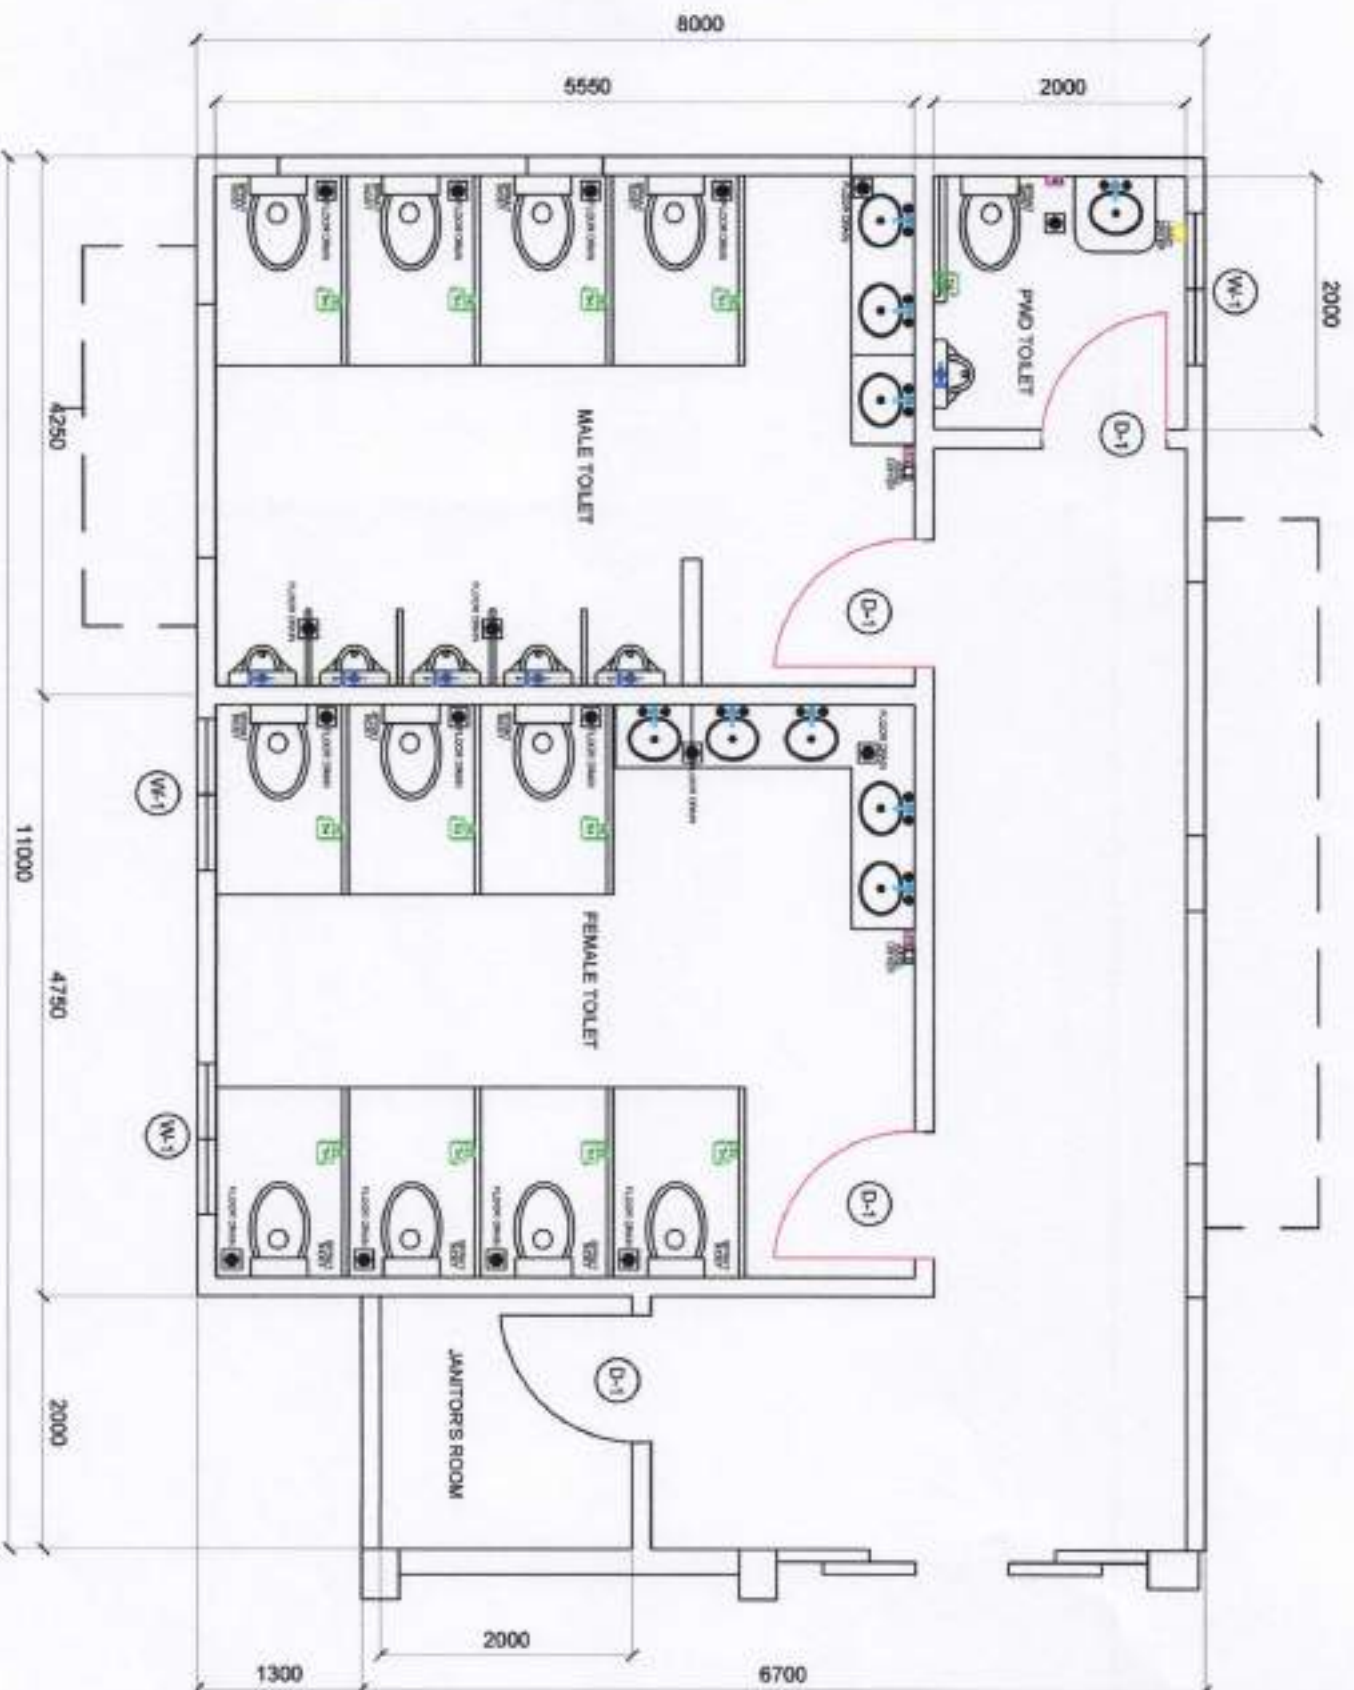

PTB-1 C.R. PLAN

SCALE 1:50

PWD COMFORT ROOM FIXTURES AND ACCESSORIES


- D-1 FLUSH DOOR w/ JAMB (1.00M X 2.10M) INCLUDING AUTOMATIC DOOR CLOSER, DOOR LOCKSET AND ACCESSORIES
- AUTOMATIC HAND DRYER (1 SET)
- LIQUID SOAP DISPENSER (1 SET)
- TOILET PAPER HOLDER (1 SET)
- URINAL FLUSH VALVE (1 SET)
- BIDET SPRAY (1 SET)
- LAVATORY FAUCET GOOSENECK (1 SET)
- WATER TANK FITTINGS DOUBLE PUSH BUTTON INCLUDING TOILET SEAT & COVER, ANGLE VALVE (TWO-WAY), AND STAINLESS FLEXIBLE SUPPLY PIPE (1 SET)

MALE COMFORT ROOM FIXTURES AND ACCESSORIES

- D-1 FLUSH DOOR w/ JAMB (1.00M X 2.10M) INCLUDING AUTOMATIC DOOR CLOSER, DOOR LOCKSET AND ACCESSORIES
- LIQUID SOAP DISPENSER (1 SET)
- TOILET PAPER HOLDER (4 SETS)
- URINAL FLUSH VALVE (5 SETS)
- STAINLESS BIDET SPRAY (4 SETS)
- STAINLESS LAVATORY FAUCET GOOSENECK (3 SETS)
- WATER TANK FITTINGS DOUBLE PUSH BUTTON INCLUDING TOILET SEAT & COVER, ANGLE VALVE (TWO-WAY), AND STAINLESS FLEXIBLE SUPPLY PIPE (4 SETS)

FEMALE COMFORT ROOM FIXTURES AND ACCESSORIES

- D-1 FLUSH DOOR w/ JAMB (1.00M X 2.10M) INCLUDING AUTOMATIC DOOR CLOSER, DOOR LOCKSET AND ACCESSORIES
- LIQUID SOAP DISPENSER (1 SET)
- TOILET PAPER HOLDER (7 SETS)
- STAINLESS BIDET SPRAY (7 SETS)
- STAINLESS LAVATORY FAUCET GOOSENECK (5 SETS)
- WATER TANK FITTINGS DOUBLE PUSH BUTTON INCLUDING TOILET SEAT & COVER, ANGLE VALVE (TWO-WAY), AND STAINLESS FLEXIBLE SUPPLY PIPE (7 SETS)


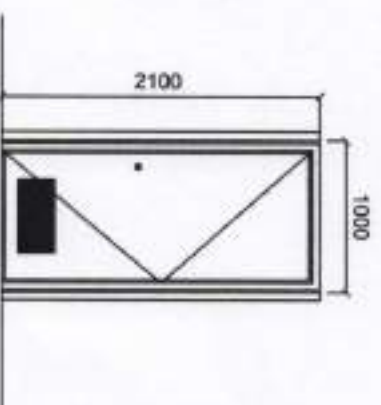


D-1 FLUSH DOOR
SETS REQUIRED THREE (3)

SCHEDULE OF DOOR

SCALE 1:50

PHILIPPINE PORTS AUTHORITY PORT MANAGEMENT OFFICE - MARQUEZ	PROJECT LOCATION: MAINTENANCE OF FACILITIES AT PTB-1, PERIMETER WALL AND DRAINAGE COVER PORT OF BALANACAN	PREPARED BY: MARK ANDREW S. PINEDA ACTING SUPERVISING ENGINEER A	CHECKED/REVIEWED BY: GERLIE D. TABOPO PRINCIPAL ENGINEER A	RECOMMENDED BY: RAUL A. LIBATIQUE ESD MANAGER	APPROVED BY: ANNA THOMAS M. BISCOCHO ACTING PORT MANAGER	SHEET CONTENT: PTB-1 C.R. PLAN SCHEDULE OF DOOR 3 / 8
---	--	--	--	---	--	--

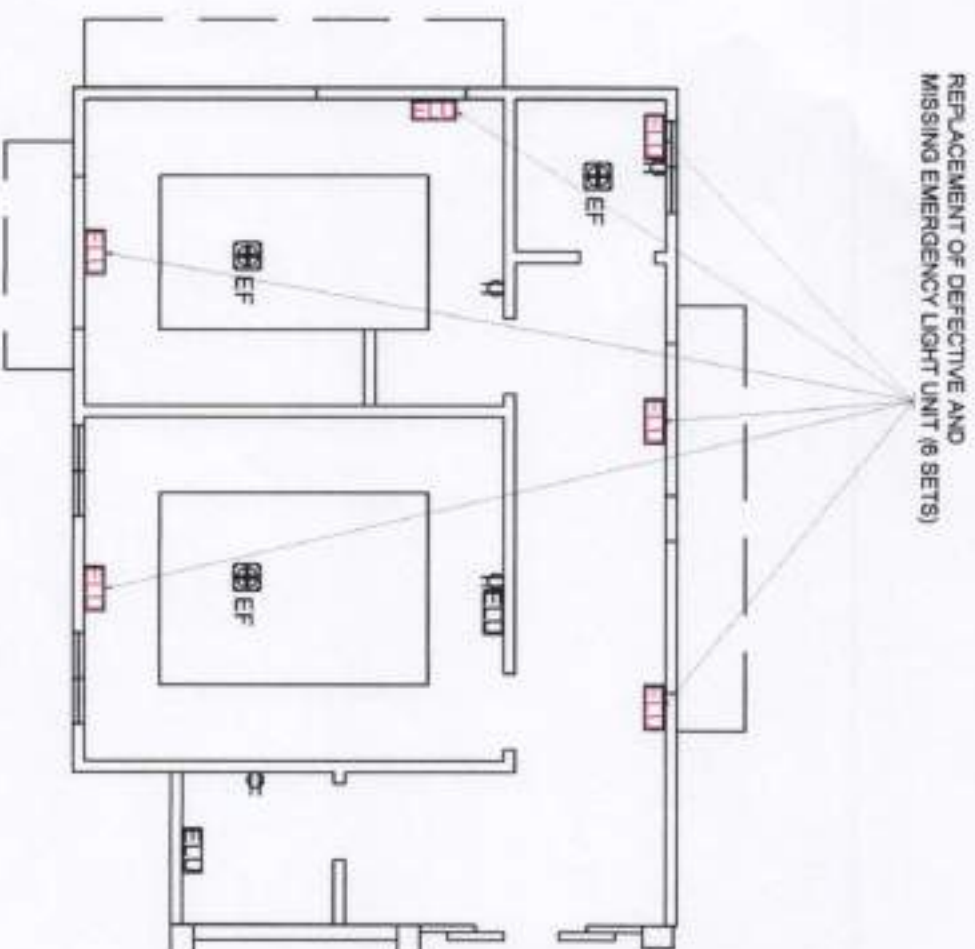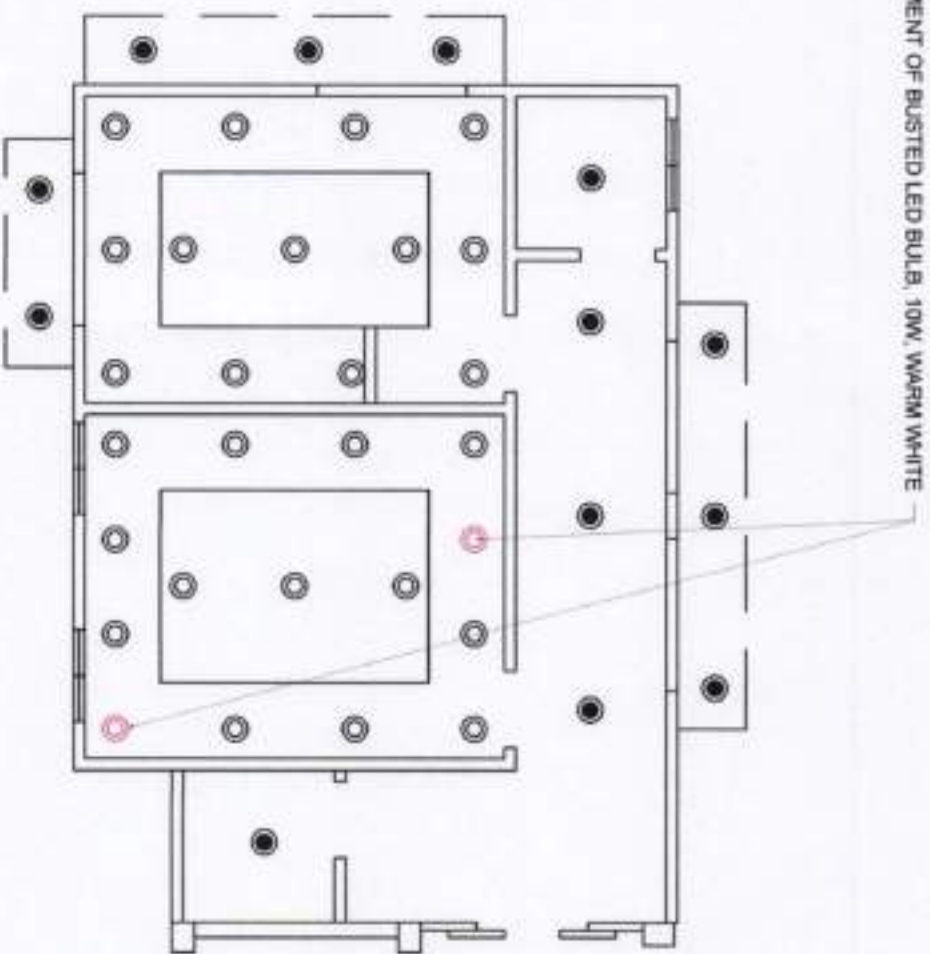

PTB-1 C.R. LIGHTING LAYOUT PLAN
SCALE 1:100

PTB-1 C.R. POWER LAYOUT PLAN
SCALE 1:100

LEGENDS :


- VERTICAL DOWNLIGHT RECESSED MOUNTED TYPE WITH GLASS COVER 5" DIA. LAMP HOLDER, 220V, E27 10 WATT LED BULB, WARM WHITE
- VERTICAL DOWNLIGHT RECESSED MOUNTED TYPE WITHOUT GLASS COVER 5" DIA. LAMP HOLDER CFL BULB 11 WATT, 220V, 3U, E27, DAYLIGHT
- EF EXHAUST FAN, 10"
- ELU EMERGENCY LIGHT UNIT, 220V, TWIN HEAD

 PHILIPPINE PORTS AUTHORITY PORT MANAGEMENT OFFICE - MARQUEZ	PROJECT/LOCATION: MAINTENANCE OF FACILITIES AT PTB-1 PERIMETER WALL AND DRAINAGE COVER PORT OF BALANACAN MARINUQUE	PREPARED BY:  MARK ANDREWS S. PINEDA ACTING SUPERVISING ENGINEER A	CHECKED/REVIEWED BY:  GERLIE D. TABOCO PRINCIPAL ENGINEER A	RECOMMENDED BY:  RAUL A. LIBANIGUE ESD MANAGER	APPROVED BY:  ANNA T. BISCOCHO ACTING PORT MANAGER	SHEET CONTENT: ● PTB-1 LIGHTING LAYOUT PLAN ● PTB-1 POWER LAYOUT PLAN 4 / 8
---	---	--	---	--	--	---

NOTE:
TURNING OVER OF ALL REPLACED PERFORATED
CEILING PANEL BOARD MUST BE COORDINATED
WITH ENGINEERING SERVICES DIVISION

REPLACEMENT OF CEILING PANEL BOARD
WITH PERFORATED METAL PANELS

REPLACEMENT OF CEILING PANEL BOARD
WITH PERFORATED METAL PANELS

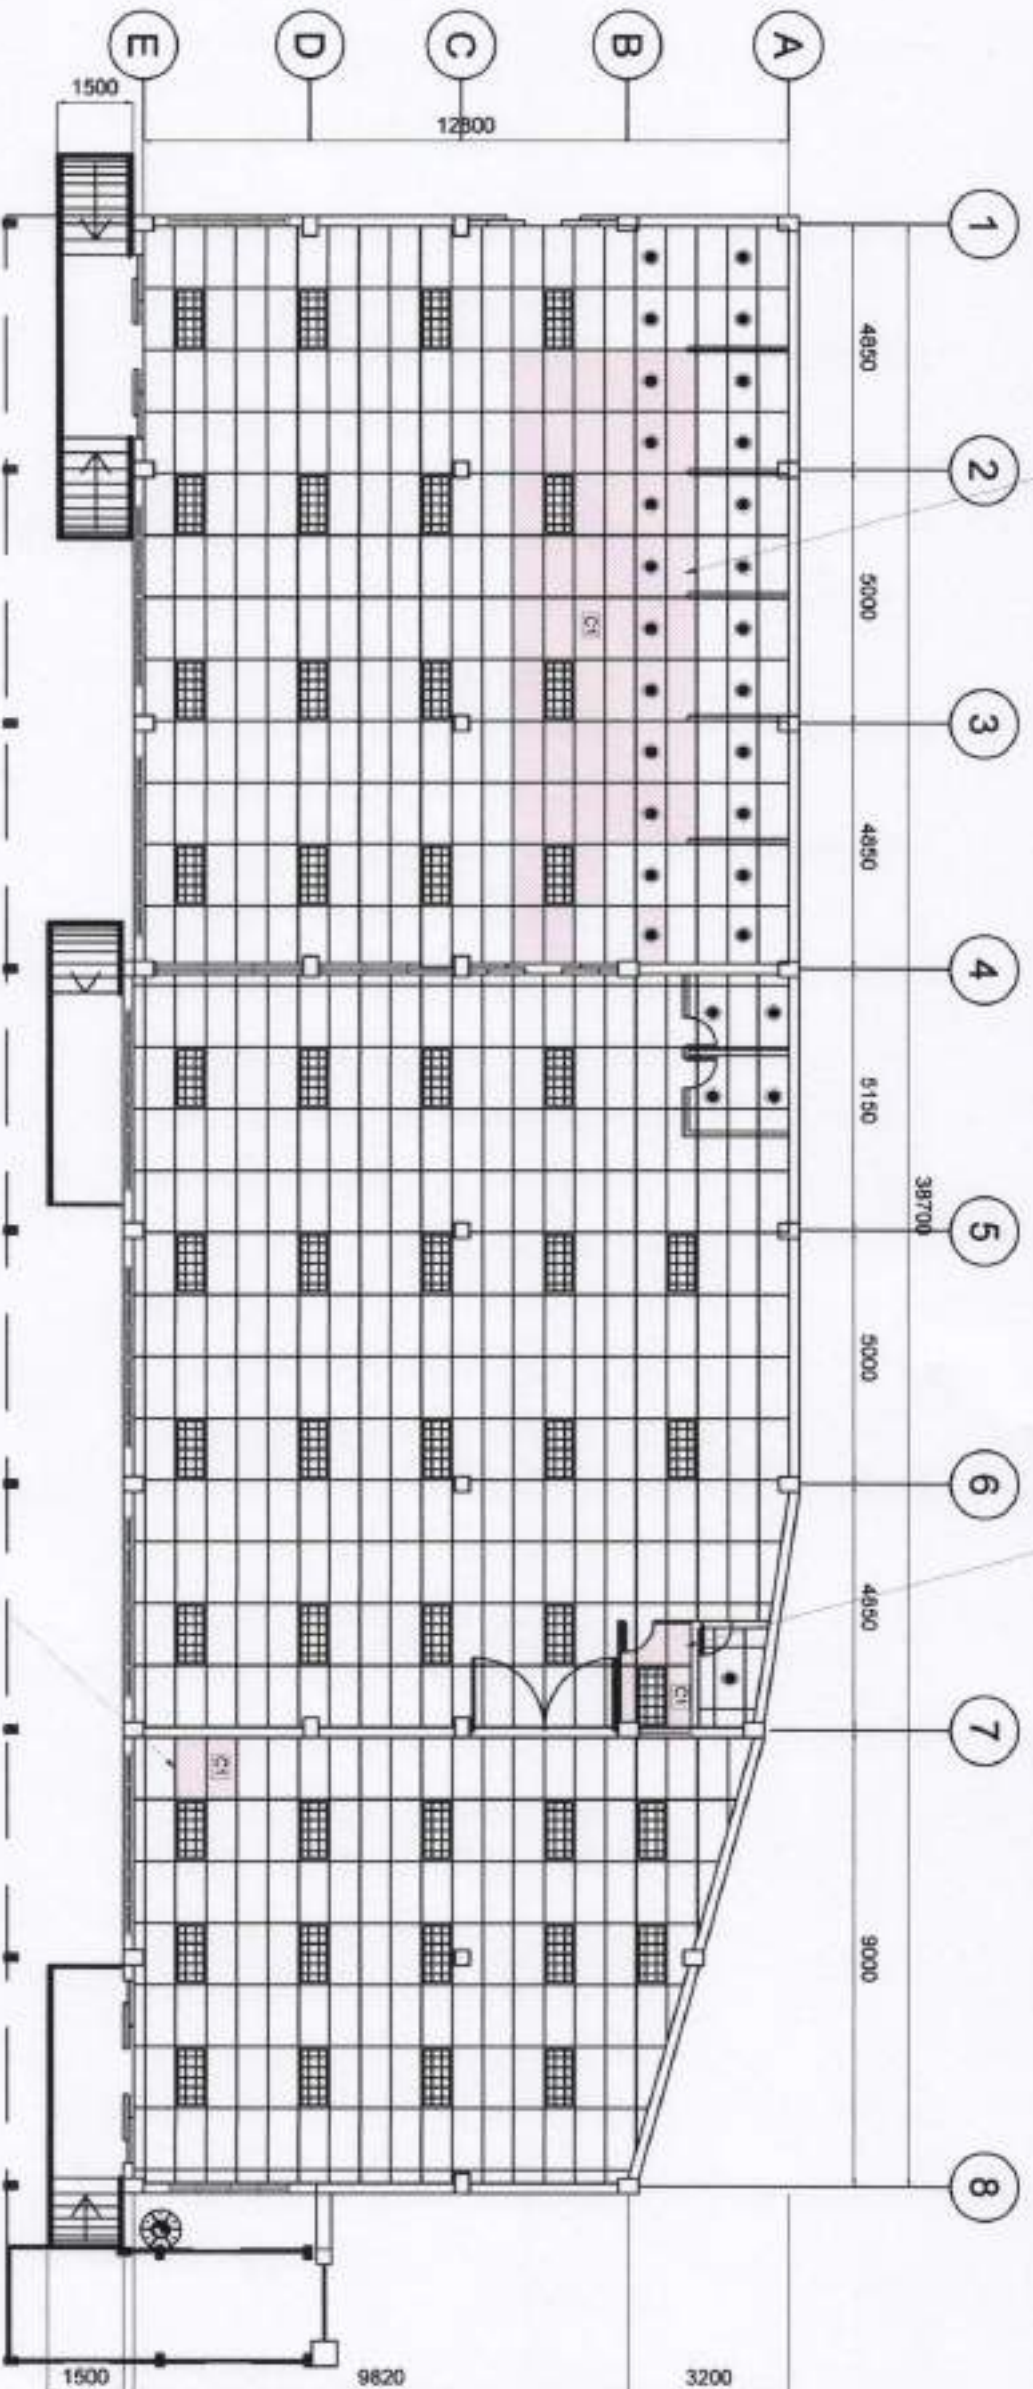


REPLACEMENT OF CEILING PANEL BOARD
WITH PERFORATED METAL PANELS

PTB-1 REFLECTED CEILING PLAN

SCALE 1:150

LEGEND:

PHILIPPINE PORTS AUTHORITY PORT MANAGEMENT OFFICE - MARQUE	PROJECT/LOCATION MAINTENANCE OF FACILITIES AT PTB-1 PERIMETER WALL AND DRAINAGE COVER	PREPARED BY: MARK ANDREW S. PINEDA ARCHITECT SUPERVISING ENGINEER A	CHECKED/REVIEWED BY: GERALD D. TABOCO PRINCIPAL ENGINEER A	RECOMMENDED BY: RAJDA A. LIBATIQUE ESD MANAGER	APPROVED BY: ANNA TERESA M. BISCOCHO PORT MANAGER	SHEET CONTENT: PTB-1 REFLECTED CEILING PLAN 5 / 8
--	---	---	--	--	---	--

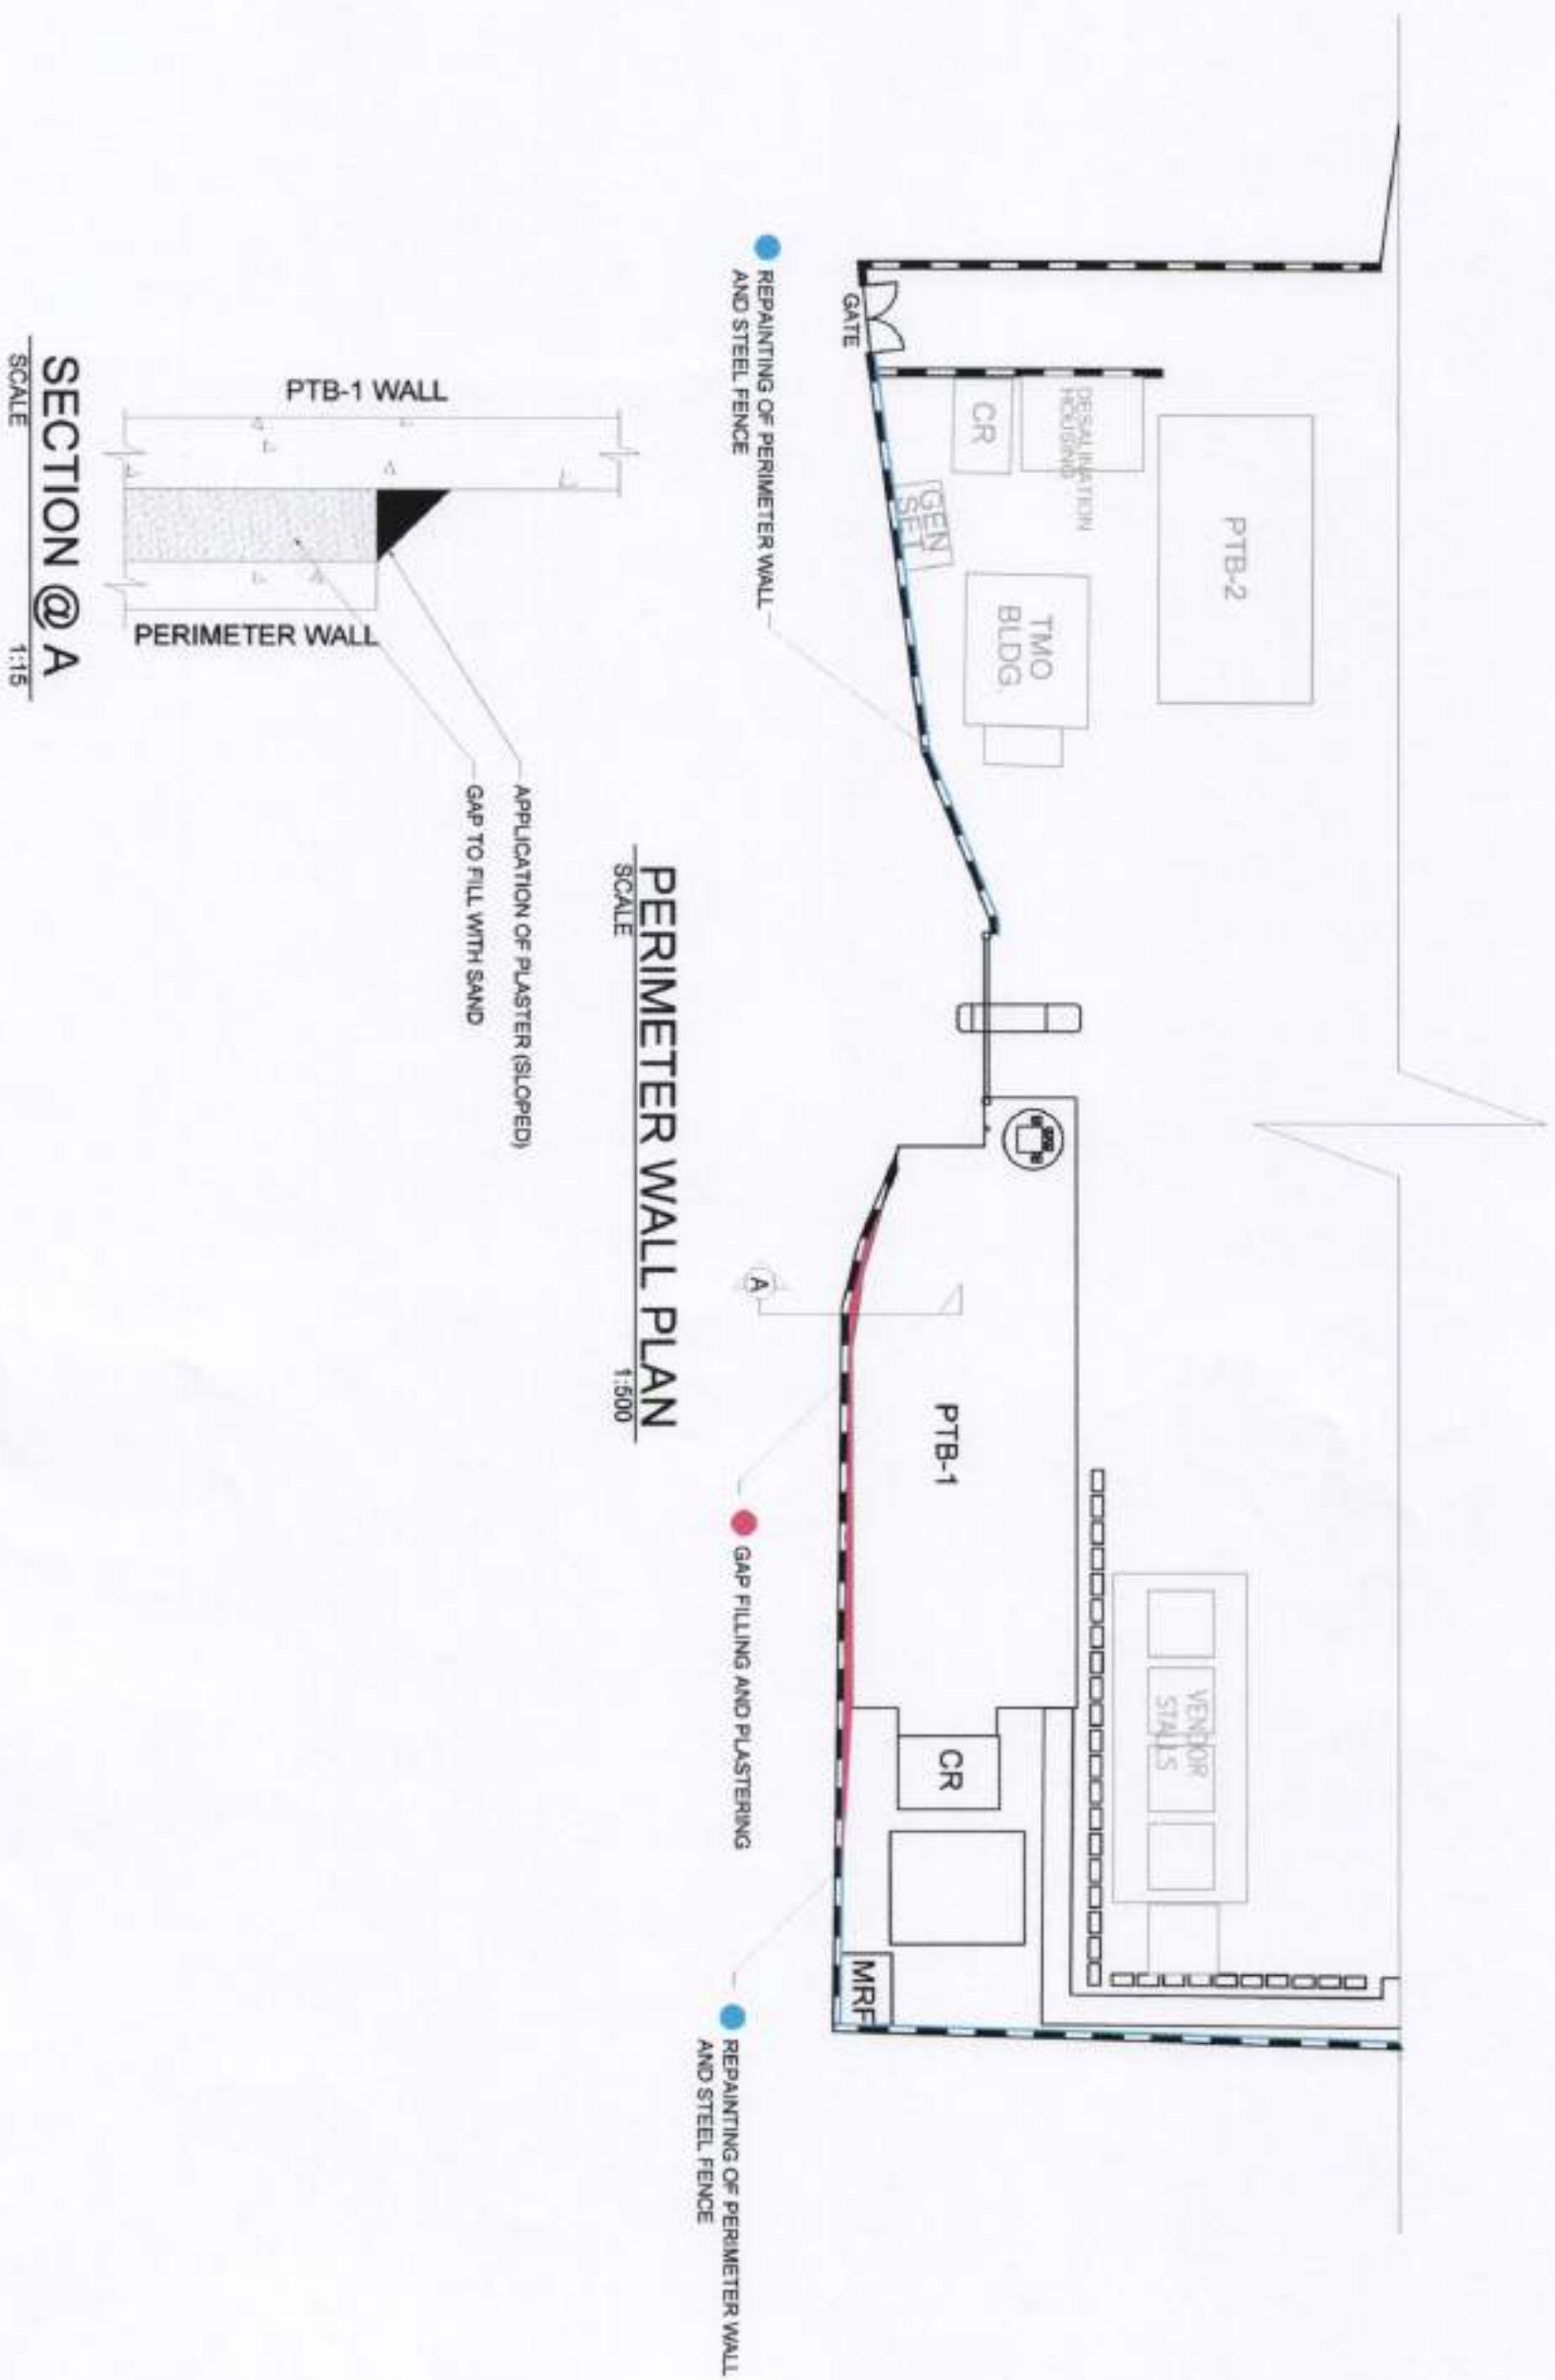

PERIMETER WALL PLAN

SCALE 1:500

SECTION @A

SCALE 1:15

PROJECT/LOCATION

PREPARED BY:


CHECKED/REVIEWED BY:

RECOMMENDED BY:

APPROVED BY _____

SHEET CONTENT


6 / 8

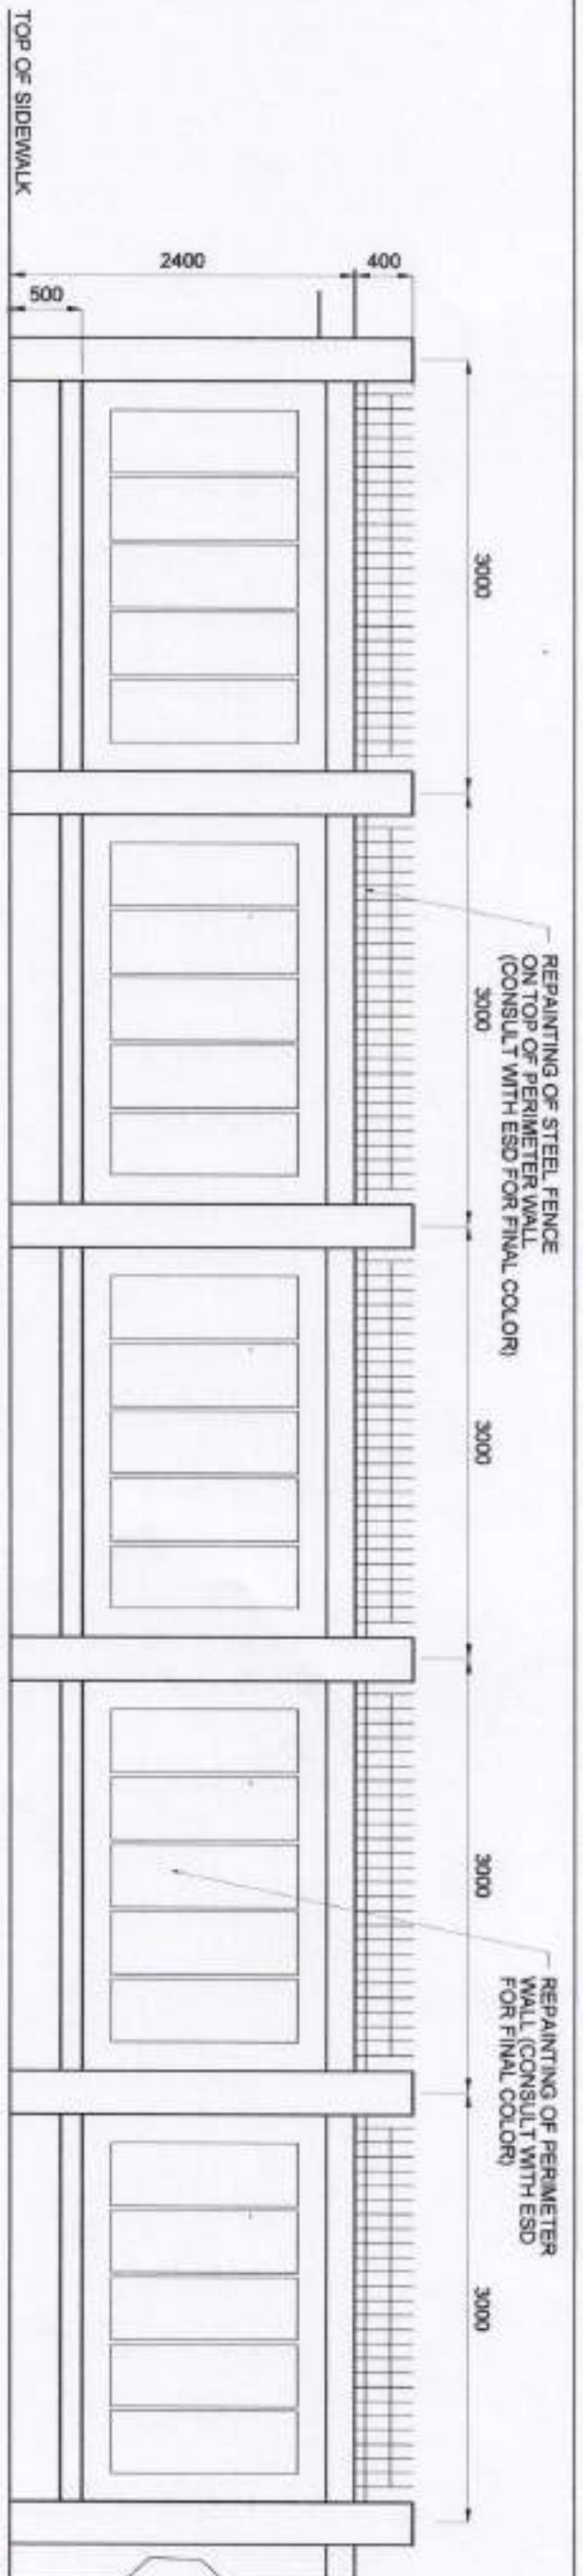

DETAIL OF PERIMETER WALL (BESIDE COVERED WALK)

SCALE

1:50

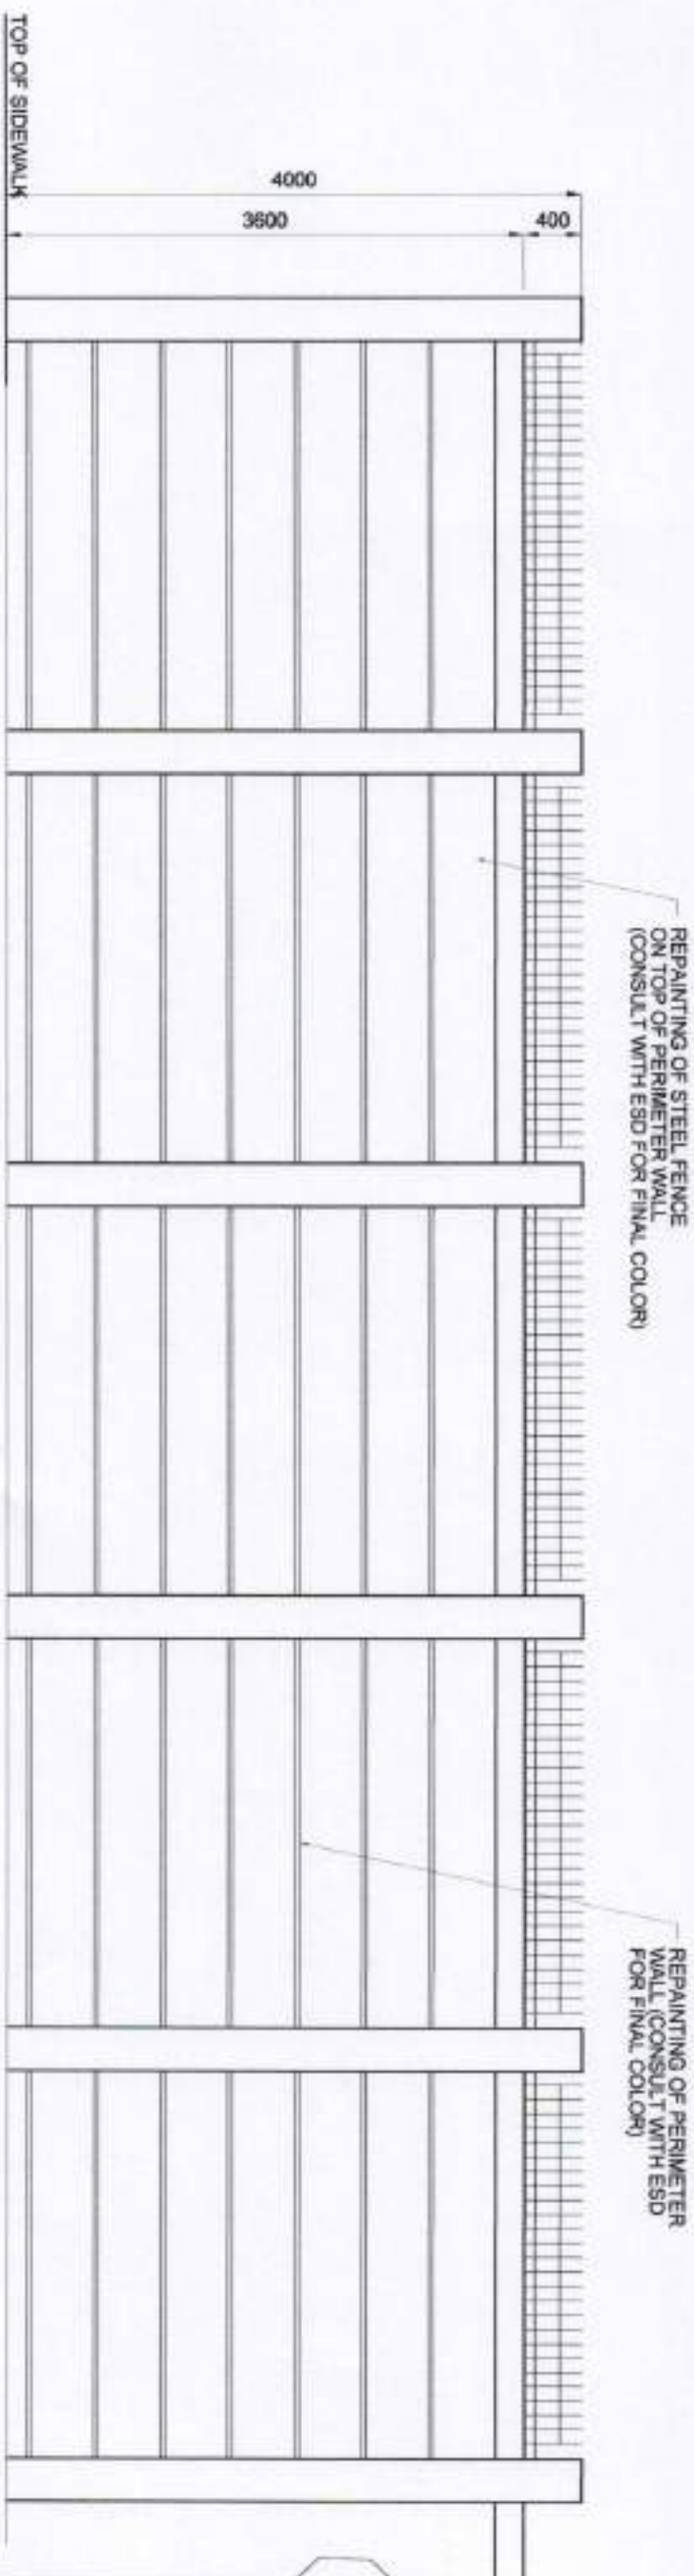


DETAIL OF PERIMETER WALL (NEAR TMO BUILDING)


SCALE


1:50

PHILIPPINE PORTS AUTHORITY PORT MANAGEMENT OFFICE - MARQUEZ	PROJECT LOCATION: MAINTENANCE OF FACILITIES AT PTB-1 PERIMETER WALL AND DRAINAGE COVER PORT OF BALANACAN MARINDUQUE	PREPARED BY: MARK ANDREW S. PINEDA ACTING SUPERVISING ENGINEER A	CHECKED/REVIEWED BY: GERALD D. TABOCO PRINCIPAL ENGINEER A	RECOMMENDED BY: RAUL A. LIBANQUE ESD MANAGER	APPROVED BY: ANNA TERESA M. BISCOCHO ACTING PORT MANAGER	SHEET CONTENT: ● DETAIL OF PERIMETER WALL ● DETAIL OF PERIMETER WALL (NEAR TMO BUILDING) 7 / 8
---	---	--	--	--	--	---

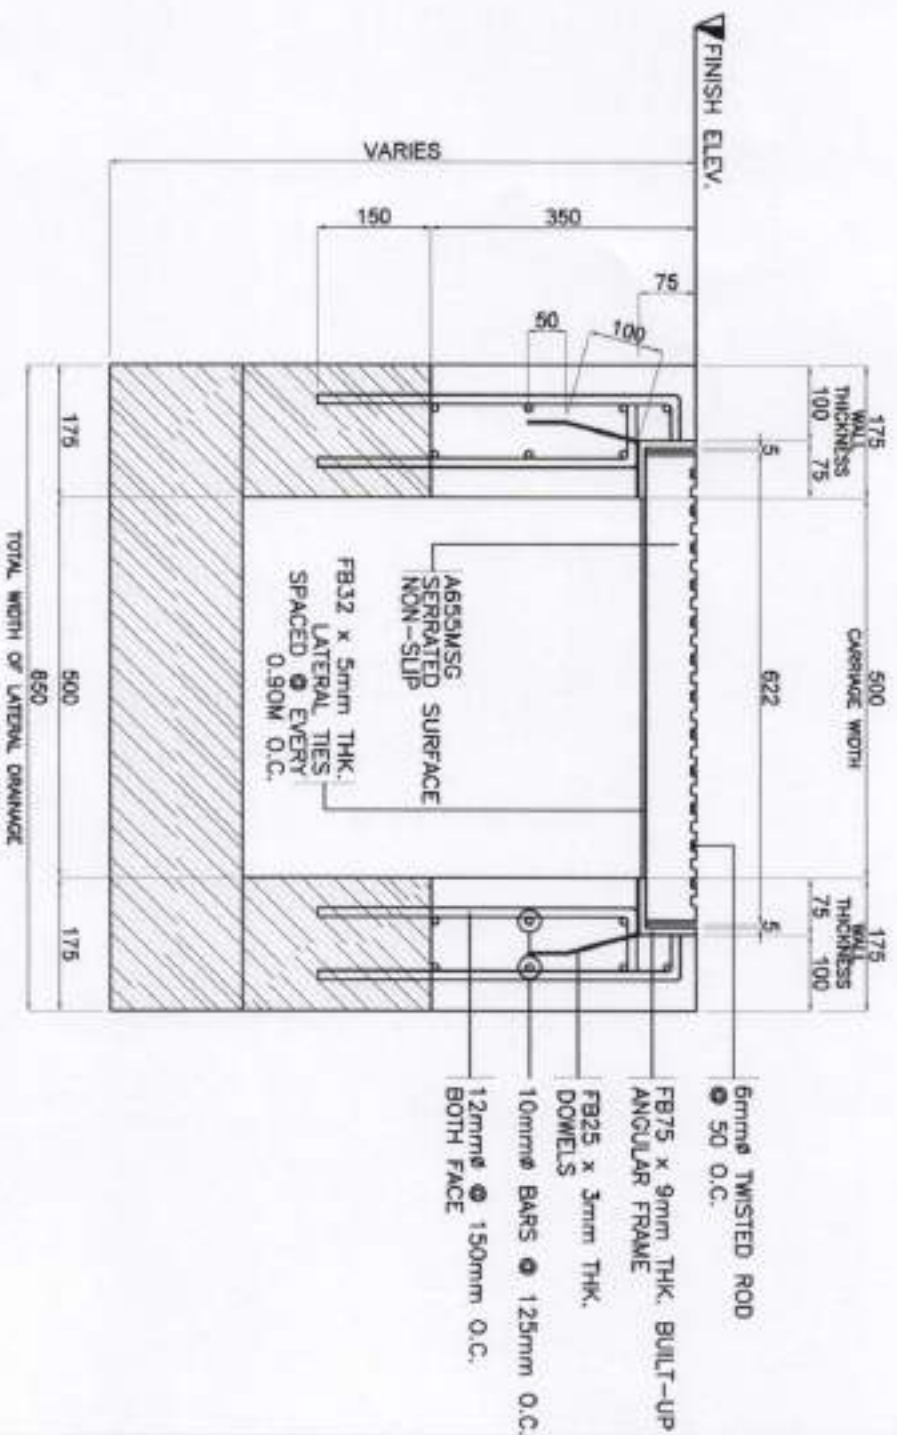

  TYPICAL DETAIL OF LATERAL DRAINAGE
SCALE 1:10



 PHILIPPINE PORTS AUTHORITY PORT MANAGEMENT OFFICE - MANILA	PROJECT/LOCATION:	MAINTENANCE OF FACILITIES AT PTB-1, PERIMETER WALL AND DRAINAGE COVER PORT OF BALANACAN MARINUQUE							
	PREPARED BY:	 MARK ANDREW S. PINEDA SENIOR SUPERVISING ENGINEER A	CHECKED/REVIEWED BY:	 GERLIE D. TABOCO PRINCIPAL ENGINEER A	RECOMMENDED BY:	 PAULA LIBATIQUE ESD MANAGER	APPROVED BY:	 ANNA THERESA M. BISCOCHO ACTING PORT MANAGER	SHEET CONTENT: