
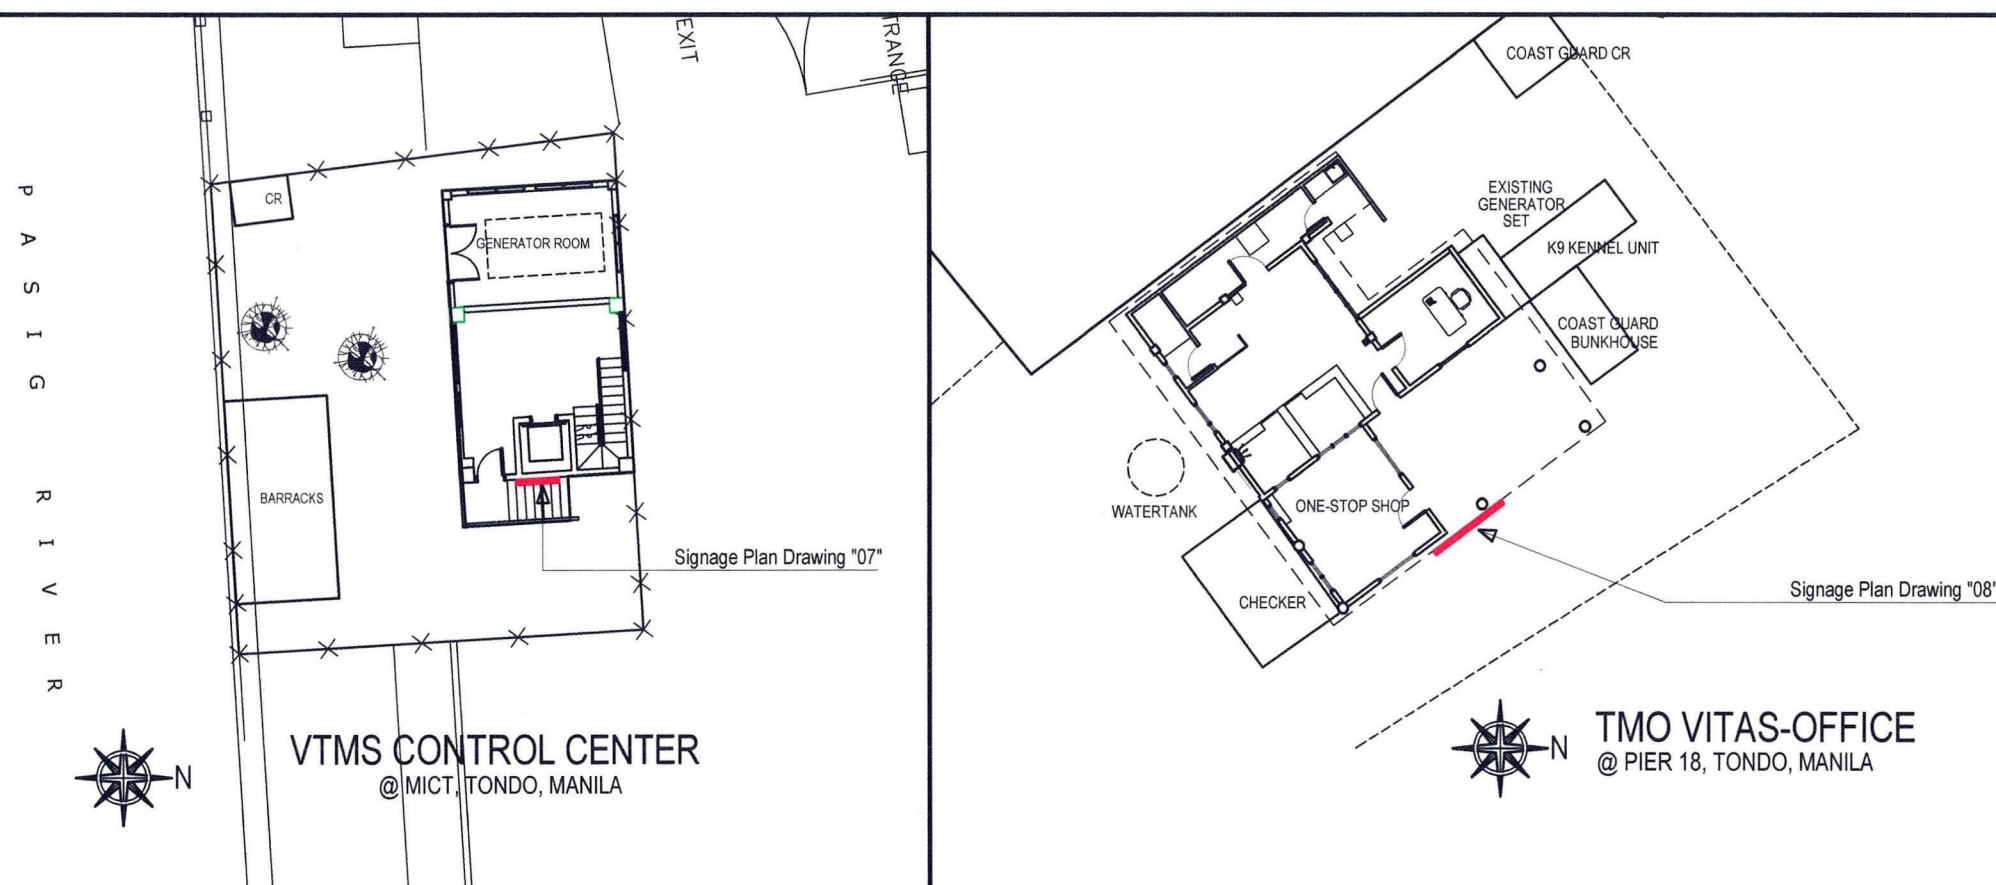


[illegible]

PROJECT CODE: MPF - NCN - 05 - 2026

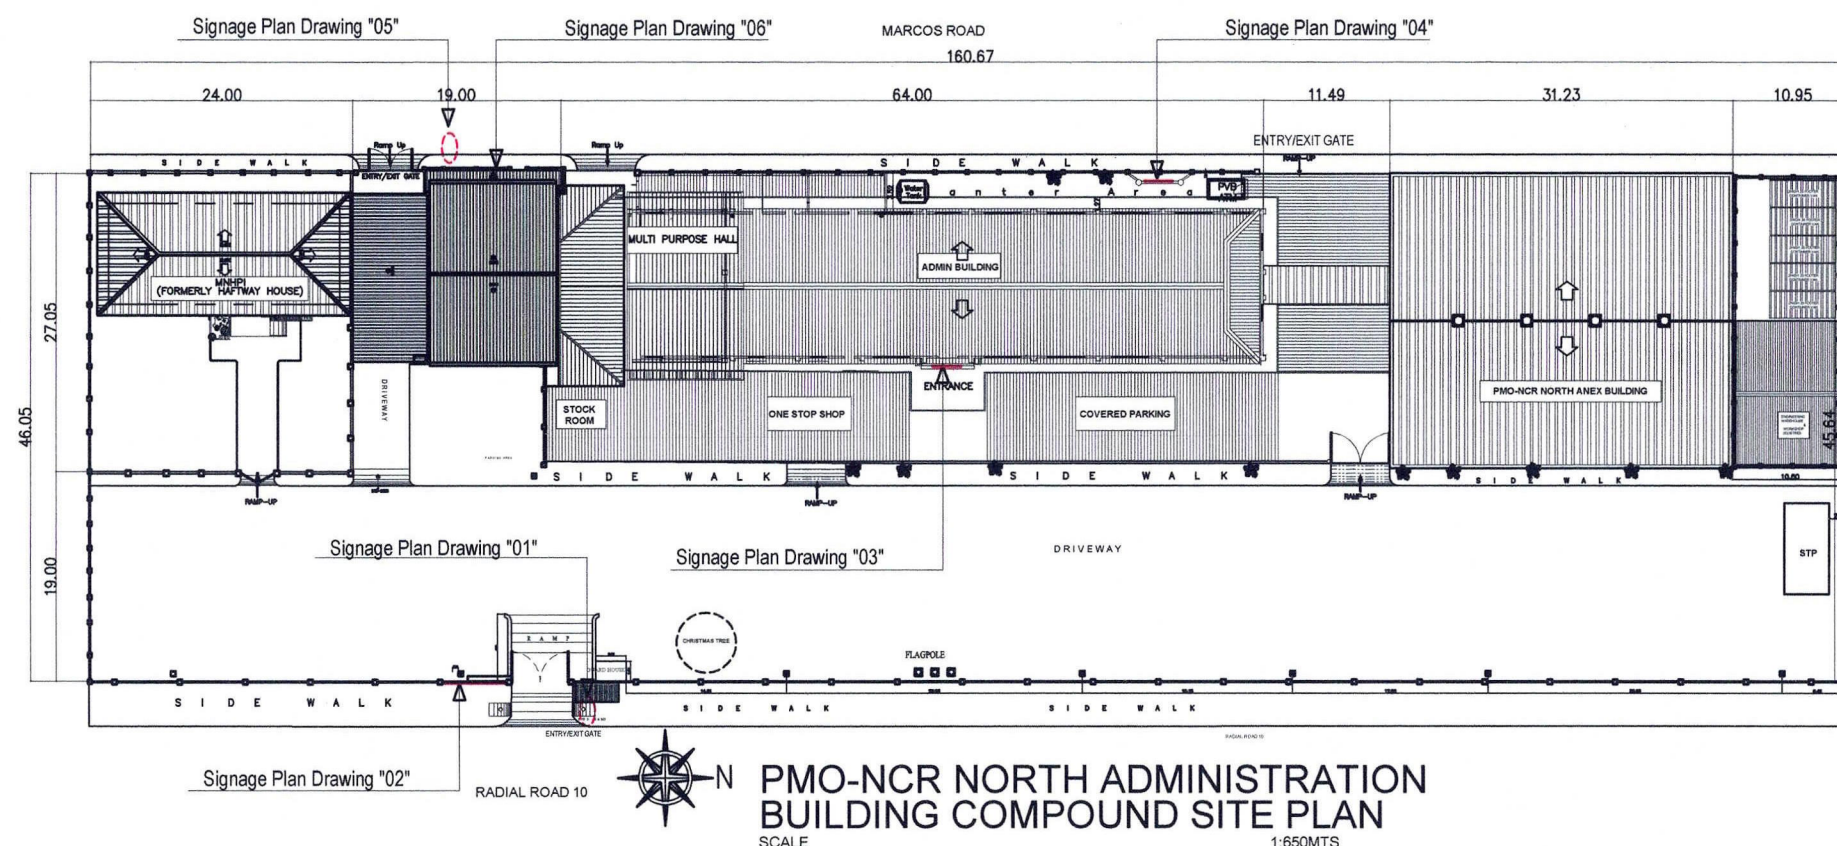

PROJECT TITLE: Maintenance of PPA Lighted Logo Signages, Facilities, Building and Offices at PMO-NCR North

PORT MANAGEMENT OFFICE-
NCR NORTH

PREPARED BY:	
--------------	--

JEVETTE ILAN
Architect II

REVIEW & SUBMITTED BY:

ROUELLA MARIE D. SABATE
Supervising Engineer

APPROVED:

JENNELIZA D. REBONG
Port Manager, PMO-NCR North

SHEET CONTENT:


AS SHOWN

SHEET NO:

A - 1

Signage Plan Drawing "01"

Location; PMO–NCR North Entry/Exit Gate Atop Guardhouse

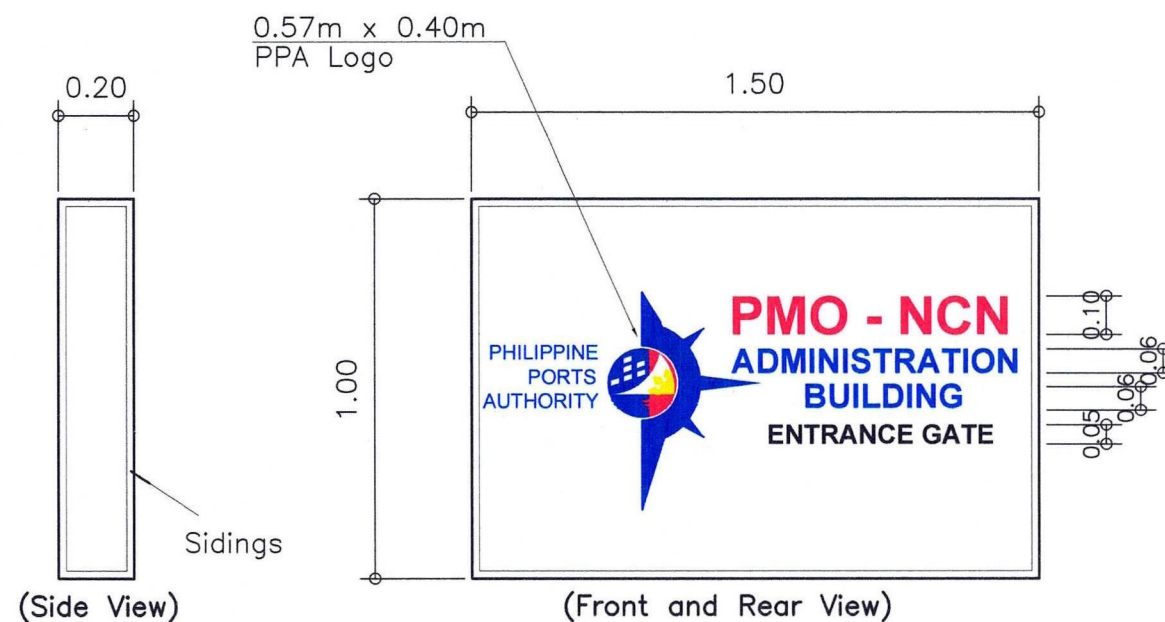

PERSPECTIVE (DAYLIGHT)



PERSPECTIVE (NIGHT)

Double-Face Illuminated Signage (Pole-Mounted)

- Double-Face, internally illuminated, box-type signage
- Size: 1.50m (W) x 1.00m (H) per face
- Pole-mounted, signage suspended/ attached to GI pole support
- Face Panel: 6mm thk. opal white acrylic sheet, laser-cut; painted metal, anti-rust coated
- Lettering & Logo: 3D Lighted built-up Acrylic letters with ACP Base
- Illumination: Internal white LED module lights (6500k) with LED driver mounted inside sign box

NOTE:

- SIGNAGE SUPPORT AND FIXING DETAILS: BY OTHERS (SPECIALTY CONTRACTOR), SUBJECT TO APPROVAL.
- VERIFY ALL ACTUAL SIZES AND DIMENSIONS ON SITE PRIOR TO FABRICATION AND INSTALLATION TO ENSURE PROPER FIT.

PROJECT CODE: MPF - NCN - 05 - 2026



PROJECT TITLE: Maintenance of PPA Lighted Logo Signages, Facilities, Building and Offices at PMO-NCR North

PORT MANAGEMENT OFFICE-
NCR NORTH

PREPARED BY:

JEVETTE LAN
Architect II

REVIEW & SUBMITTED BY:

ROUELLA MARIE D. SABATE
Supervising Engineer

APPROVED:


JENNELIZA D. REBONG
Port Manager, PMO-NCR North

SHEET CONTENT:


AS SHOWN

SHEET NO:

A - 2

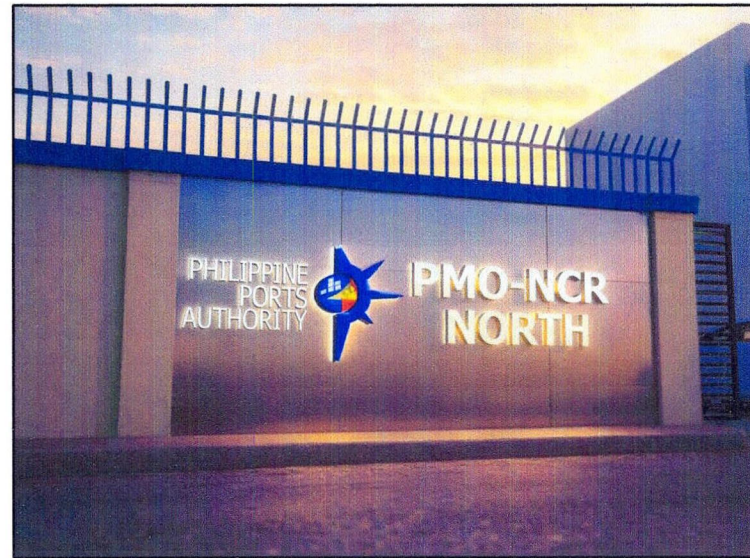

PERSPECTIVE (DAYLIGHT)

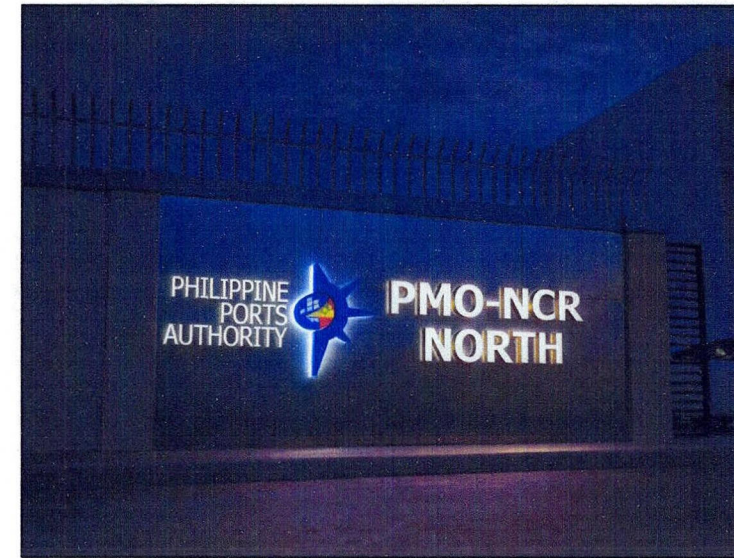


PERSPECTIVE (NIGHT)

Signage Plan Drawing "02"


Location: PMO-NCR North Admin. Building (Facing Radial Road 10)

Acrystain PPA Logo : 1.50m(L) x 1.06m(W)

STAINLESS BUILD-UP w/ LED BACKLIT IN ACP BASE (Wall-Mounted)

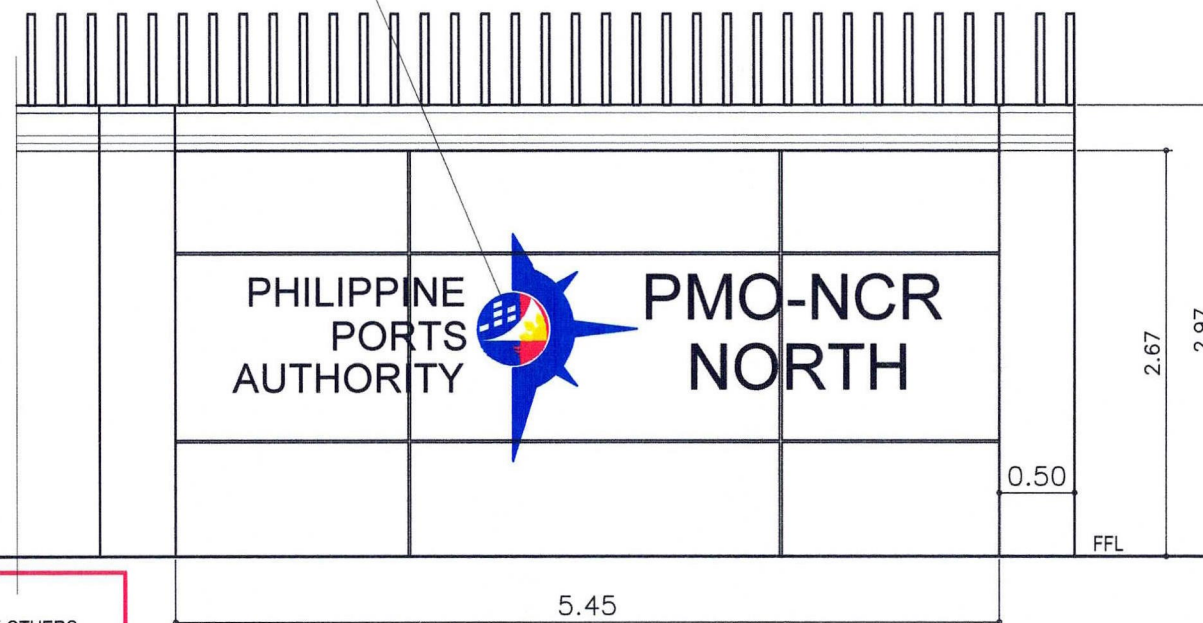

FRONT ELEVATION
SCALE 1:50 MTS

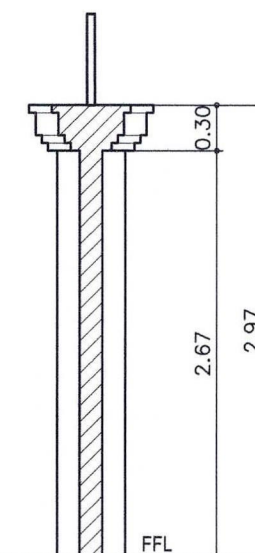

SIDE ELEVATION
SCALE 1:50 MTS

NOTE:

- SIGNAGE SUPPORT AND FIXING DETAILS: BY OTHERS (SPECIALTY CONTRACTOR), SUBJECT TO APPROVAL.
- VERIFY ALL ACTUAL SIZES AND DIMENSIONS ON SITE PRIOR TO FABRICATION AND INSTALLATION TO ENSURE PROPER FIT.

PROJECT CODE: MPF - NCN - 05 - 2026



PROJECT TITLE: Maintenance of PPA Lighted Logo Signages, Facilities, Building and Offices at PMO-NCR North

PORT MANAGEMENT OFFICE-
NCR NORTH

PREPARED BY:

Jevette Milan
JEVETTE MILAN
Architect

REVIEW & SUBMITTED BY:

Rouella Marie D. Sabate
ROUELLA MARIE D. SABATE
Supervising Engineer

APPROVED:


Jenneliza D. Rebong
JENNELIZA D. REBONG
Port Manager, PMO-NCR North

SHEET CONTENT:

AS SHOWN

SHEET NO:

A - 3

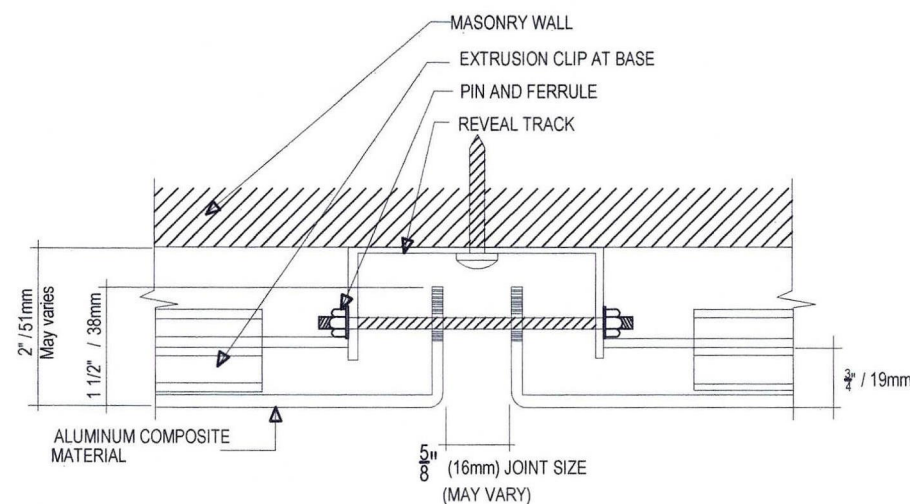

VERTICAL JOINT DETAIL

1. ACP Panel

Thickness: 4mm thk. exterior grade
Edges folded 20–25mm for stiffness

2. Aluminum Angle / Cleat


Sizes: 25 x 25 x 3mm
Riveted to ACP fold

3. Steel Tubular Frame

50 x 50 x 2 mm GI square tube
as structural backing

4. Expansion Bolt


Ø10mm – Ø12mm
Embedded 60–75mm into concrete

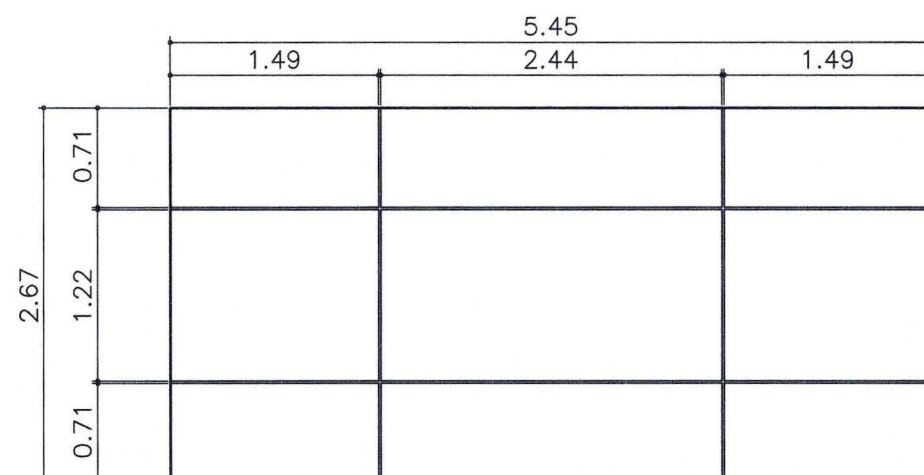

ELEVATION

NOTE:

- SIGNAGE SUPPORT AND FIXING DETAILS: BY OTHERS (SPECIALTY CONTRACTOR), SUBJECT TO APPROVAL.
- VERIFY ALL ACTUAL SIZES AND DIMENSIONS ON SITE PRIOR TO FABRICATION AND INSTALLATION TO ENSURE PROPER FIT.

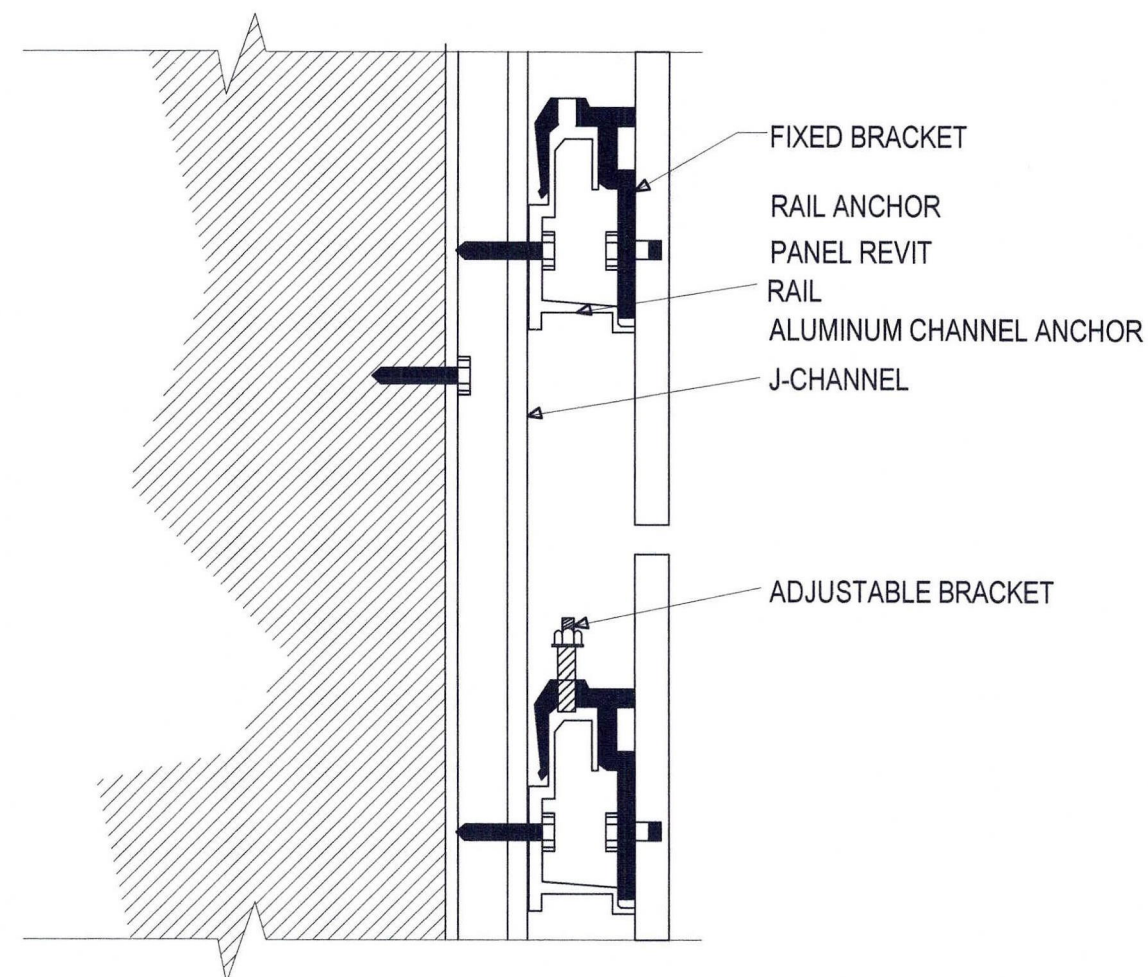

HORIZONTAL JOINT DETAIL

PROJECT CODE: MPF - NCN - 05 - 2026



PROJECT TITLE: Maintenance of PPA Lighted Logo Signages, Facilities, Building and Offices at PMO-NCR North

PORT MANAGEMENT OFFICE-
NCR NORTH

PREPARED BY:

JEVETTE LAN
Architect

REVIEW & SUBMITTED BY:

ROUELLA MARIE D. SABATE
Supervising Engineer

APPROVED:

JENNELIZA D. REBONG
Port Manager, PMO-NCR North

SHEET CONTENT:

AS SHOWN

SHEET NO:

A - 4



PERSPECTIVE (DAYLIGHT)



PERSPECTIVE (NIGHT)

Signage Plan Drawing "03"

DOTR logo (Acrystain)
(0.65m x 0.65m)

Location: PMO-NCR North Admin. Building (Facing Radial Road 10)

PPA logo (Acrystain)
(1.20m x 0.85m)



Single-Face Illuminated Signage (Wall-Mounted 9.00 x 1.50m)

- Single-face, internally illuminated, box-type signage
- Wall-mounted, flush installation with concealed fixings
- Face Panel: 6mm thk. opal white acrylic sheet, laser-cut
- Structure: Welded galvanized iron (GI) box with internal steel frame; painted metal, anti-rust coated
- Lettering & Logo: 3D built-up acrylic letters, 3mm face with 15mm depth
- Illumination: Internal white LED module lights (6500k) with LED driver mounted inside sign box

NOTE:

- SIGNAGE SUPPORT AND FIXING DETAILS: BY OTHERS (SPECIALTY CONTRACTOR), SUBJECT TO APPROVAL.
- VERIFY ALL ACTUAL SIZES AND DIMENSIONS ON SITE PRIOR TO FABRICATION AND INSTALLATION TO ENSURE PROPER FIT.

PROJECT CODE: MPF - NCN - 05 - 2026



PROJECT TITLE: Maintenance of PPA Lighted Logo Signages, Facilities, Building and Offices at PMO-NCR North

PORT MANAGEMENT OFFICE-
NCR NORTH

PREPARED BY:

JEVETTE L. AN
Architect

REVIEW & SUBMITTED BY:

ROUELLA MARIE D. SABATE
Supervising Engineer

APPROVED:

JENNELIZA D. REBONG
Port Manager, PMO-NCR North

SHEET CONTENT:


AS SHOWN

SHEET NO:

A - 5




PERSPECTIVE (DAYLIGHT)

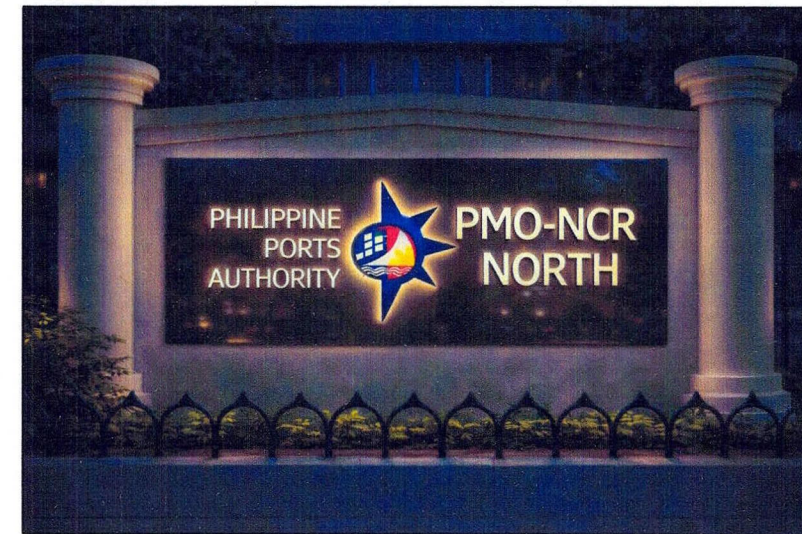

PERSPECTIVE (NIGHT)

Signage Plan Drawing "04"

Location: PMO-NCR North Admin. Building (Facing Marcos Road)

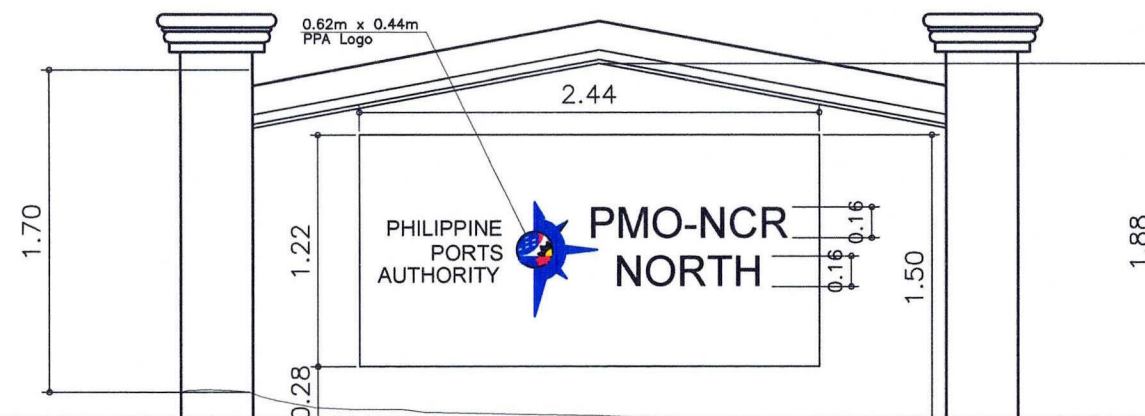


STAINLESS STEEL BACKLIT LETTERS WITH ACP PANEL BACKDROP

- Individual 3D stainless steel channel letters with LED backlit, mounted on an Aluminum Composite Panel (ACP) backdrop for outdoor application.
- Individual 3D stainless steel channel letters with LED backlit, mounted on an Aluminum Composite Panel (ACP) backdrop for

NOTE:

- SIGNAGE SUPPORT AND FIXING DETAILS: BY OTHERS (SPECIALTY CONTRACTOR), SUBJECT TO APPROVAL.
- VERIFY ALL ACTUAL SIZES AND DIMENSIONS ON SITE PRIOR TO FABRICATION AND INSTALLATION TO ENSURE PROPER FIT.

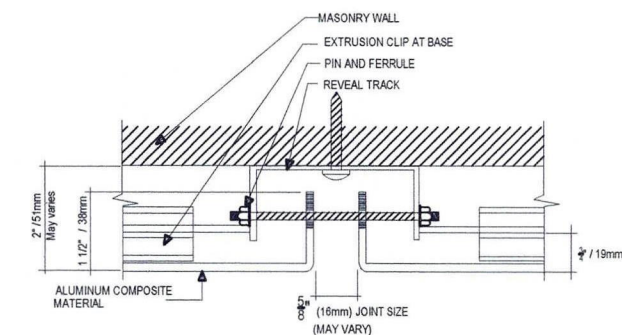

VERTICAL JOINT DETAIL

- 1. ACP Panel**
Thickness: 4mm thk. exterior grade
Edges folded 20-25mm for stiffness
- 2. Aluminum Angle / Cleat**
Sizes: 25 x 25 x 3mm
Riveted to ACP fold
- 3. Steel Tubular Frame**
50 x 50 x 2 mm GI square tube
as structural backing
- 4. Expansion Bolt**
Ø10mm - Ø12mm
Embedded 60-75mm into concrete

PROJECT CODE: MPF - NCN - 05 - 2026



PROJECT TITLE: Maintenance of PPA Lighted Logo Signages, Facilities, Building and Offices at PMO-NCR North

PORT MANAGEMENT OFFICE-
NCR NORTH

PREPARED BY:

JEVETTE MILAN
Architect

REVIEW & SUBMITTED BY:

ROUELLA MARIE D. SABATE
Supervising Engineer

APPROVED:

JENNELIZA D. REBONG
Port Manager, PMO-NCR North

SHEET CONTENT:


AS SHOWN

SHEET NO:

A - 6

Plan Drawing "05"

Location: PPA Office along Marcos Road

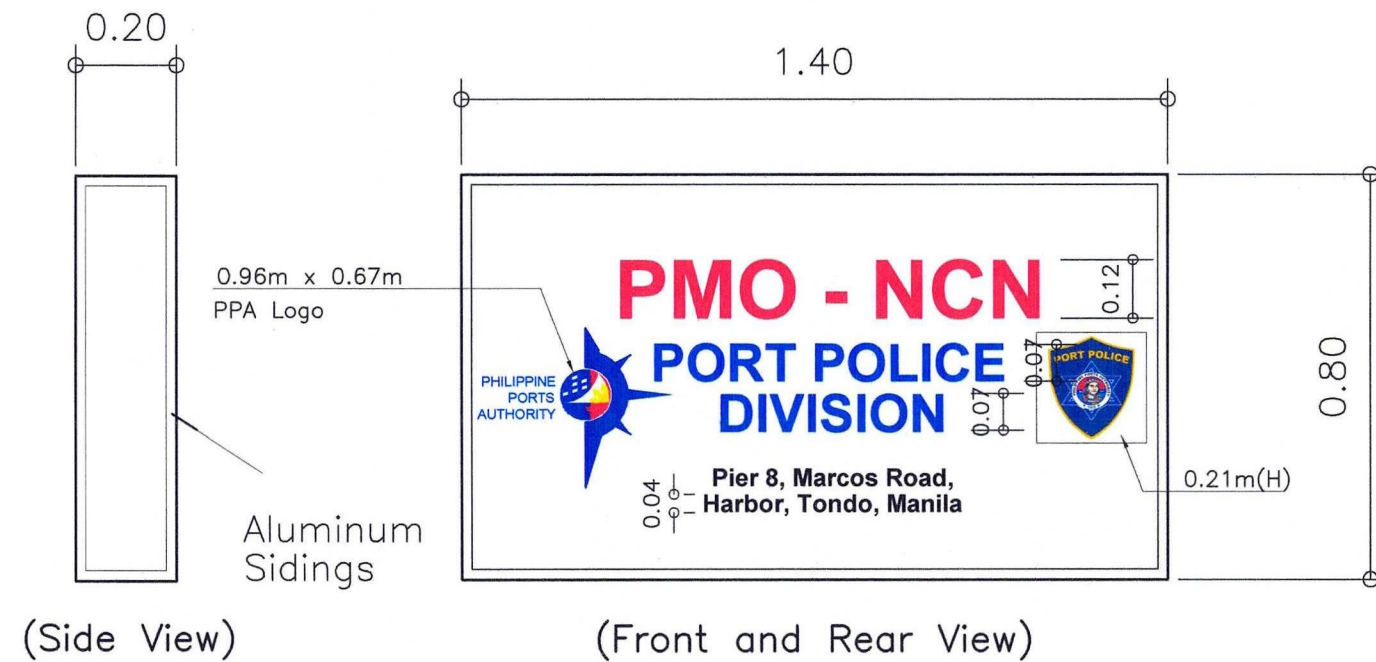

PERSPECTIVE (DAYLIGHT)



PERSPECTIVE (NIGHT)

Double-Face Illuminated Signage (Pole-Mounted)

- Double-Face, internally illuminated, box-type signage
- Size: 1.40m (W) x 0.80m (H) per face
- Pole-mounted, signage suspended/ attached to GI pole support
- Face Panel: 6mm thk. opal white acrylic sheet, laser-cut
- Structure: Welded galvanized iron(GI) box with internal steel frame; painted metal, anti-rust coated
- Lettering & Logo: 3D built-up acrylic letters, 3mm face with 15mm depth
- Illumination: Internal white LED module lights (6500k) with LED driver mounted inside sign box (color of the sidings base to client request)

NOTE:


- SIGNAGE SUPPORT AND FIXING DETAILS: BY OTHERS (SPECIALTY CONTRACTOR), SUBJECT TO APPROVAL.
- VERIFY ALL ACTUAL SIZES AND DIMENSIONS ON SITE PRIOR TO FABRICATION AND INSTALLATION TO ENSURE PROPER FIT.

PROJECT CODE: MPF - NCN - 05 - 2026

	PROJECT TITLE: Maintenance of PPA Lighted Logo Signages, Facilities, Building and Offices at PMO-NCR North	PREPARED BY:	REVIEW & SUBMITTED BY:	APPROVED:	SHEET CONTENT:	SHEET NO:
	PORT MANAGEMENT OFFICE- NCR NORTH	JEVETTE ILAN Architect II	ROUELLA MARIE D. SABATE Supervising Engineer	JENNELIZA D. REBONG Port Manager, PMO-NCR North	AS SHOWN	A - 7




PERSPECTIVE (DAYLIGHT)

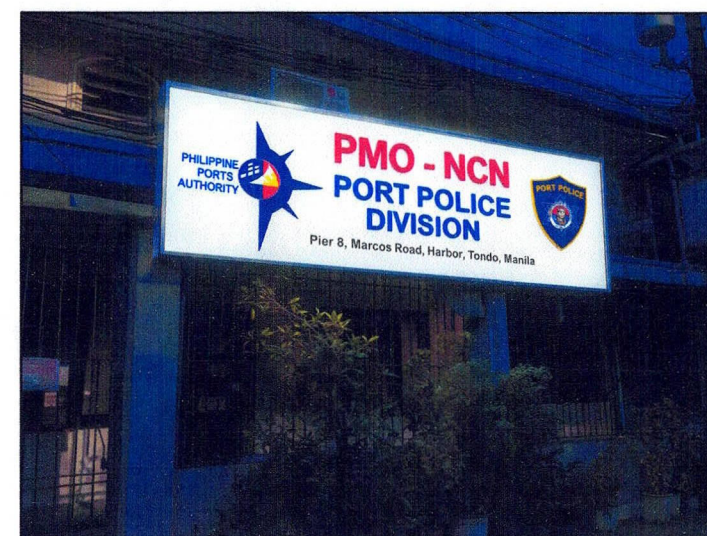

PERSPECTIVE (NIGHT)

Plan Drawing "06"

Location: PPA Office along Marcos Road

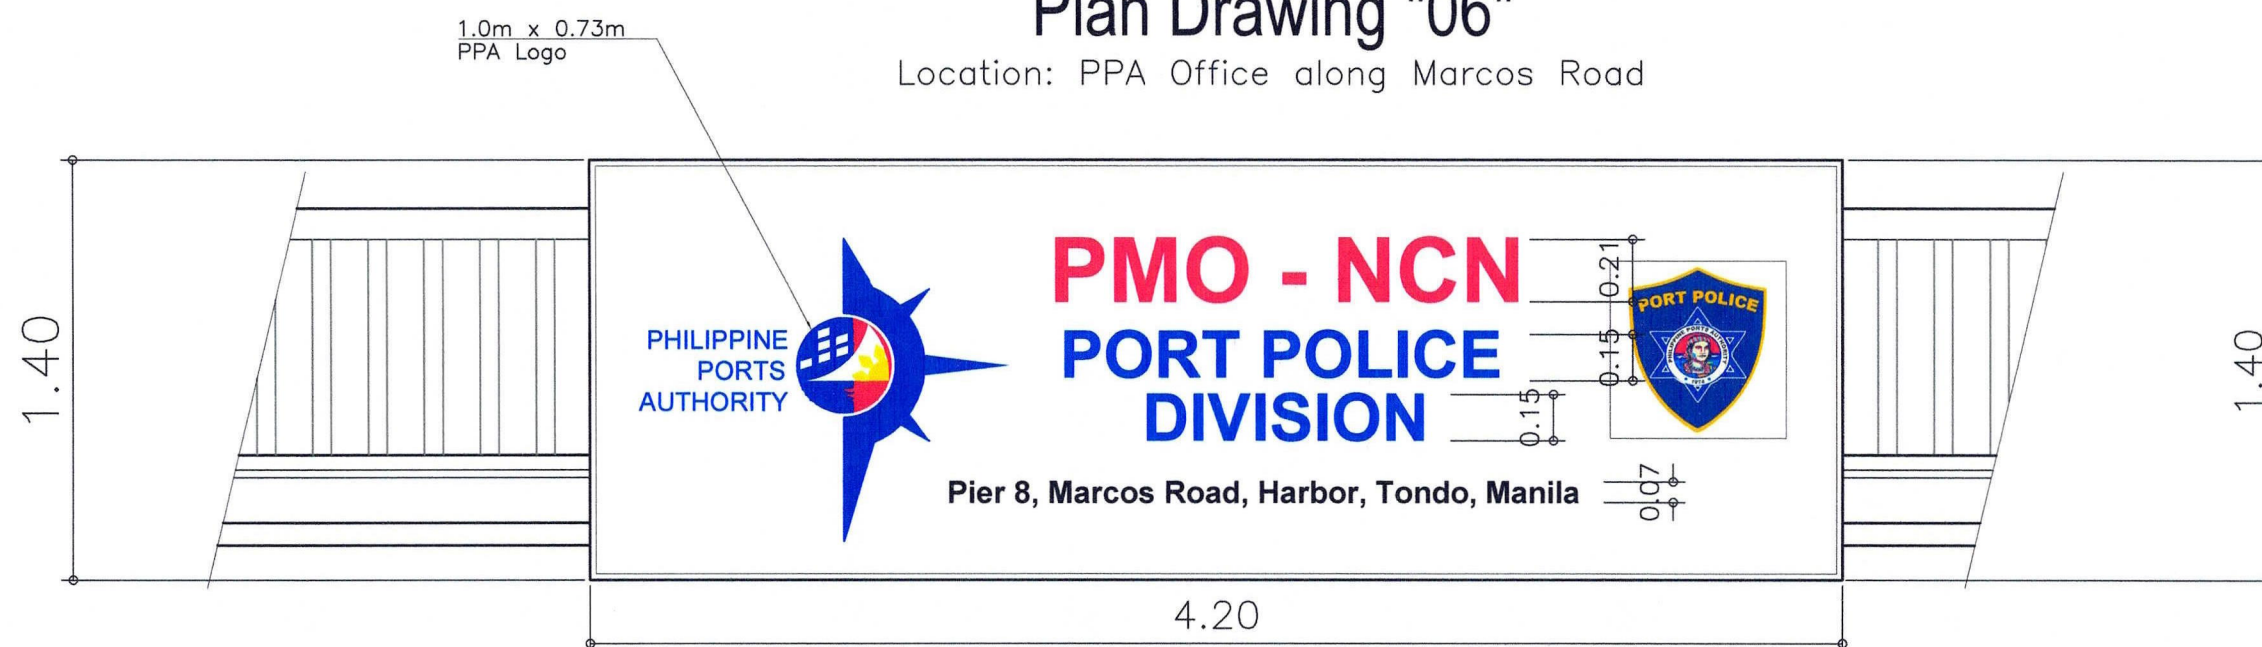

Single-Face Illuminated Signage (Wall-Mounted)

- Single-face, internally illuminated, box-type signage
- Wall-mounted, flush installation with concealed fixings
- Face Panel: 6mm thk. opal white acrylic sheet, laser-cut
- Structure: Welded galvanized iron(GI) box with internal steel frame; painted metal, anti-rust coated
- Lettering & Logo: 3D built-up acrylic letters, 3mm face with 15mm depth
- Illumination: Internal white LED module lights (6500k) with LED driver mounted inside sign box

NOTE:

- SIGNAGE SUPPORT AND FIXING DETAILS: BY OTHERS (SPECIALTY CONTRACTOR), SUBJECT TO APPROVAL.
- VERIFY ALL ACTUAL SIZES AND DIMENSIONS ON SITE PRIOR TO FABRICATION AND INSTALLATION TO ENSURE PROPER FIT.

PROJECT CODE: MPF - NCN - 05 - 2026



PROJECT TITLE: Maintenance of PPA Lighted Logo Signages, Facilities, Building and Offices at PMO-NCR North

PORT MANAGEMENT OFFICE-
NCR NORTH

PREPARED BY:

Jevette Alan
JEVETTE ALAN
Architect II

REVIEW & SUBMITTED BY:

Rouella Marie D. Sabate
ROUELLA MARIE D. SABATE
Supervising Engineer

APPROVED:

Jenneliza D. Rebong
JENNELIZA D. REBONG
Port Manager, PMO-NCR North

SHEET CONTENT:

AS SHOWN

SHEET NO:


A - 8

Signage Plan Drawing "07"

Location: VTSD Control Center Tower, MICT, Tondo, Manila.



PERSPECTIVE (DAYLIGHT)

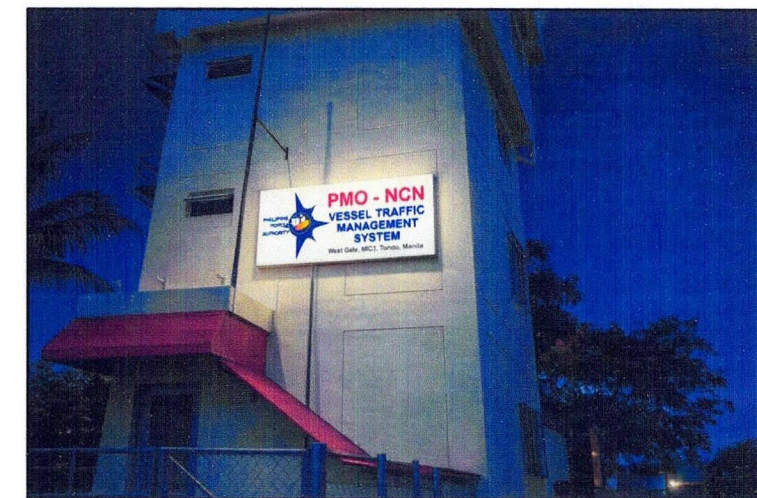

PERSPECTIVE (NIGHT)

Single-Face Illuminated Signage (Wall-Mounted)

- Single-face, internally illuminated, box-type signage
- Wall-mounted, flush installation with concealed fixings
- Face Panel: 6mm thk. opal white acrylic sheet, laser-cut
- Structure: Welded galvanized iron(GI) box with internal steel frame; painted metal, anti-rust coated
- Lettering & Logo: 3D Lighted built-up Acrylic letters with ACP Base
- Illumination: Internal white LED module lights (6500k) with LED driver mounted inside sign box

NOTE:

- SIGNAGE SUPPORT AND FIXING DETAILS: BY OTHERS (SPECIALTY CONTRACTOR), SUBJECT TO APPROVAL.
- VERIFY ALL ACTUAL SIZES AND DIMENSIONS ON SITE PRIOR TO FABRICATION AND INSTALLATION TO ENSURE PROPER FIT.

PROJECT CODE: MPF - NCN - 05 - 2026



PROJECT TITLE: Maintenance of PPA Lighted Logo Signages, Facilities, Building and Offices at PMO-NCR North

PORT MANAGEMENT OFFICE-
NCR NORTH

PREPARED BY:

JEVETTE ILAN
Architect II

REVIEW & SUBMITTED BY:

ROUELLA MARIE D. SABATE
Supervising Engineer

APPROVED:

JENNELIZA D. REBONG
Port Manager, PMO-NCR North

SHEET CONTENT:

AS SHOWN


SHEET NO:

A - 9

Plan Drawing "08"

Location: TMO-Vitas Office

0.96m x 0.67m
PPA Logo

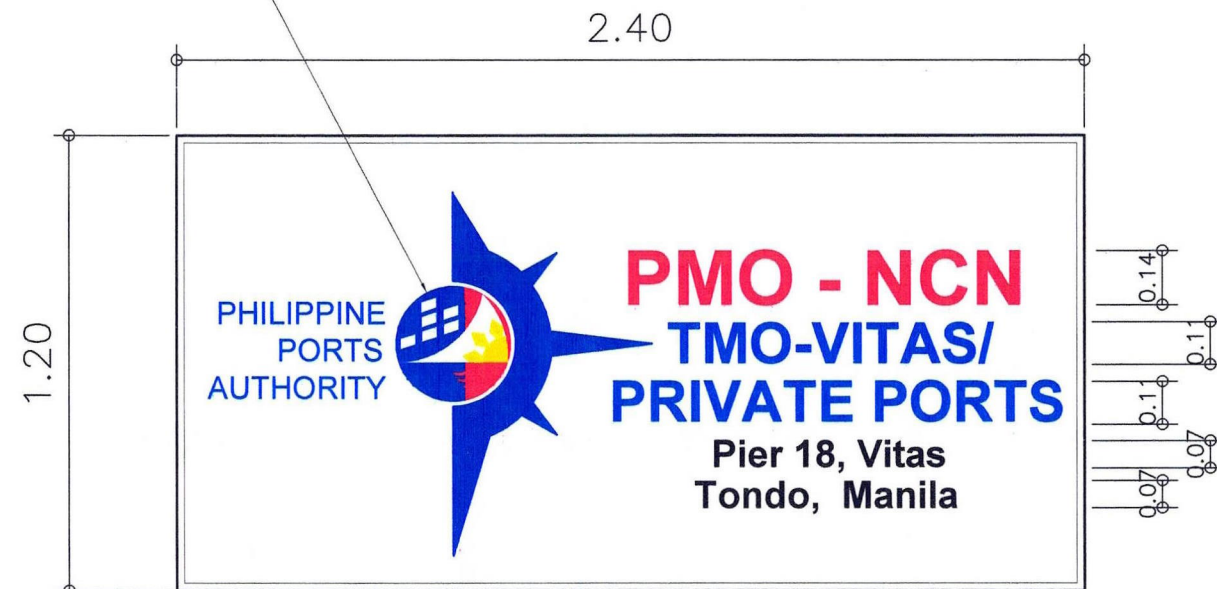

PERSPECTIVE (DAYLIGHT)

Single-Face Illuminated Signage (Roof-Mounted)

- Single-face, internally illuminated, box-type signage
- Size: 2.40m (W) x 1.20m (H)
- Face Panel: 6mm thk. opal white acrylic sheet, laser-cut
- Structure: Welded galvanized iron(GI) box with internal steel frame; painted metal, anti-rust coated
- Lettering & Logo: 3D built-up acrylic letters, 3mm face with 15mm depth
- Illumination: Internal white LED module lights (6500k) with LED driver mounted inside sign box



PERSPECTIVE (NIGHT)

NOTE:

- SIGNAGE SUPPORT AND FIXING DETAILS: BY OTHERS (SPECIALTY CONTRACTOR), SUBJECT TO APPROVAL.
- VERIFY ALL ACTUAL SIZES AND DIMENSIONS ON SITE PRIOR TO FABRICATION AND INSTALLATION TO ENSURE PROPER FIT.

PROJECT CODE: MPF - NCN - 05 - 2026



PROJECT TITLE: Maintenance of PPA Lighted Logo Signages, Facilities, Building and Offices at PMO-NCR North

PORT MANAGEMENT OFFICE-
NCR NORTH

PREPARED BY:

JEVETTE ILAN
Architect II

REVIEW & SUBMITTED BY:

ROUELLA MARIE D. SABATE
Supervising Engineer

APPROVED:



JENNELIZA D. REBONG
Port Manager, PMO-NCR North

SHEET CONTENT:

AS SHOWN

SHEET NO:

A - 10

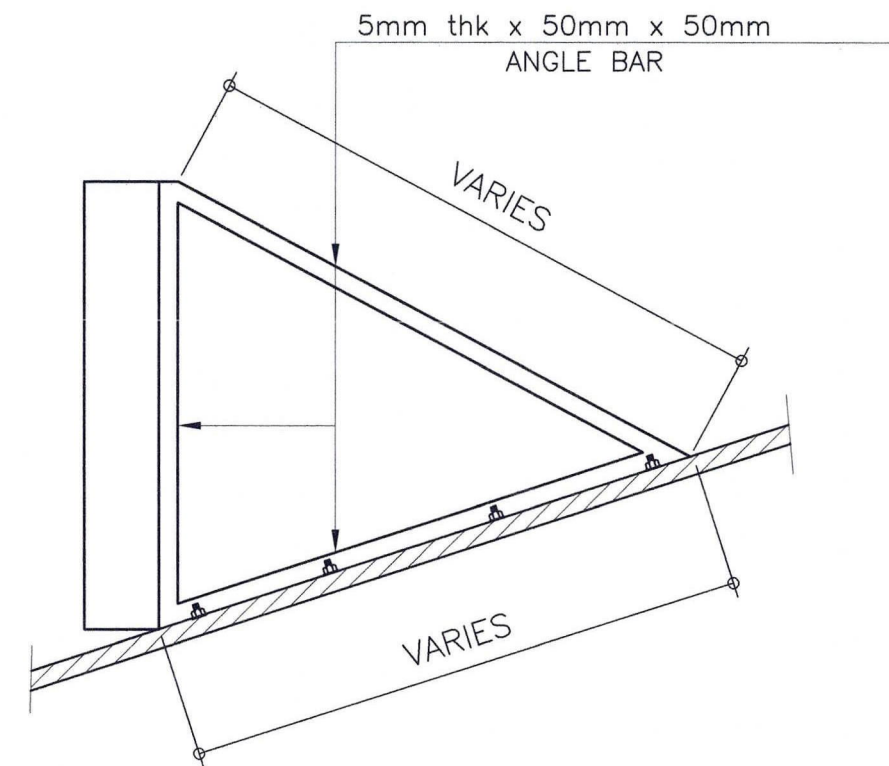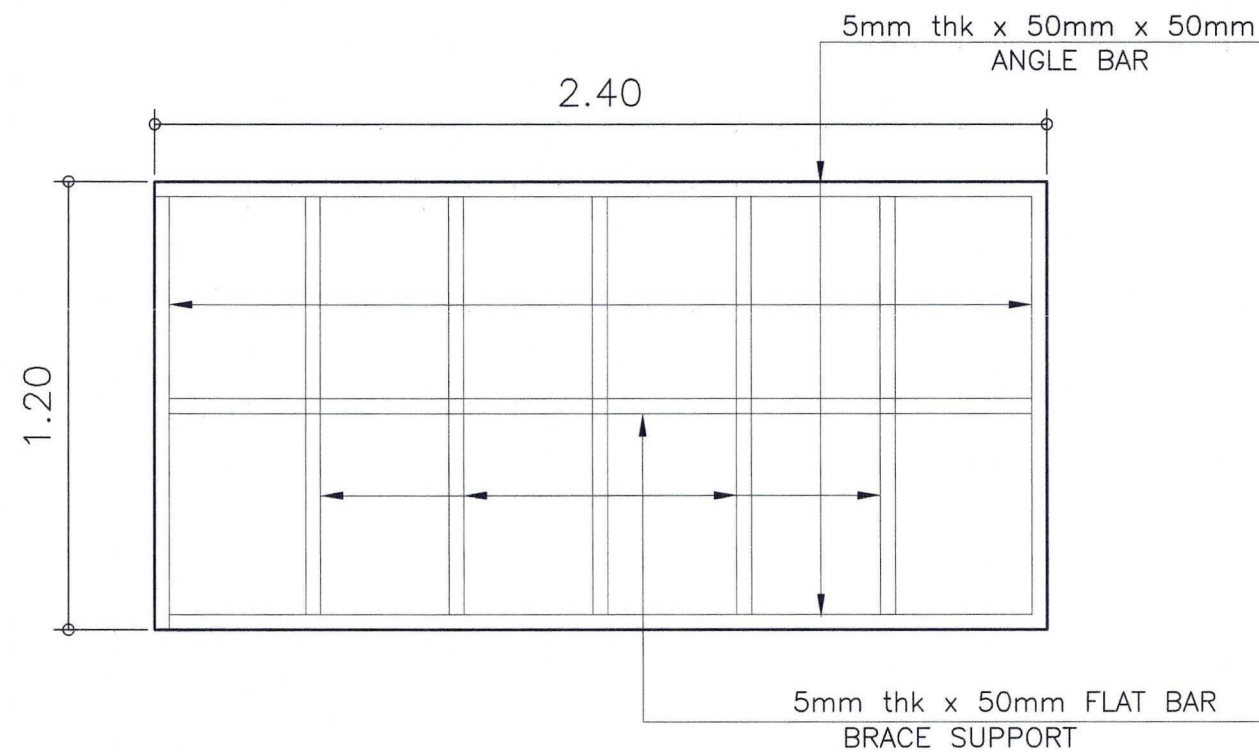

- All existing brace supports of the signage structure shall be removed and replaced with new steel angle bar bracket supports.
- Provide necessary connection and accessories required for a complete and secure installation of signage brackets and support
- Inclination of signage support brackets shall conform to the slope of the existing roof. All dimensions and angles shall be verified on site.
- All exposed steel components shall be applied with one (1) coat anti-rust primer and finished with enamel paint and topcoat

NOTE:

- SIGNAGE SUPPORT AND FIXING DETAILS: BY OTHERS (SPECIALTY CONTRACTOR), SUBJECT TO APPROVAL.
- VERIFY ALL ACTUAL SIZES AND DIMENSIONS ON SITE PRIOR TO FABRICATION AND INSTALLATION TO ENSURE PROPER FIT.

PROJECT CODE: MPF - NCN - 05 - 2026



PROJECT TITLE: Maintenance of PPA Lighted Logo Signages, Facilities, Building and Offices at PMO-NCR North

PORT MANAGEMENT OFFICE-
NCR NORTH

PREPARED BY:

Jevette Lan
JEVETTE LAN
Architect

REVIEW & SUBMITTED BY:

Rouella Marie D. Sabate
ROUELLA MARIE D. SABATE
Supervising Engineer

APPROVED:

Jenneliza D. Rebong
JENNELIZA D. REBONG
Port Manager, PMO-NCR North

SHEET CONTENT:

AS SHOWN

SHEET NO:

A - 11