



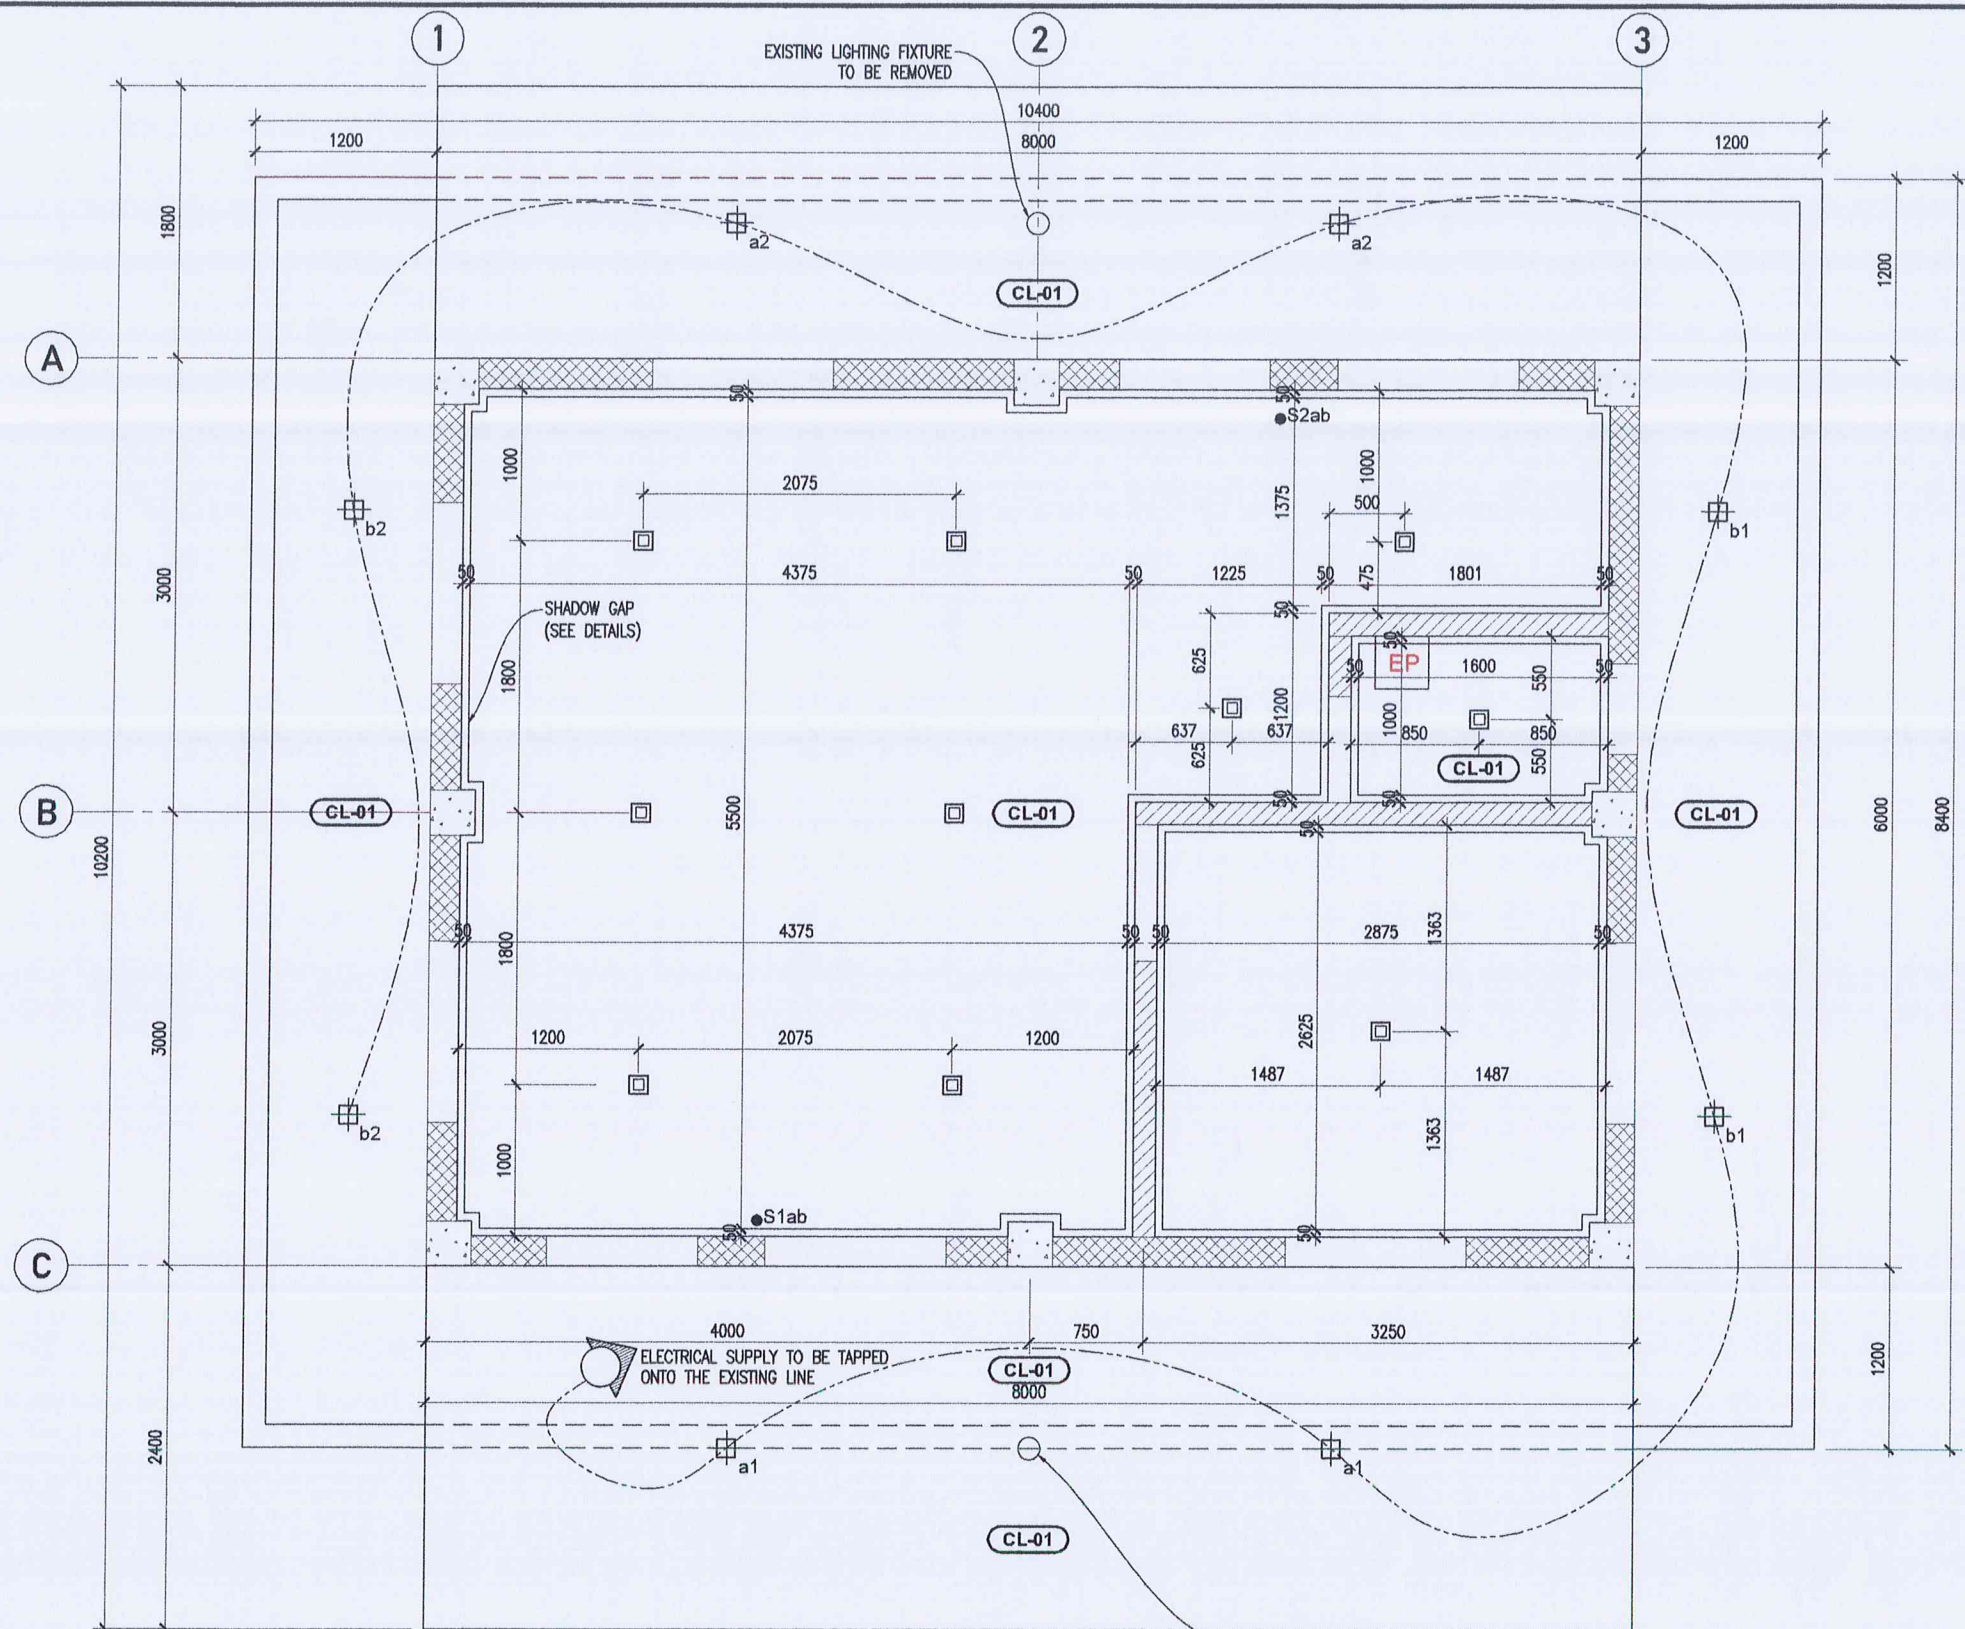

1 **TERMINAL MANAGEMENT OFFICE BLDG REFLECTED CEILING PLAN**
SCALE 1:50mts

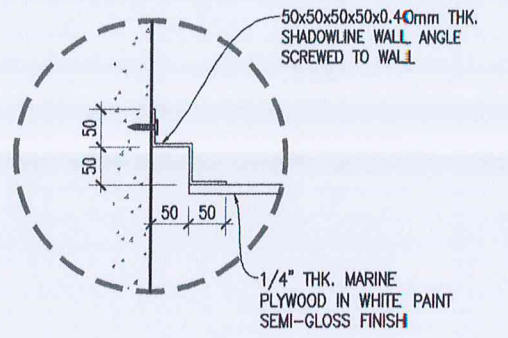

2 **SHADOW GAP DETAILS**
SCALE 1:10mts

LIGHT SWITCHES

S1 LOCATION: FRONT & RIGHT SIDE

S2 LOCATION: REAR & LEFT SIDE

GENERAL NOTE LIGHT SWITCHES

METALLIC GRAY COLOR, SOFT SWITCH WITH QUICK CONNECT TERMINALS

ELECTRICAL : LEGEND	
WIRINGS: ALL ELECTRICAL WIRING TO BE RETAINED; ADDITIONAL ELECTRICAL WIRING FOR THE NEW OUTDOOR LIGHTING	
	120mm X 120mm 12W, LED SQUARE DOWNLIGHT SLIM RECESSED 6500K, DIE CAST ALUMINUM HOUSING
	120mm X 120mm 18W, LED SQUARE SURFACE MOUNTED DOWNLIGHT 6500K, DIE CAST ALUMINUM HOUSING
	ELECTRICAL TAPPING POINT FOR COVE LIGHT (TO BE ADDED)
	TWO GANG SWITCH
	LIGHTING LINE
	AREA: 109.97m ² USE: 1/4" THK. MARINE PLYWOOD ON 2"x2" WOODEN JOIST SPACED @ 400mm O.C. IN WHITE PAINT SEMI-GLOSS FINISH
CCTV	
NOTE: ALL CCTV TO BE RETAINED	