


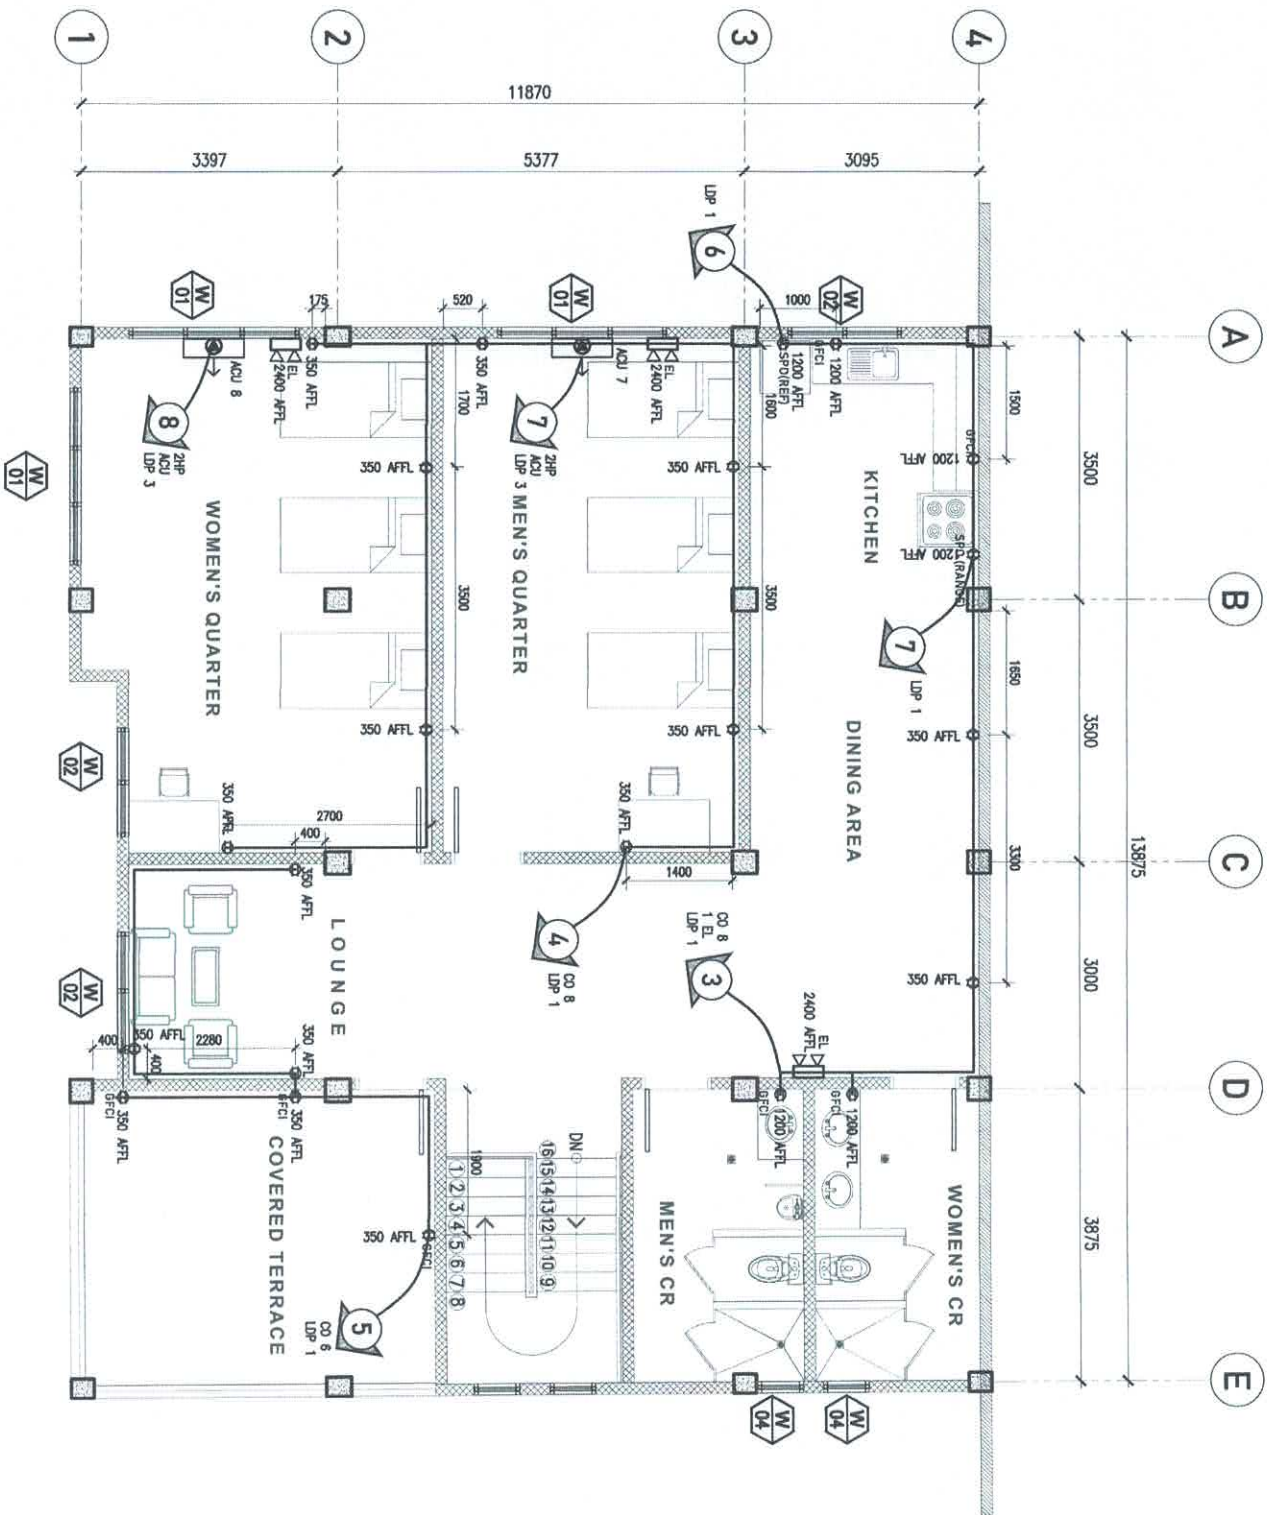

TERMINAL MANAGEMENT OFFICE BUILDING - SECOND FLOOR
POWER LAYOUT PLAN
1 SCALE
1:100mts

LEGEND (NOT DRAWN TO SCALE)	
SYMBOL	DESCRIPTION
	CIRCUIT BREAKER
	LOAD DISTRIBUTION PANEL
	MAIN DISTRIBUTION PANEL
WIRING	
	POWER LINE
	LIGHTING LINE
	SWITCH LINE
LIGHTING	
	TYPE: 20W ROUND LED RECESSED DOWNLIGHT IN WHITE ALUMINUM CASING AND CLEAR GLASS COVER, COB TYPE, IP40 RATED LIGHT COLOR: 6500K, DAYLIGHT QUANTITY: 13
	TYPE: 12W ROUND LED RECESSED DOWNLIGHT IN WHITE ALUMINUM CASING AND CLEAR GLASS COVER, COB TYPE, IP40 RATED LIGHT COLOR: 6500K, DAYLIGHT QUANTITY: 4
	TYPE: 15W ROUND LED RECESSED DOWNLIGHT IN WHITE ALUMINUM CASING AND CLEAR GLASS COVER, COB TYPE, IP40 RATED LIGHT COLOR: 6500K, WARM WHITE QUANTITY: 22
	TYPE: 20W ROUND LED RECESSED DOWNLIGHT IN WHITE ALUMINUM CASING AND CLEAR GLASS COVER, COB TYPE, IP40 RATED LIGHT COLOR: 6500K, WARM WHITE QUANTITY: 26
	TYPE: TWIN-HEAD EMERGENCY LIGHT LIGHT COLOR: COOL WHITE QUANTITY: 3
	TYPE: EXHAUST FAN QUANTITY: 2
	CEILING VENT PAINT COLOR: WHITE QUANTITY: 4
OUTLETS	
	TYPE: 3-PRONG DUPLEX CONVENIENCE OUTLET WITH GROUND
	TYPE: DUPLEX CONVENIENCE OUTLET WITH GROUND FAULT CIRCUIT INTERRUPTER (GFCI)
	TYPE: SPECIAL PURPOSE OUTLET
	AIR-CONDITIONING OUTLET

 PHILIPPINE PORTS AUTHORITY PORT MANAGEMENT OFFICE OF BICOL REGIONAL GOVERNMENT CENTER, RAVENS, LERZAPI CITY 4500	
PROJECT TITLE EMERGENCY MAINTENANCE OF ROOFING, CEILING AND ELECTRICAL SYSTEM AT TMO BUILDING PORT OF MATNOG, SORSOGON	SHEET NO. 10 16 AUGUST 04, 2025
PREPARED BY MA. JULIA A. SALDES, uap DRAFTSMAN IV	APPROVED MA. MAGNOLIA SINSON-REDOLO PORT MANAGER
CHECKED/REVIEWED BY CHRISTOPHER M. CADAG SUPERVISING ENGINEER A	
RECOMMENDING APPROVAL JOHN S. DE LOS SANTOS ACTING DIVISION MANAGER A, ESD	