


REPAIRING OF 4 UNITS - 120W LED STREETLIGHT
IP66 RATED (SEE DETAILS)

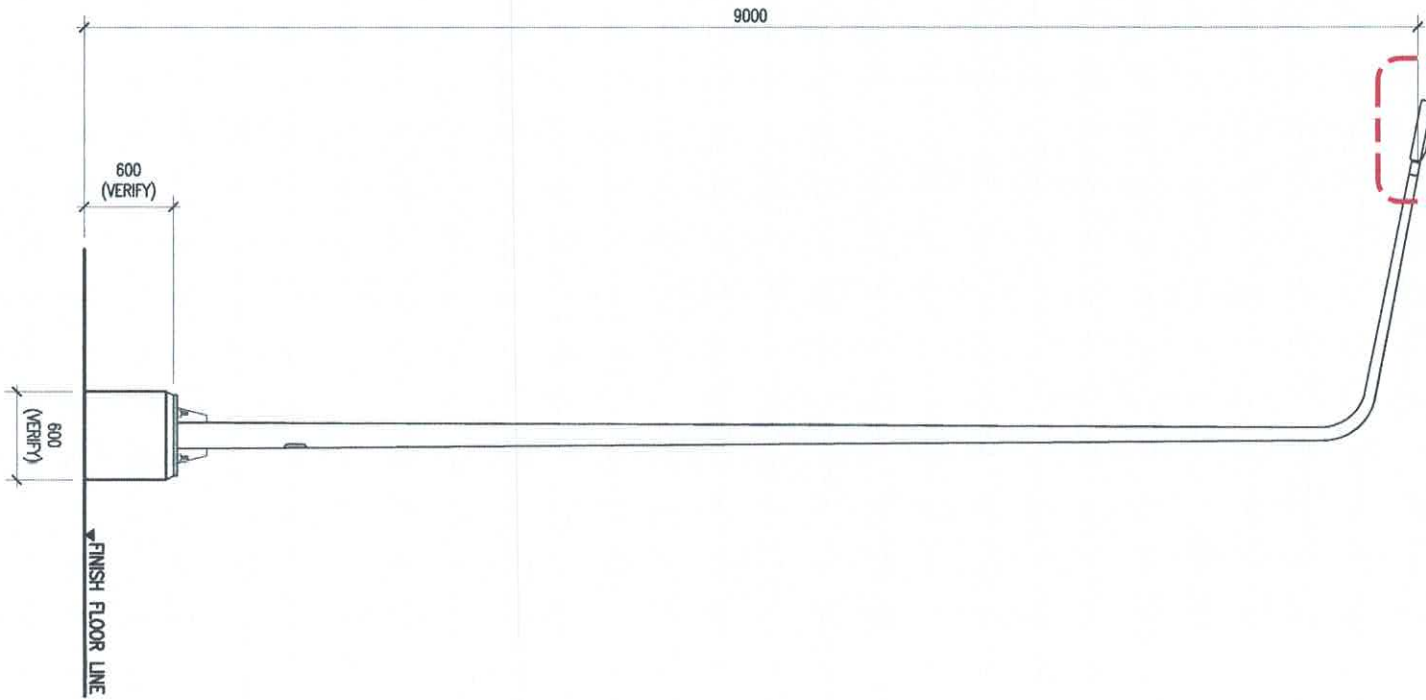


9 M.H.T. SINGLE ARM STEEL TAPERED LAMP POST
ELEVATION

1
SCALE

1:50mts

REPAIRING AND
REPLACEMENT OF
20 UNITS - FLOODLIGHT
LIGHTING FIXTURES

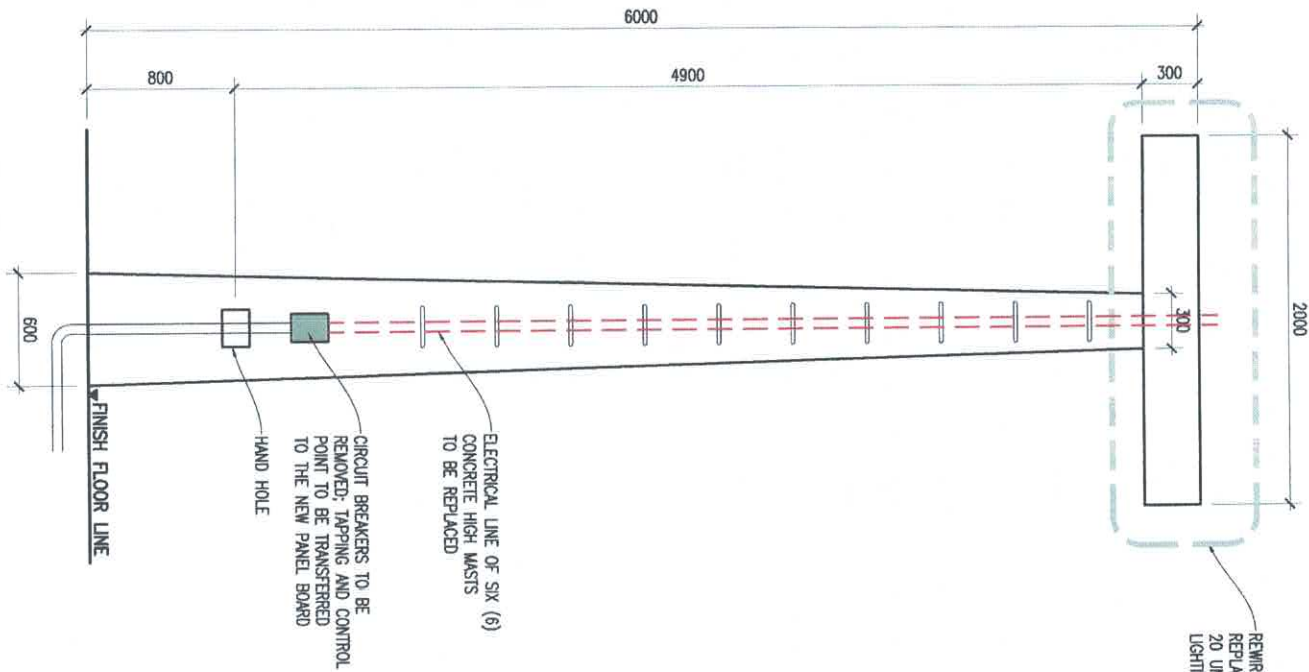


CONCRETE HIGH MAST
FRONT ELEVATION


2
SCALE

1:40mts

LED WEATHERPROOF FLOODLIGHT TECHNICAL SPECIFICATIONS:
POWER RATING: 200 WATTS
IP RATING: 65
BEAM ANGLE: 100 DEGREES
COLOR TEMPERATURE: 5500-6500K DAYLIGHT
MATERIAL: ALUMINUM REFLECTORS, STAINLESS STEEL PARTS
WITH TEMPERED GLASS COVER
QUANTITY: 20 UNITS

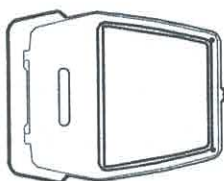

FRONT ELEVATION

 

SIDE ELEVATION

FLOODLIGHT FIXTURE

3
SCALE

NTS

PROJECT TITLE

EMERGENCY MAINTENANCE OF SEPTIC VAULT AND PORT LIGHTING SYSTEM
PORT OF VIRAC, CATANDUANES

SHEET NO.



PREPARED BY

AGAPITO LLOYD TALAY, uap

CHECKED/REVIEWED BY

CHRISTOPHER M. CADAG

RECOMMENDING APPROVAL

JOHN S. DE LOS SANTOS

APPROVED

MA. MAGNOLIA SINSON-REQUEJO

PORT MANAGEMENT OFFICE OF BICOL
REGIONAL GOVERNMENT CENTER,
RAVENS, LEGAZPI CITY 4500

ARCHITECT II

SUPERVISING ENGINEER A

ACTING DIVISION MANAGER A, ESD

PORT MANAGER

AUGUST 14, 2025

4
5