

**PHILIPPINE
PORTS
AUTHORITY**




PORT MANAGEMENT OFFICE - MARINDUQUE/QUEZON

CONSTRUCTION DRAWINGS

MAINTENANCE OF PASSENGER TERMINAL BUILDING

PORT OF SAN ANDRES


QUEZON

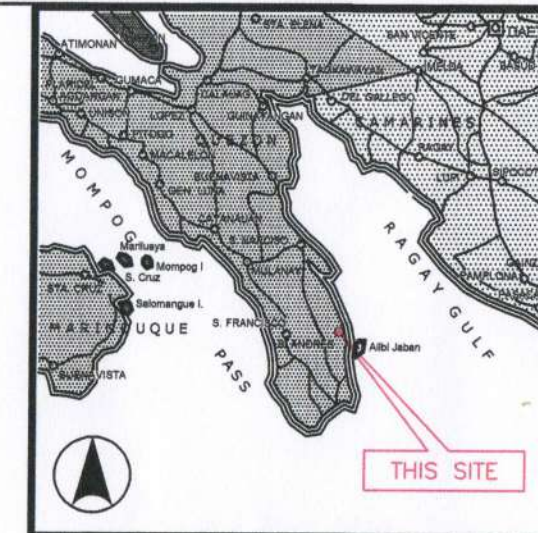

VICINITY MAP
NOT TO SCALE

MAINTENANCE OF PASSENGER TERMINAL BUILDING

- REPLACEMENT OF DAMAGED CANOPY
 - REMOVAL OF EXISTING DAMAGED CANOPY
 - SUPPLY, DELIVERY AND INSTALLATION OF MATERIALS FOR CANOPY
 - PAINTING WORKS
- REPLACEMENT OF DAMAGED ENTRANCE DOOR
 - SUPPLY, DELIVERY AND INSTALLATION OF ENTRANCE DOOR
- REPLACEMENT OF LED BULBS, FLUORESCENT TUBES AND EMERGENCY LIGHTS
 - SUPPLY, DELIVERY AND INSTALLATION OF LED BULBS, FLUORESCENT TUBES AND EMERGENCY LIGHTS
- MAINTENANCE OF COMFORT ROOM AND PLUMBING SYSTEM
 - REPLACEMENT OF TOILET FIXTURES, WATER SUPPLY SYSTEM AND TOILET PARTITION SUPPORT LEGS

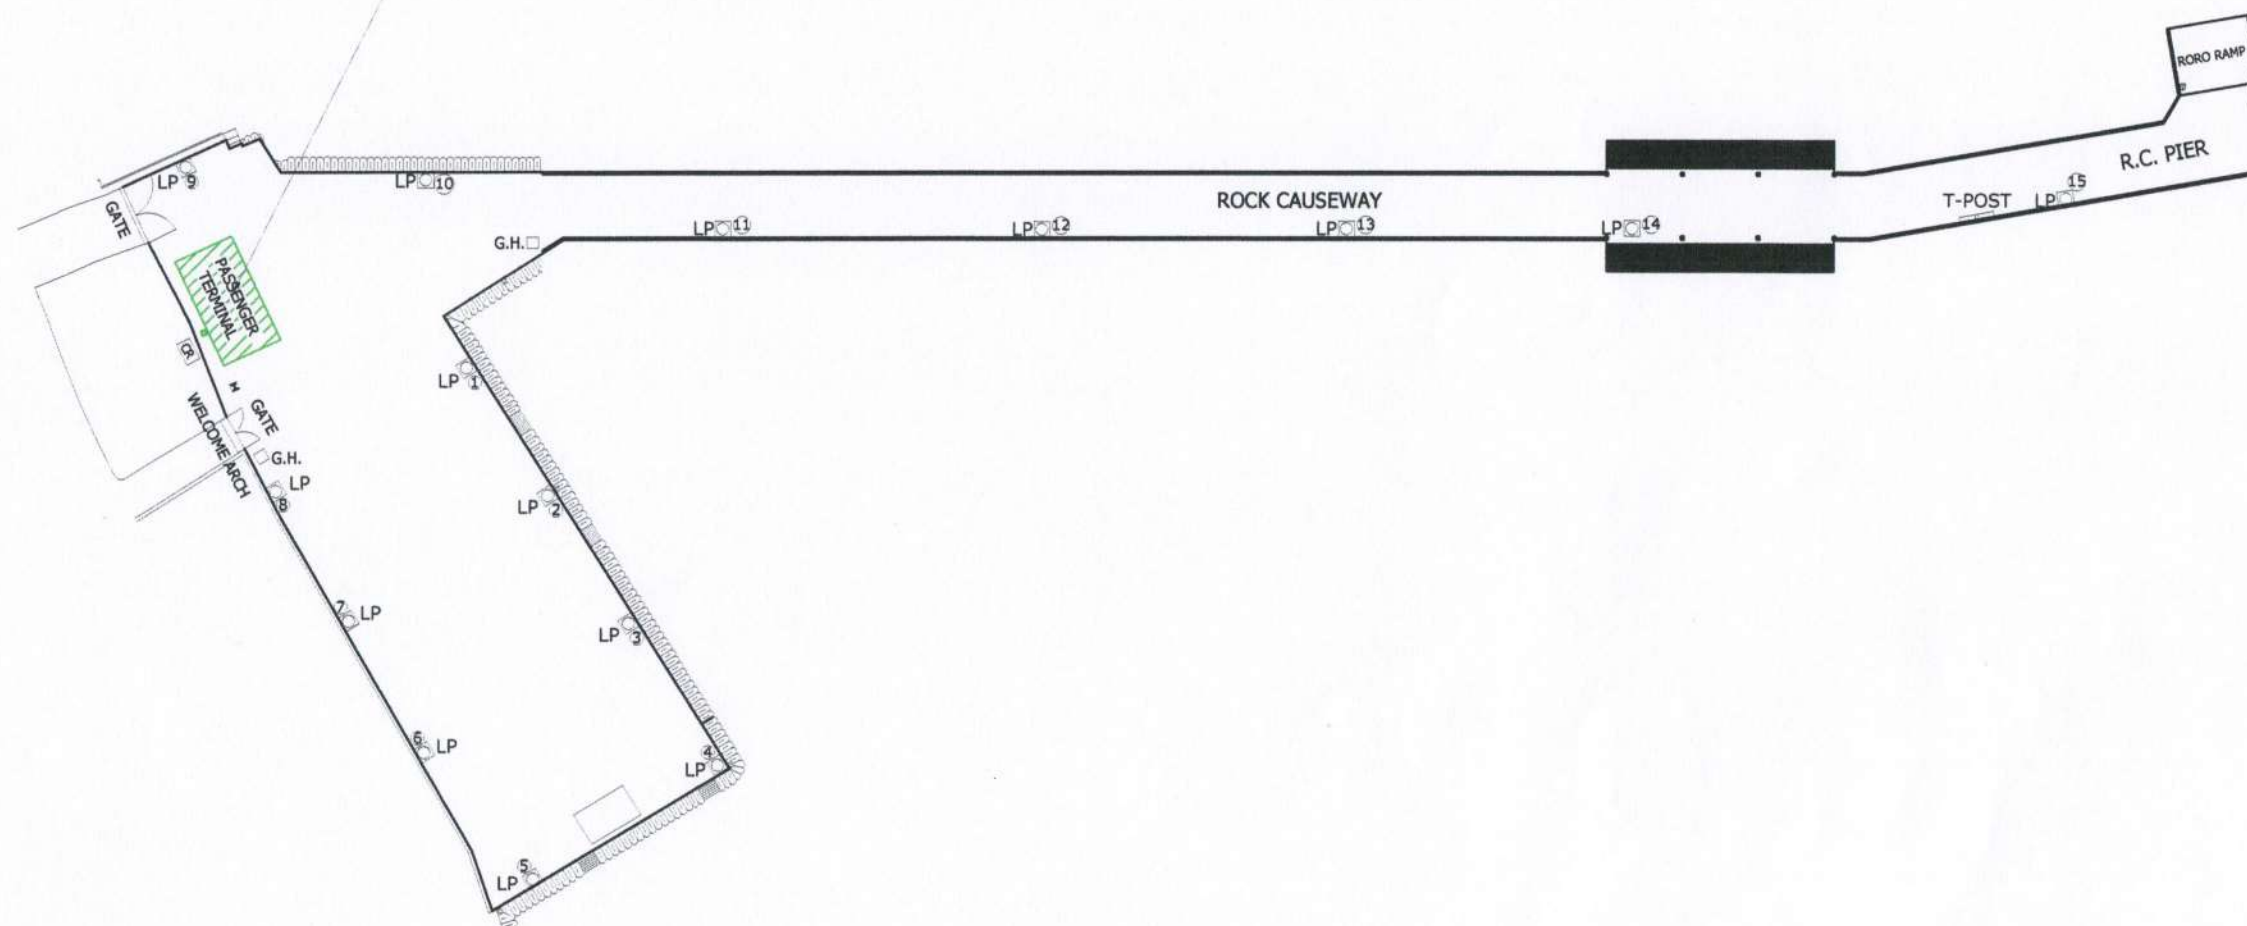

DEVELOPMENT PLAN
SCALE 1:1000



PORT MANAGEMENT OFFICE - MARQUEZ

PROJECT/LOCATION:

MAINTENANCE OF
PASSENGER TERMINAL BUILDING

PORT OF SAN ANDRES

PREPARED BY:

QUEZON

JOHN PAULO M. GONZALES
ACTING SENIOR ENGINEER A

CHECKED/REVIEWED BY:

GERLIE D. TABOCO
PRINCIPAL ENGINEER A

RECOMMENDING APPROVAL:

RAULYA. LIBATIQUE
ESD MANAGER

APPROVED:


ANNA THERESA M. BISCOCHO
ACTING PORT MANAGER

SHEET CONTENTS

- VICINITY MAP
- DEVELOPMENT PLAN


SHEET NO.

1 / 5

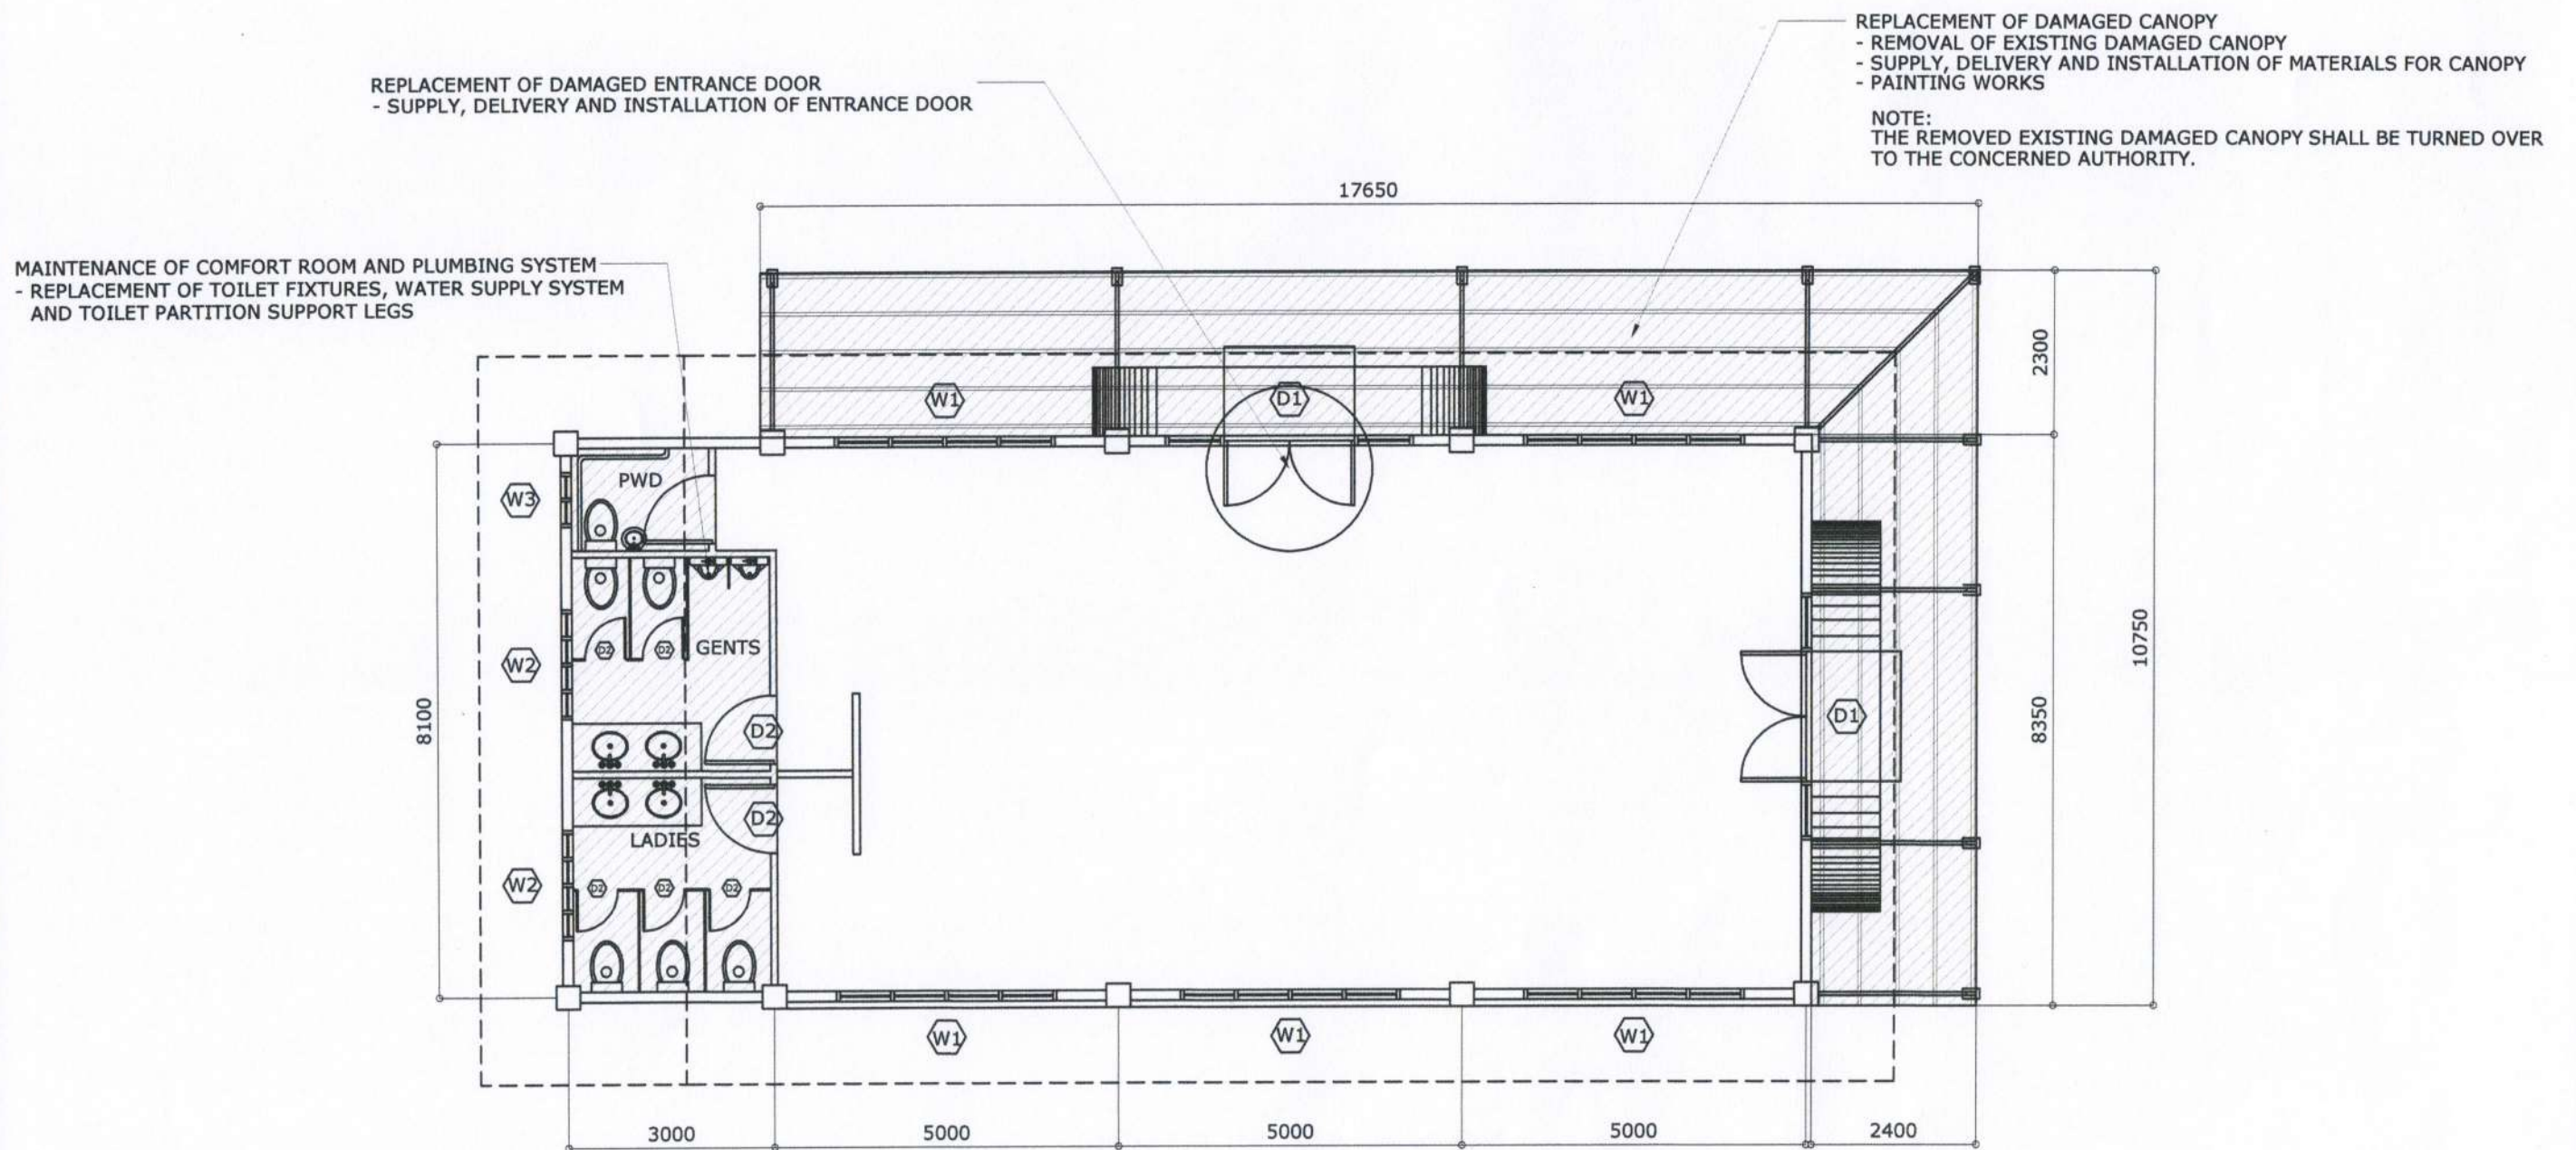

EXISTING PLAN OF PTB

 SCALE 1:100

 PHILIPPINE PORTS AUTHORITY PORT MANAGEMENT OFFICE - MARQUEZ	PROJECT/LOCATION:	PREPARED BY:	CHECKED/REVIEWED BY:	RECOMMENDING APPROVAL:	APPROVED:	SHEET CONTENTS	SHEET NO.
	MAINTENANCE OF PASSENGER TERMINAL BUILDING PORT OF SAN ANDRES QUEZON	 JOHN PAULO M. GONZALES ACTING SENIOR ENGINEER A	 GERLIE D. TABOCO PRINCIPAL ENGINEER A	 RAUL A. LIBATIQUE ESD MANAGER	 ANNA THERESA M. BISCOCHO ACTING PORT MANAGER	• EXISTING PLAN OF PTB	2 / 5

REPLACEMENT OF DAMAGED CANOPY
 - REMOVAL OF EXISTING DAMAGED CANOPY
 - SUPPLY, DELIVERY AND INSTALLATION OF MATERIALS FOR CANOPY
 - PAINTING WORKS

FOOTING:
 • 250MM X 250MM X 1/2" BASE PLATE
 W/ 4 - 5/8" x 4" EXPANSION BOLTS
COLUMN:
 • 4" G.I. PIPE (SCH. 40)
 - FULL WELD TO BASE PLATE

GIRT:
 • 2" X 4" X 2MM TUBULAR
 W/ 5/8" x 4" EXPANSION BOLTS
 SPACED AS SHOWN


BEAM:
 • 3" G.I. PIPE (SCH. 40)
 - FULL WELD TO COLUMN

RAFTER:
 • 2" X 6" X 2MM TUBULAR

USE: 3" X 3" X 2" X 6MM ANGLE BAR CLIP
 BEAM - RAFTER CONNECTION - FULL WELD (BOTH SIDES)
 (SEE DETAIL)
 2" X 2" X 2" X 6MM ANGLE BAR CLIP
 RAFTER - BEAM CONNECTION - FULL WELD
 (SEE DETAIL)


CLASSIC RIB ROOF IN PREPAINTED FINISH
 1.07MM WIDTH X 0.60MM THK. X 10 FT.

PURLIN:
 • 2" X 3" X 2MM TUBULAR


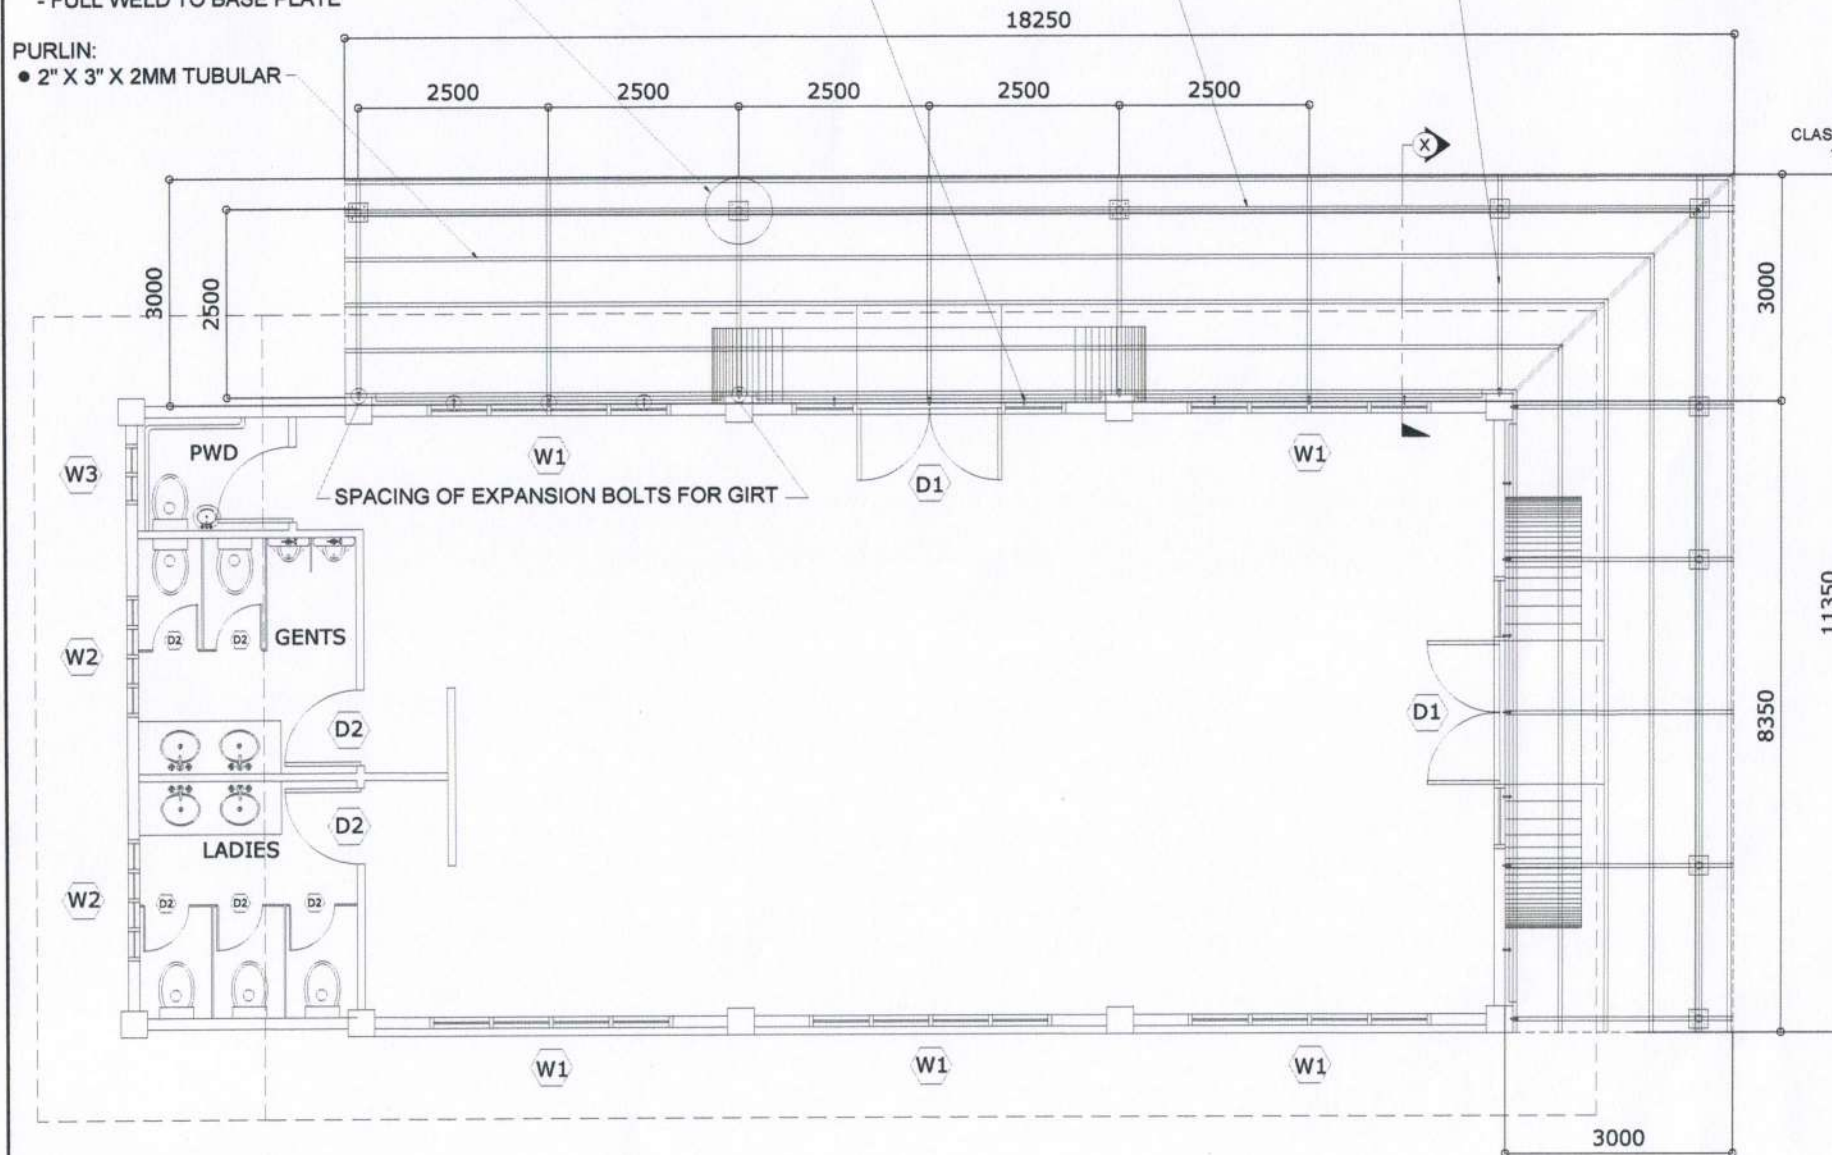


- NOTES:**
- ALL END CUTS OF TUBULAR AND G.I. PIPE MUST BE COVERED
 - ALL TUBULAR, G.I., AND BASE PLATES SHALL BE PAINTED WITH DOUBLE COAT EPOXY PAINT FINISH.

CANOPY PLAN
 SCALE 1:100

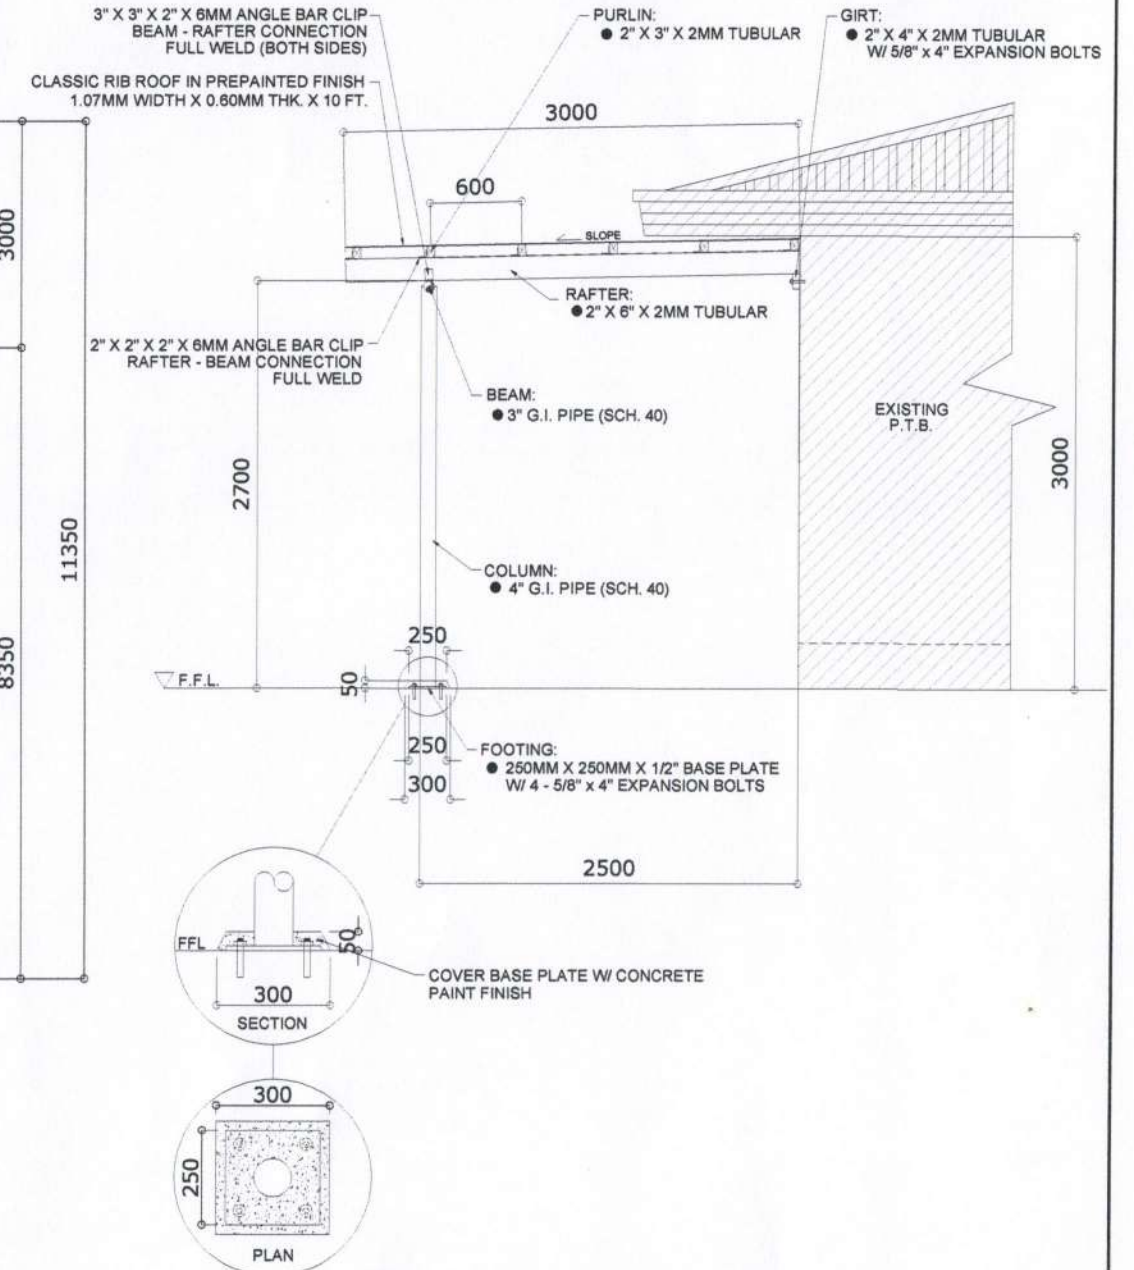


DETAIL OF CANOPY
 SCALE 1:50

   PHILIPPINE PORTS AUTHORITY PORT MANAGEMENT OFFICE - MARQUEZ	PROJECT/LOCATION: MAINTENANCE OF PASSENGER TERMINAL BUILDING PORT OF SAN ANDRES QUEZON	PREPARED BY:  JOHN PAULO M. GONZALES ACTING SENIOR ENGINEER A	CHECKED/REVIEWED BY:  GERLIE D. TABACO PRINCIPAL ENGINEER A	RECOMMENDING APPROVAL:  PAULA A. LIBATIQUE ESD MANAGER	APPROVED:  ANNA THERESA M. BISCOCHO ACTING PORT MANAGER	SHEET CONTENTS • CANOPY PLAN • DETAIL OF CANOPY	SHEET NO. 3 / 5
---	--	---	---	--	---	---	---------------------------

REPLACEMENT OF LED BULBS, FLUORESCENT TUBES AND EMERGENCY LIGHTS
- SUPPLY, DELIVERY AND INSTALLATION OF LED BULBS, FLUORESCENT TUBES AND EMERGENCY LIGHTS


REPLACEMENT OF DAMAGED ENTRANCE DOOR
- SUPPLY, DELIVERY AND INSTALLATION OF ENTRANCE DOOR

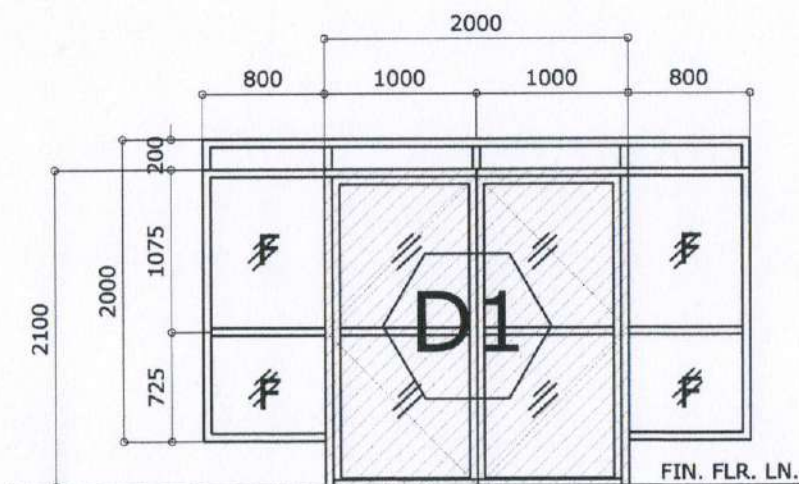

TYPE: ANALOK ALUMINUM FRAMED
W/ FIXED GLASS SWING OUT DOOR
REQ'D: ONE (1) SET OF 2.00M x 2.10M

SCHEDULE OF ENTRANCE DOOR
SCALE 1:20

LED AUTOMATIC EMERGENCY LIGHT 2X, 1 WATT, 6 HOURS
INSTALL: 4 SETS

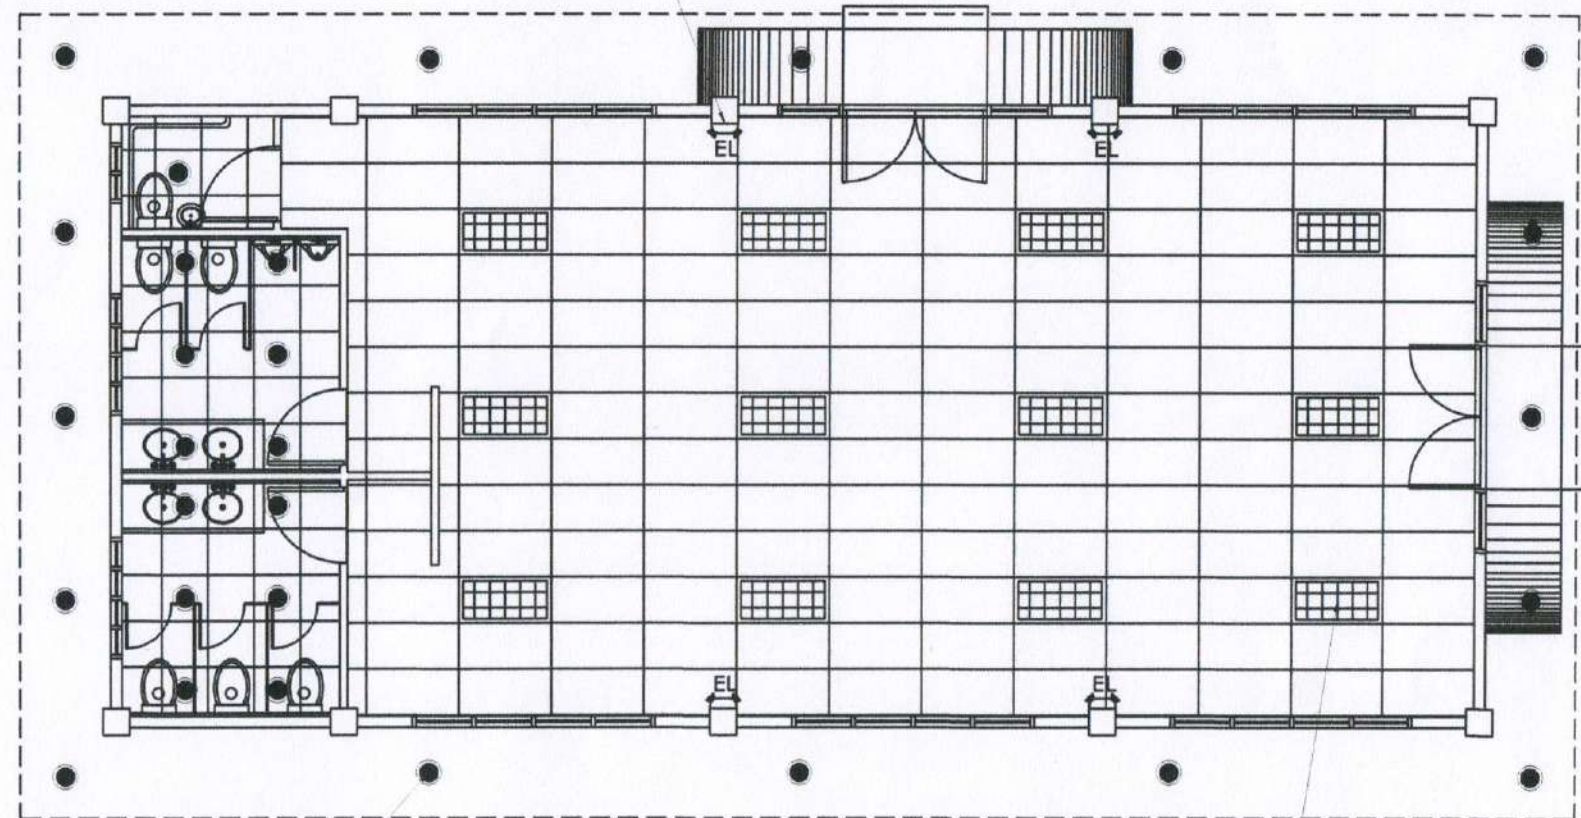


15W, E-27 LED BULB (DAYLIGHT)
INSTALL: 29 PCS.

18W, T8, FLUORESCENT TUBE (DAYLIGHT)
INSTALL: 24 PCS.

REFLECTED CEILING PLAN
SCALE 1:100

PHILIPPINE PORTS AUTHORITY PORT MANAGEMENT OFFICE - MARQUEZ	PROJECT/LOCATION: MAINTENANCE OF PASSENGER TERMINAL BUILDING PORT OF SAN ANDRES QUEZON	PREPARED BY: <i>[Signature]</i> JOHN PAULO M. GONZALES ACTING SENIOR ENGINEER A	CHECKED/REVIEWED BY: <i>[Signature]</i> GERLIE D. TABOCO PRINCIPAL ENGINEER A	RECOMMENDING APPROVAL: <i>[Signature]</i> RAUL A. LIBATIQUE ESD MANAGER	APPROVED: <i>[Signature]</i> ANNA TERESA M. BISCOCHO ACTING PORT MANAGER	SHEET CONTENTS • SCHEDULE OF ENTRANCE DOOR • REFLECTED CEILING PLAN	SHEET NO. 4 / 5
---	--	---	---	---	--	---	--------------------------------------

MAINTENANCE OF COMFORT ROOM AND PLUMBING SYSTEM
- REPLACEMENT OF TOILET FIXTURES, WATER SUPPLY SYSTEM AND TOILET PARTITION SUPPORT LEGS

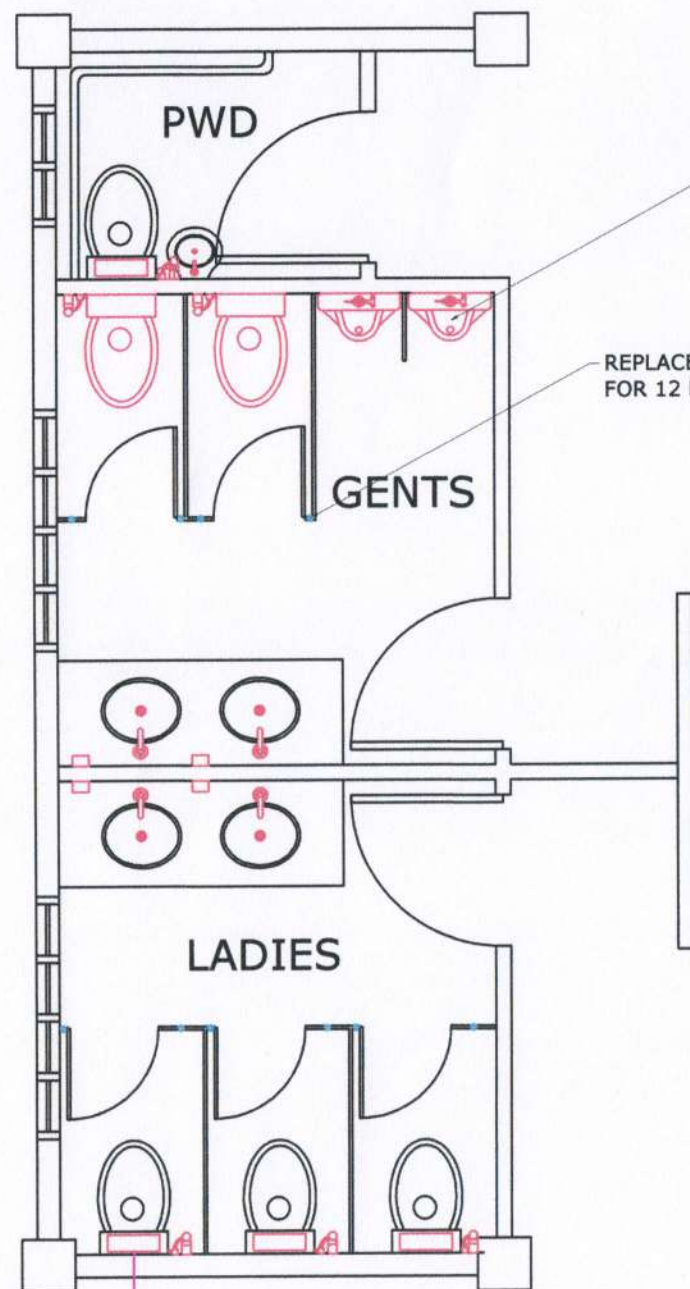

MAINTENANCE OF COMFORT ROOM AND PLUMBING SYSTEM
PWD

FOR REPLACEMENT:

FOR WATER CLOSET:

- UNIVERSAL WATER SAVER FLUSH, DUAL FLUSH BUTTON 1 SET
- STAINLESS BIDET SPRAY 1 SET
- THREE WAY ANGLE VALVE, STAINLESS STEEL 304 1 PC.
- STAINLESS FLEXIBLE ANGLE VALVE HOSE 1 PC.

FOR LAVATORY:

- COLD LINE LAVATORY FAUCET, GOOSENECK, STAINLESS STEEL 304 1 PC.
- STAINLESS LAVATORY P-TRAP SET 1 SET
- TWO WAY ANGLE VALVE, STAINLESS 304 1 PC.
- STAINLESS FLEXIBLE ANGLE VALVE HOSE 1 PC.
- LIQUID SOAP DISPENSER, PLASTIC 1 PC.

GENTS

FOR REPLACEMENT:

FOR WATER CLOSET:

- TWO PIECE WATER CLOSET 2 SETS
- STAINLESS BIDET SPRAY 2 SETS
- THREE WAY ANGLE VALVE, STAINLESS STEEL 304 2 PCS.
- STAINLESS FLEXIBLE ANGLE VALVE HOSE 2 PCS.

FOR URINAL:

- WALL HUNG TOP INLET URINAL 2 SETS
- STAINLESS URINAL FLUSH VALVE (PUSH BUTTON TYPE) 2 SETS

FOR LAVATORY:

- COLD LINE LAVATORY FAUCET, GOOSENECK, STAINLESS STEEL 304 2 PCS.
- STAINLESS LAVATORY P-TRAP SET 2 SETS
- TWO WAY ANGLE VALVE, STAINLESS 304 2 PCS.
- STAINLESS FLEXIBLE ANGLE VALVE HOSE 2 PCS.

LADIES


FOR REPLACEMENT:

FOR WATER CLOSET:

- UNIVERSAL WATER SAVER FLUSH, DUAL FLUSH BUTTON 3 SETS
- STAINLESS BIDET SPRAY 3 SETS
- THREE WAY ANGLE VALVE, STAINLESS STEEL 304 3 PCS.
- STAINLESS FLEXIBLE ANGLE VALVE HOSE 3 PCS.

FOR LAVATORY:

- COLD LINE LAVATORY FAUCET, GOOSENECK, STAINLESS STEEL 304 2 PCS.
- STAINLESS LAVATORY P-TRAP SET 2 SETS
- TWO WAY ANGLE VALVE, STAINLESS 304 2 PCS.
- STAINLESS FLEXIBLE ANGLE VALVE HOSE 2 PCS.
- LIQUID SOAP DISPENSER, PLASTIC 2 PCS.

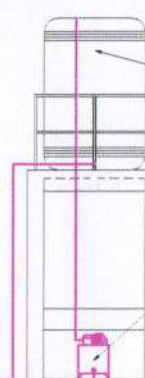

1/2" FLOAT VALVE / PVC PLASTIC FLOAT BALL VALVE FOR WATER TANK

1 HP WATER PUMP W/ 21 GALS. STAINLESS STEEL PRESSURE TANK (COMPLETE W/ PRESSURE SWITCH AND GAUGE)

 
FROM WATER TANK
PPR PN20 25MM (3/4") X 4M

FROM WATER SOURCE OUTSIDE PPA
PPR PN20 25MM (3/4") X 4M

COMFORT ROOM AND PLUMBING SYSTEM PLAN

SCALE

NTS

 PHILIPPINE PORTS AUTHORITY PORT MANAGEMENT OFFICE - MARQUEZ	PROJECT/LOCATION: MAINTENANCE OF PASSENGER TERMINAL BUILDING PORT OF SAN ANDRES QUEZON	PREPARED BY:  JOHN PAULO M. GONZALES ACTING SENIOR ENGINEER A	CHECKED/REVIEWED BY:  GERLIE D. TABOCO PRINCIPAL ENGINEER A	RECOMMENDING APPROVAL:  RAUL A. LIBATIQUE ESD MANAGER	APPROVED:  ANNA THERESA A. BISCOCHO ACTING PORT MANAGER	SHEET CONTENTS • COMFORT ROOM AND PLUMBING SYSTEM PLAN	SHEET NO. 5 / 5
--	---	---	---	---	---	---	---------------------------