

**PHILIPPINE
PORTS
AUTHORITY**



PORT MANAGEMENT OFFICE - MARINDUQUE/QUEZON

CONSTRUCTION DRAWINGS


**EMERGENCY MAINTENANCE OF
COMFORT ROOMS AT
PASSENGER TERMINAL BUILDING**

PORT OF LUCENA


LUCENA CITY




VICINITY MAP
SCALE NTS

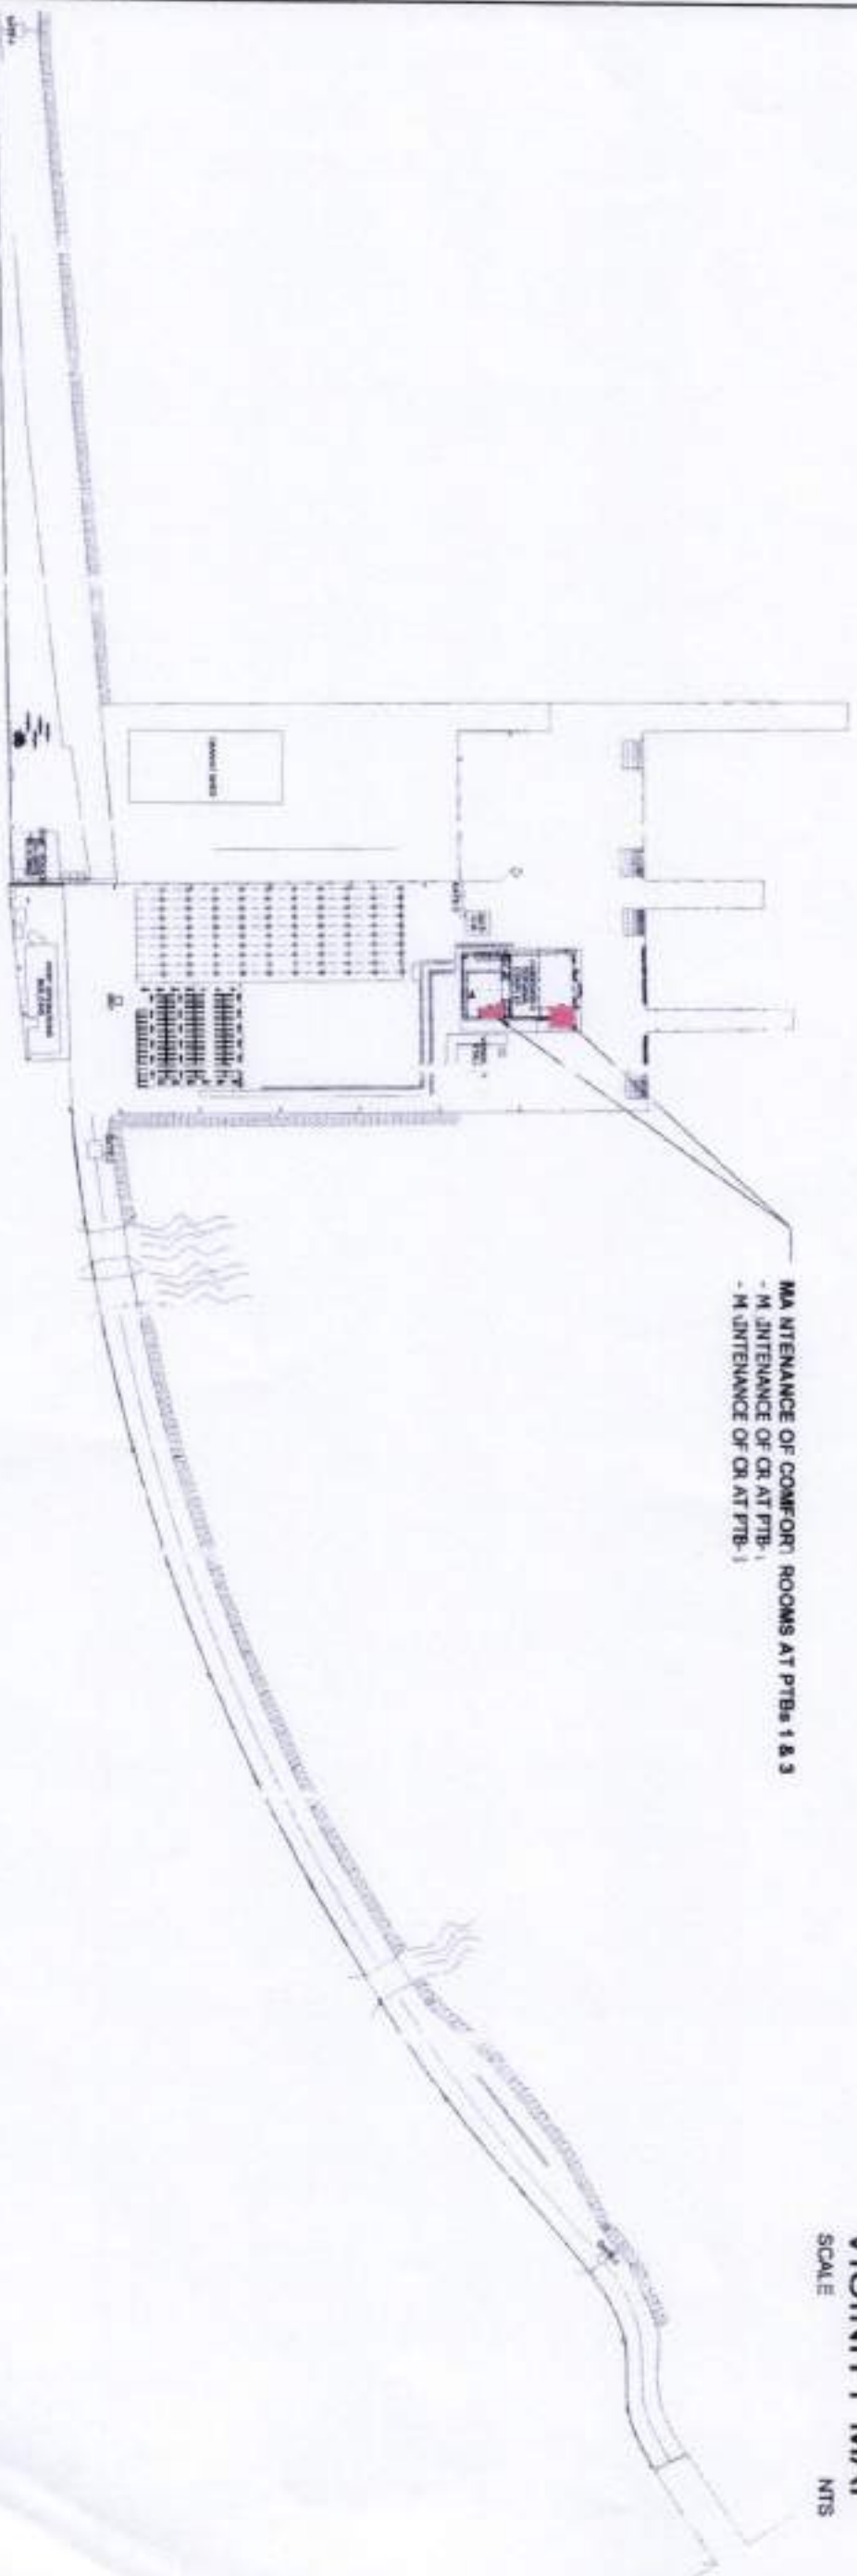

DEVELOPMENT PLAN

  PHILIPPINE PORTS AUTHORITY PORT MANAGEMENT OFFICE - MANILA	PROJECT/LOCATION: EMERGENCY MAINTENANCE OF COMFORT ROOMS AT PASSENGER TERMINAL BUILDING PORT OF LUCENA LUCENA CITY	PREPARED BY:  MARK ANDREW S. PINEDA ACTING SUPERVISING ENGINEER A	CHECKED/REVIEWED BY:  GENELLE D. T. ASIDO PRINCIPAL ENGINEER A	RECOMMENDED BY:  RAUL A. LIBATIQUE EST. MANAGER	APPROVED BY:  ANNA THERESA A. BISCOCHO PORT MANAGER	SHEET CONTENT: • DEVELOPMENT PLAN 1 / 7
--	---	--	---	--	--	--

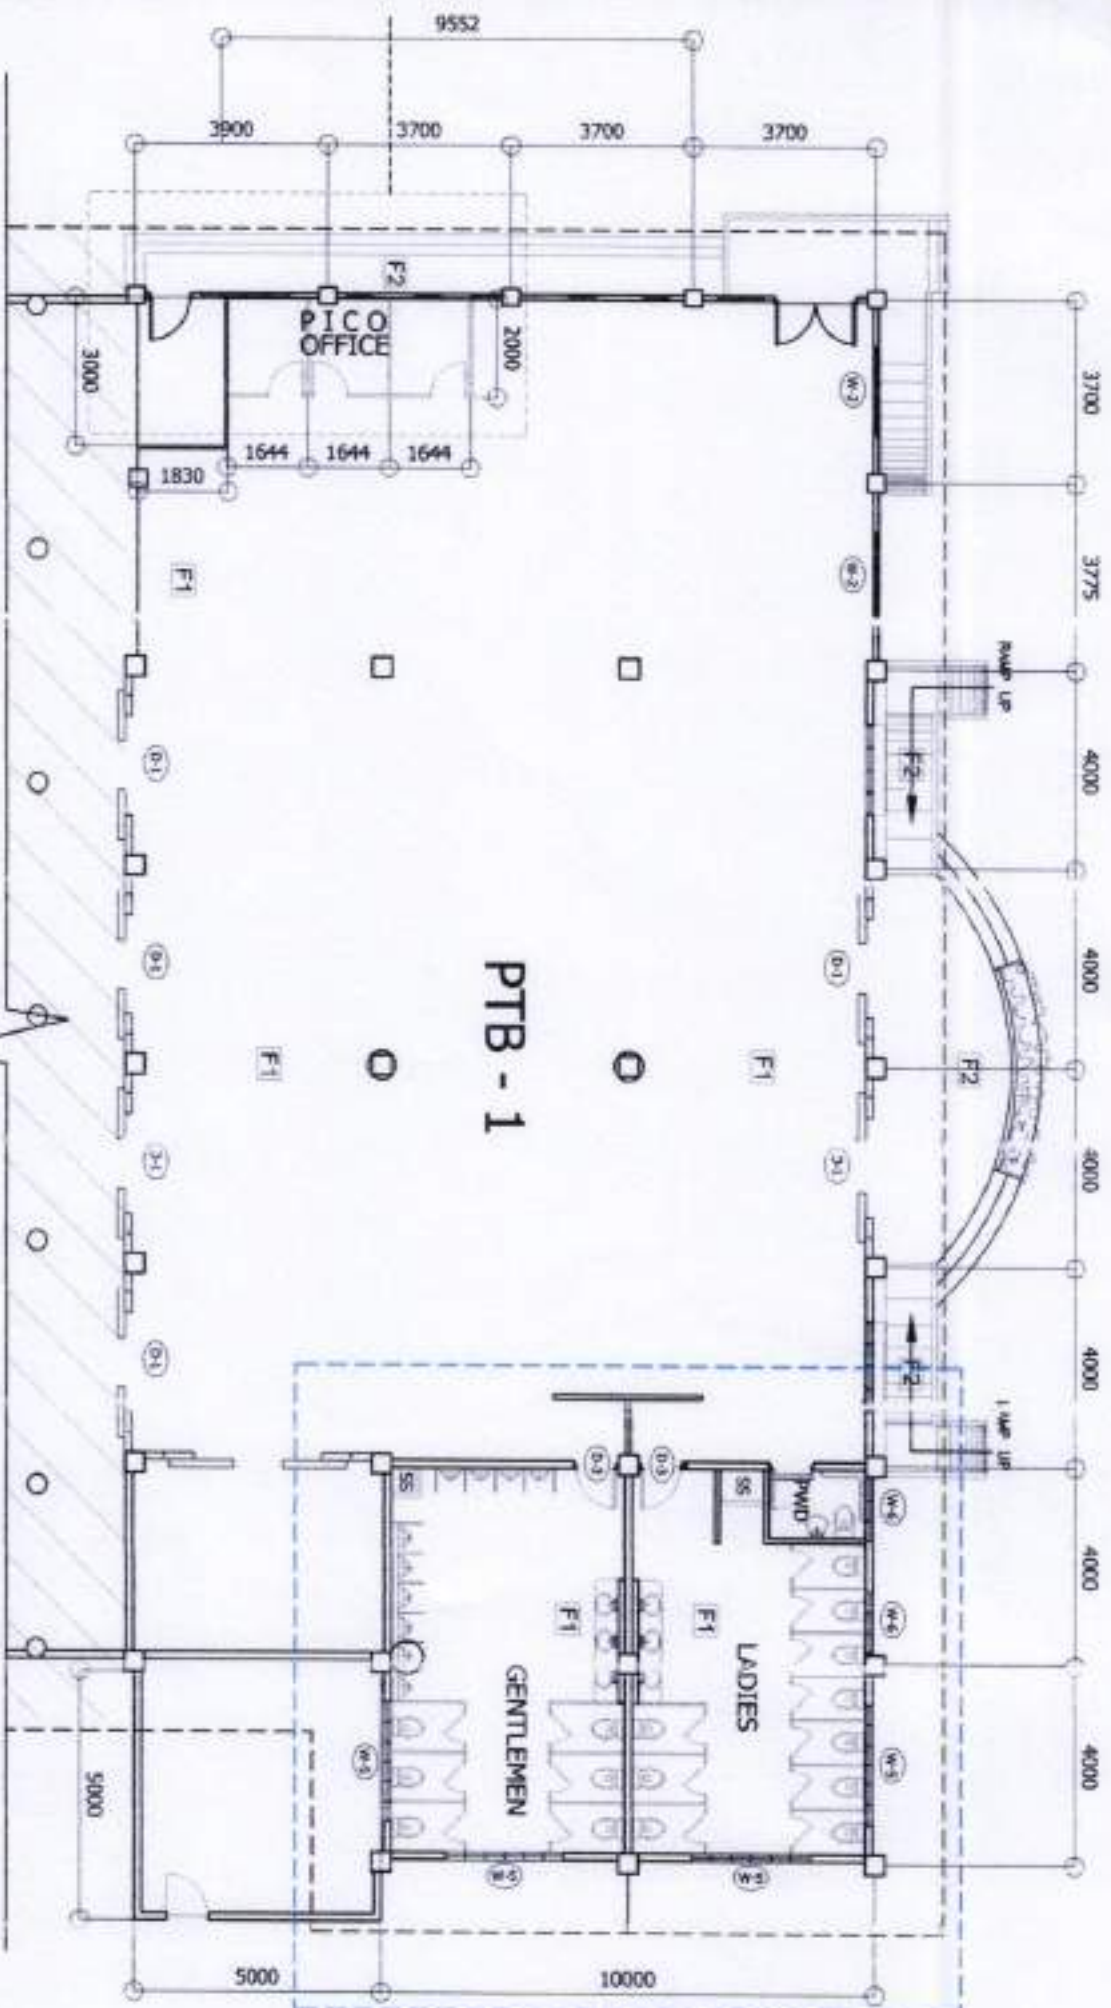

PTB - 1

GROUND FLOOR PLAN

SCALE 1:150

PWD COMFORT ROOM

- REPLACEMENT OF ONE (1) SET OF WATER TANK FITTINGS (LEVER TYPE) & ACCESSORIES, INCLUDING TOILET SEAT & COVER, ANGLE VALVE AND STAINLESS FLEXIBLE SUPPLY PIPE
- REPLACEMENT OF ONE (1) SET STAINLESS BIDET HOSE (SPRAY)
- REPLACEMENT OF ONE (1) SET STAINLESS FAUCET FOR LAVATORY, INCLUDING ANGLE VALVES, STAINLESS FLEXIBLE SUPPLY PIPES AND P-TRAP
- REPLACEMENT OF CEILING, PERFORATED PANELS, 2' x 2' x 0.70mm thk., BONE WHITE, OR EQUIVALENT = 3.00 SQ. METERS
- REPLACEMENT OF ONE (1) SET OF WALL MOUNTED LUCID SOAP DISPENSER
- REPLACEMENT OF ONE (1) SET DOWNLIGHT RECESSED MOUNTED W/ 1-11W LED PINLIGHT E27

LADIES' COMFORT ROOM

- REPLACEMENT OF TEN (10) SETS OF WATER TANK FITTINGS (LEVER TYPE) & ACCESSORIES, INCLUDING TOILET SEAT & COVER, ANGLE VALVE AND STAINLESS FLEXIBLE SUPPLY PIPE
- REPLACEMENT OF TEN (10) SETS, STAINLESS BIDET HOSE (SPRAY)
- REPLACEMENT OF THREE (3) SETS STAINLESS FAUCET FOR LAVATORY, INCLUDING ANGLE VALVES, STAINLESS FLEXIBLE SUPPLY PIPES AND P-TRAP
- REPLACEMENT OF CEILING, PERFORATED PANELS, 2' x 2' x 0.70mm thk., BONE WHITE, OR EQUIVALENT = 33.50 SQ. METERS
- REPLACEMENT OF ONE (1) PC SERVICE FAUCETS FOR SLOP SINK
- REPLACEMENT OF TWO (2) SETS OF WALL MOUNTED LIQUID SOAP DISPENSER
- REPLACEMENT OF ONE (1) SET OF AUTOMATIC HAND DRYER
- REPLACEMENT OF ONE (1) SET OF WALL MOUNTED JUMBO ROLL TOILET PAPER DISPENSER
- REPLACEMENT OF ONE (1) SET DOWNLIGHT RECESSED MOUNTED W/ 1-11W LED PINLIGHT E27
- REPLACEMENT OF TWO (2) SETS OF WINDOW TYPE EXHAUST FAN 12"

GENTLEMEN'S COMFORT ROOM

- REPLACEMENT OF SIX (6) SETS OF WATER TANK FITTINGS (LEVER TYPE) & ACCESSORIES, INCLUDING TOILET SEAT & COVER, ANGLE VALVE AND STAINLESS FLEXIBLE SUPPLY PIPE
- REPLACEMENT OF SIX (6) SETS, STAINLESS BIDET HOSE (SPRAY)
- REPLACEMENT OF THREE (3) SETS STAINLESS FAUCET FOR LAVATORY, INCLUDING ANGLE VALVES, STAINLESS FLEXIBLE SUPPLY PIPES AND P-TRAP
- REPLACEMENT OF CEILING, PERFORATED PANELS, 2' x 2' x 0.70mm thk., BONE WHITE, OR EQUIVALENT = 33.50 SQ. METERS
- REPLACEMENT OF ONE (1) SET URINAL BOWL WITH COMPLETE FITTINGS AND ACCESSORIES.
- REPLACEMENT OF TEN (10) SETS URINAL FLUSH VALVE WITH COMPLETE FITTINGS
- REPLACEMENT OF ONE (1) PC SERVICE FAUCETS FOR SLOP SINK
- REPLACEMENT OF TWO (2) SETS OF WALL MOUNTED LIQUID SOAP DISPENSER
- REPLACEMENT OF ONE (1) SET OF AUTOMATIC HAND DRYER
- REPLACEMENT OF ONE (1) SET OF WALL MOUNTED JUMBO ROLL TOILET PAPER DISPENSER
- REPLACEMENT OF THREE (3) SETS DOWNLIGHT RECESSED MOUNTED W/ 1-11W LED PINLIGHT E27
- REPLACEMENT OF TWO (2) SETS OF WINDOW TYPE EXHAUST FAN 12"

PROJECT/LOCATION:

EMERGENCY MAINTENANCE OF
COMFORT ROOMS AT PASSENGER
TERMINAL BUILDING

PREPARED BY:

MARK ANDREW S. PINEDA
REGISTERED ELECTRICAL ENGINEER A

CHECKED/REVIEWED BY:

GERALD D. TABOCCO
REGISTERED ELECTRICAL ENGINEER A

RECOMMENDED BY:

RAJUL A. LIBATONG
EST. MANAGER


APPROVED BY:

ANITA T. BISCOCCIO
PORT MANAGER


SHEET COUNT:

GROUND FLOOR PLAN

217

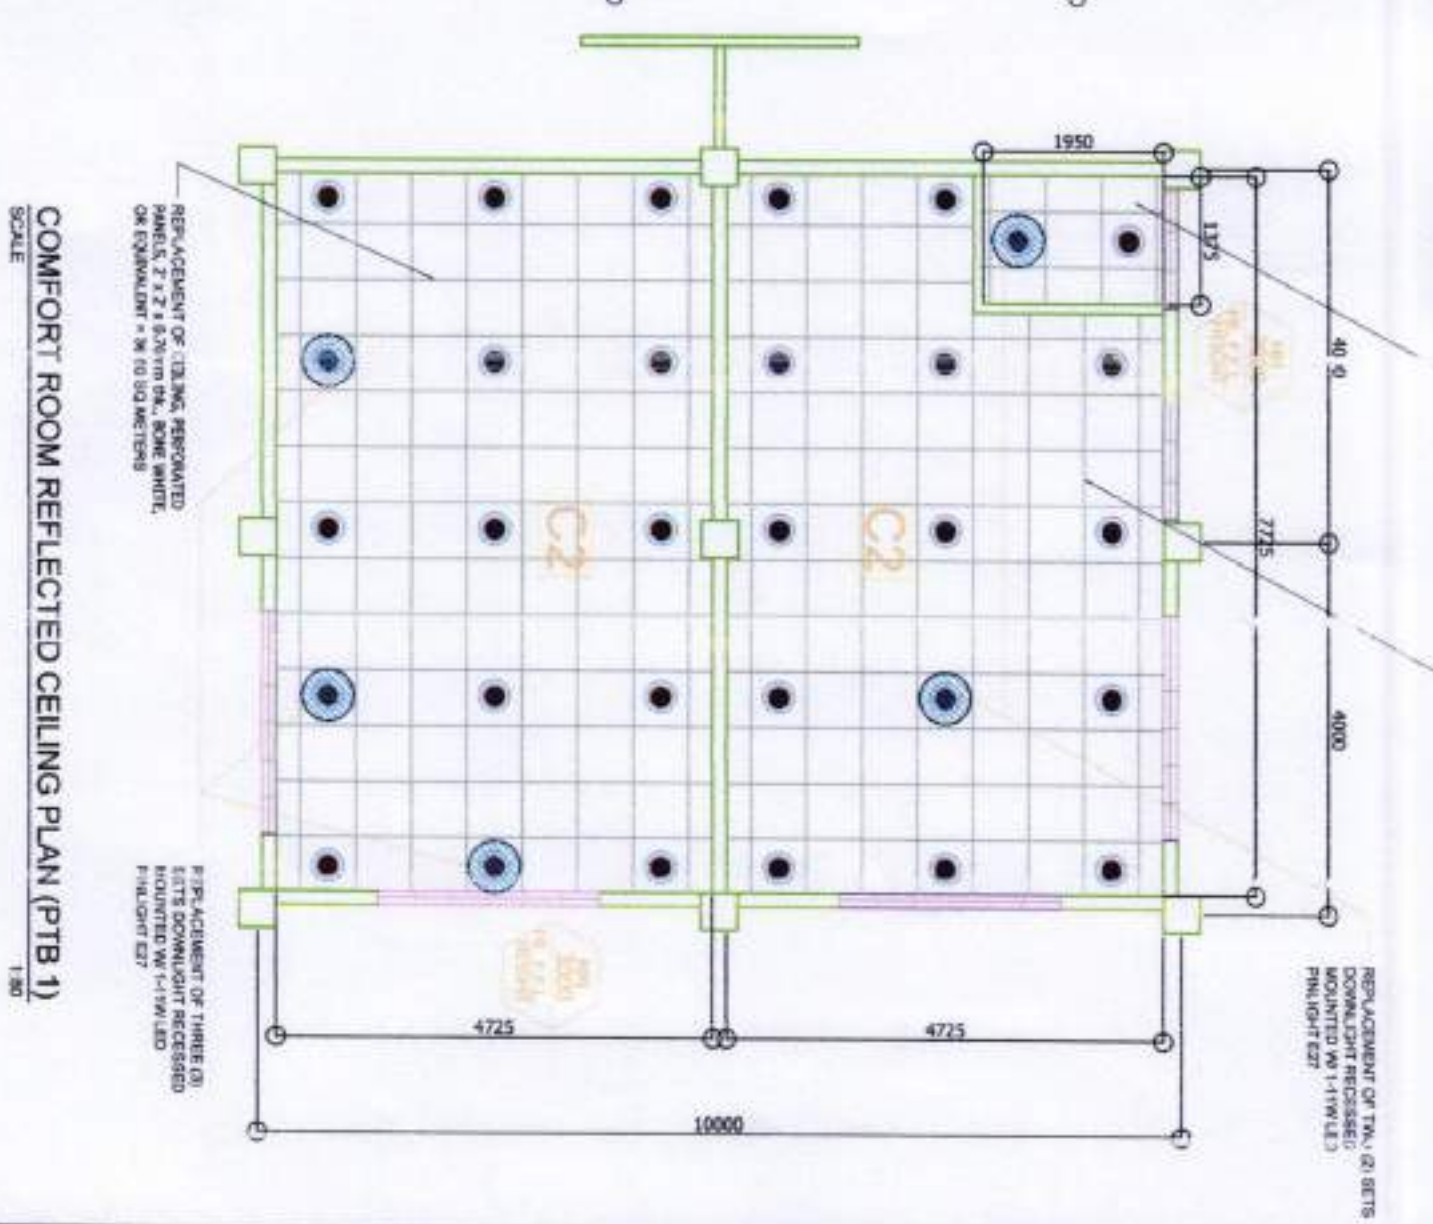

COMFORT ROOM REFLECTED CEILING PLAN (PTB 1)
SCALE 1/32"

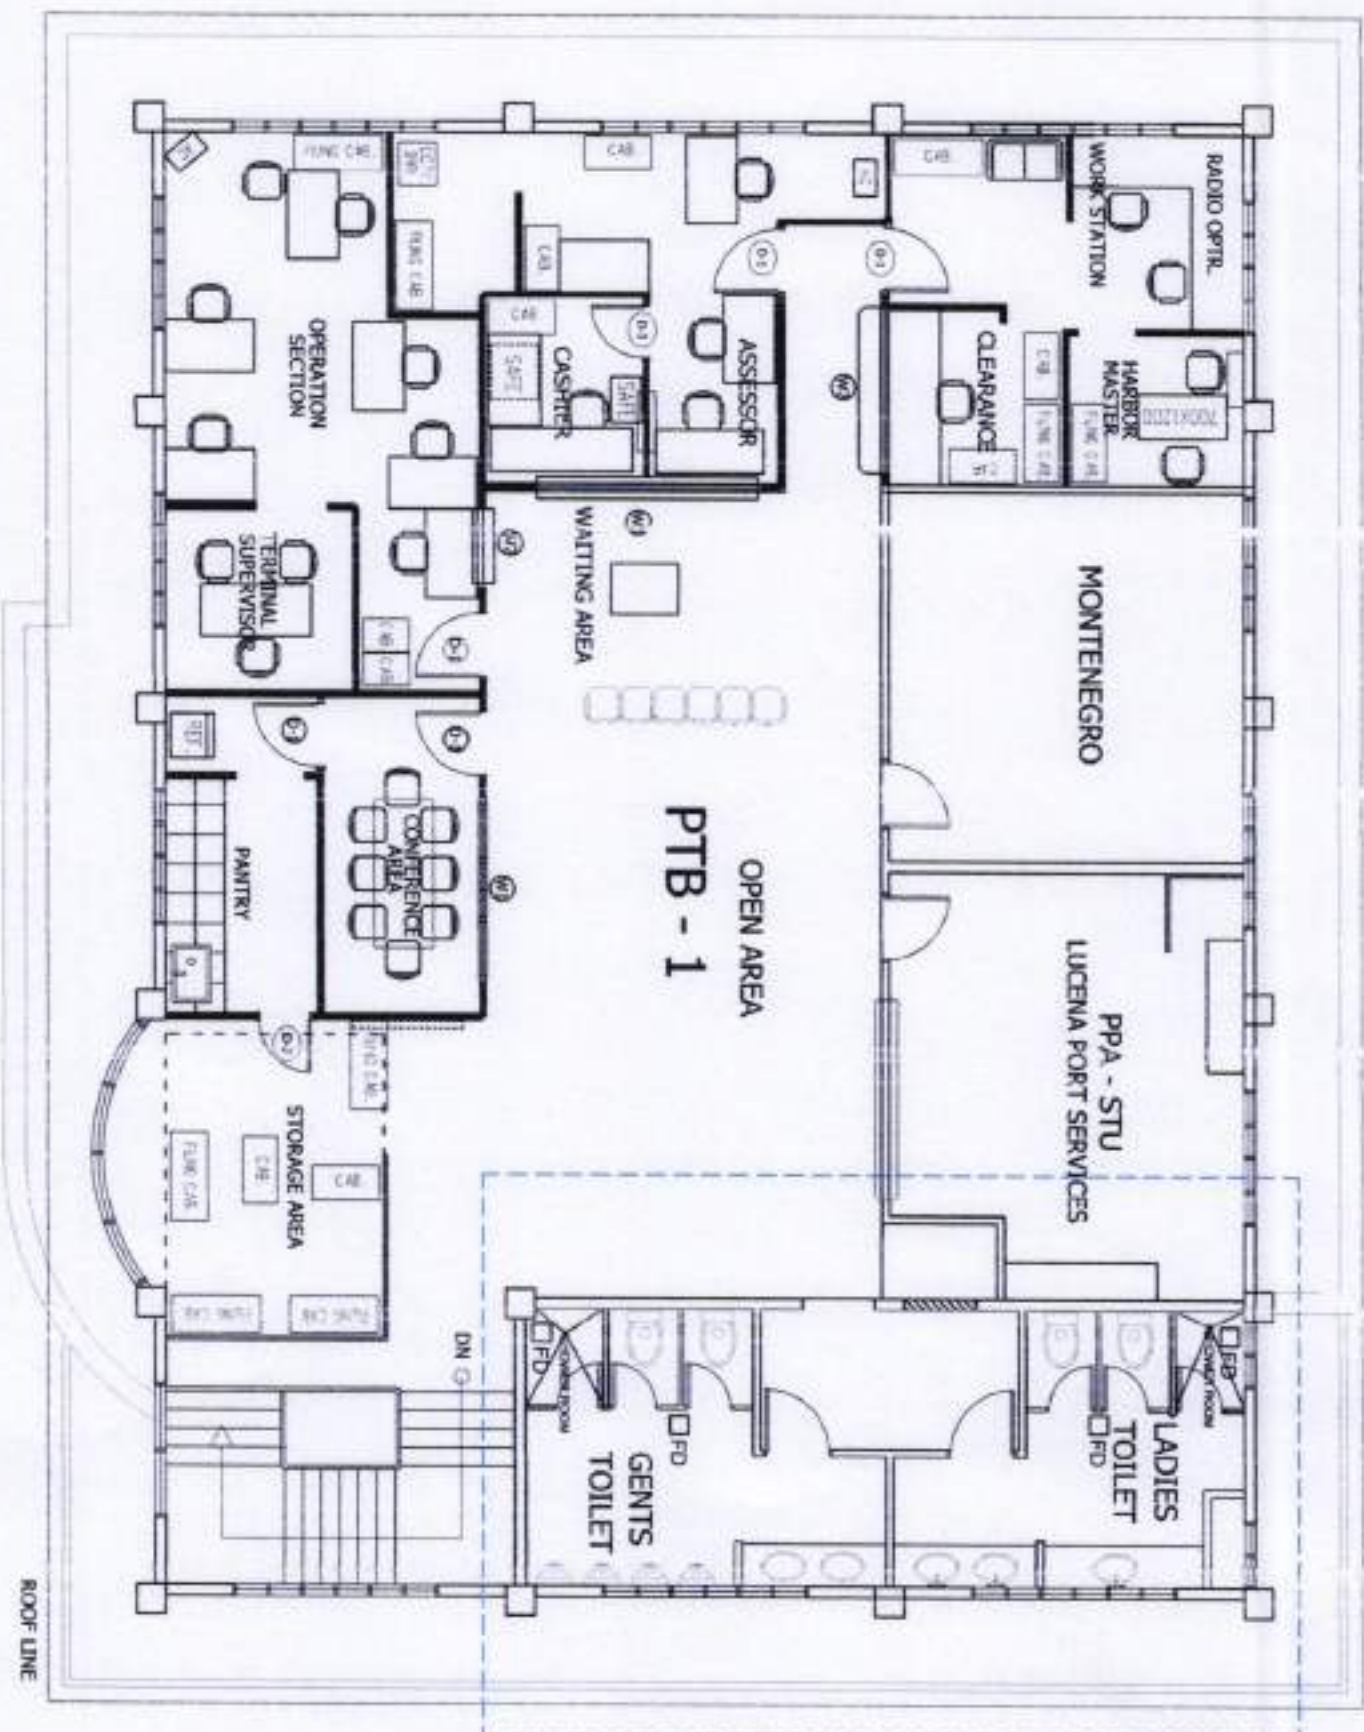

LADIES' COMFORT ROOM


- REPLACEMENT OF TWO (2) SETS OF WATER TANK FITTINGS (LEVER TYPE) & ACCESSORIES, INCLUDING TOILET SEAT COVER, ANGLE VALVE AND STAINLESS FLEXIBLE SUPPLY PIPE
- REPLACEMENT OF TWO (2) SETS, STAINLESS BIDET HOSE (SPRAY)
- REPLACEMENT OF THREE (3) SETS, STAINLESS FAUCET (COUNTER TYPE) INCLUDING ANGLE VALVE, STAINLESS FLEXIBLE SUPPLY PIPE AND P-TRAP
- REPLACEMENT OF ONE (1) PC. SERVICE FAUCETS FOR SLOP SINK
- REPLACEMENT OF TWO (2) SETS OF WALL MOUNTED LIQUID SOAP DISPENSER
- REPLACEMENT OF ONE (1) SET OF AUTOMATIC HAND DRYER
- REPLACEMENT OF ONE (1) SET OF WALL MOUNTED JUMBO ROLL TOILET PAPER DISPENSER
- REPLACEMENT OF THREE (3) SETS DOWNLIGHT RECESSED MOUNTED W/ 1-11W LED PINLIGHT E27
- REPLACEMENT OF CEILING, PERFORATED PANELS, 2' x 2' x 0.70mm thk., BONE WHITE, OR EQUIVALENT = 14.14 SQ. METERS



GENTS' COMFORT ROOM

- REPLACEMENT OF TWO (2) SETS OF WATER TANK FITTINGS (LEVER TYPE) & ACCESSORIES, INCLUDING TOILET SEAT COVER, ANGLE VALVE AND STAINLESS FLEXIBLE SUPPLY PIPE
- REPLACEMENT OF TWO (2) SETS, STAINLESS BIDET HOSE (SPRAY)
- REPLACEMENT OF TWO (2) SETS, STAINLESS FAUCET (COUNTER TYPE) INCLUDING ANGLE VALVE, STAINLESS FLEXIBLE SUPPLY PIPE AND P-TRAP
- REPLACEMENT OF ONE (1) PC. SERVICE FAUCETS FOR SLOP SINK
- REPLACEMENT OF ONE (1) SET OF WALL MOUNTED LIQUID SOAP DISPENSER
- REPLACEMENT OF ONE (1) SET OF AUTOMATIC HAND DRYER
- REPLACEMENT OF ONE (1) SET OF WALL MOUNTED JUMBO ROLL TOILET PAPER DISPENSER
- REPLACEMENT OF FIVE (5) SETS DOWNLIGHT RECESSED MOUNTED W/ 1-11W LED PINLIGHT E27
- REPLACEMENT OF CEILING, PERFORATED PANELS, 2' x 2' x 0.70mm thk., BONE WHITE, OR EQUIVALENT = 14.59 SQ. METERS

SECOND FLOOR (BASE PORT) PLAN

SCALE 1:100

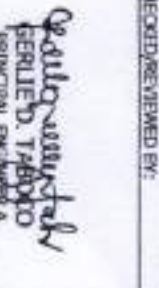 PHILIPPINE PORTS AUTHORITY PORT MANAGER'S OFFICE - MANTOLO	PROJECT/LOCATION: EMERGENCY MAINTENANCE OF COMFORT ROOMS AT PASSENGER TERMINAL BUILDING LUCENA CITY	PREPARED BY:  MARK ANDREW S. PINEDA ACTING SUPERVISING ENGINEER A	CHECKED/REVIEWED BY:  GERARDO T. TABO PRINCIPAL ENGINEER A	RECOMMENDED BY:  RAUL J. LIBATIQUE PORT MANAGER	APPROVED BY:  ANNA THERESA BISCOCHO PORT MANAGER	SHEET CONTENT: • SECOND FLOOR (BASE PORT) PLAN 4 / 7
---	---	---	--	---	--	--

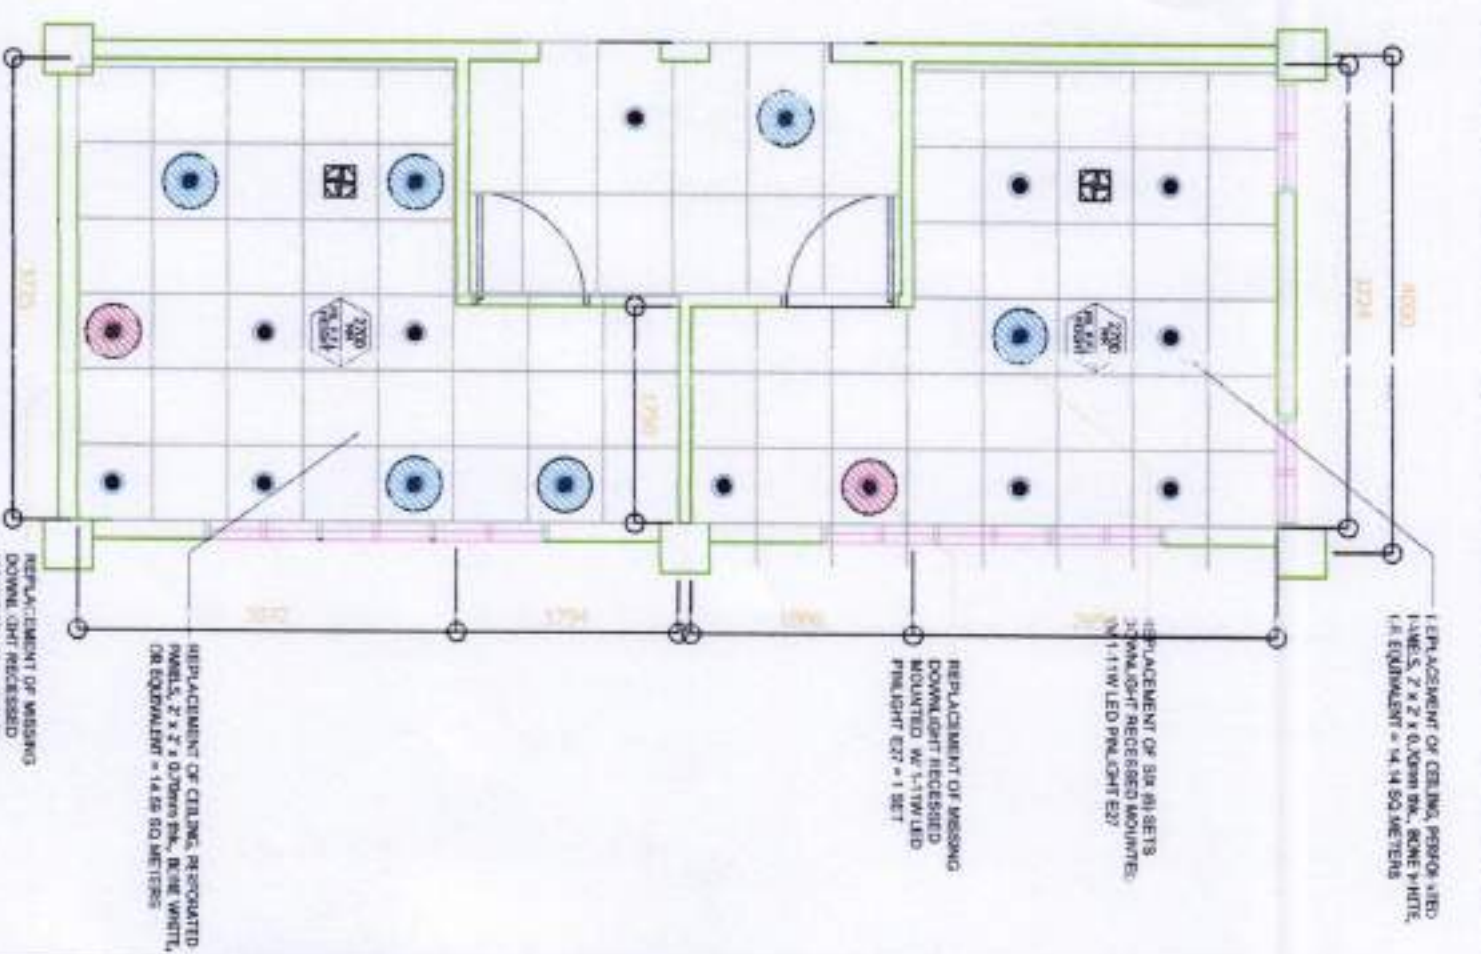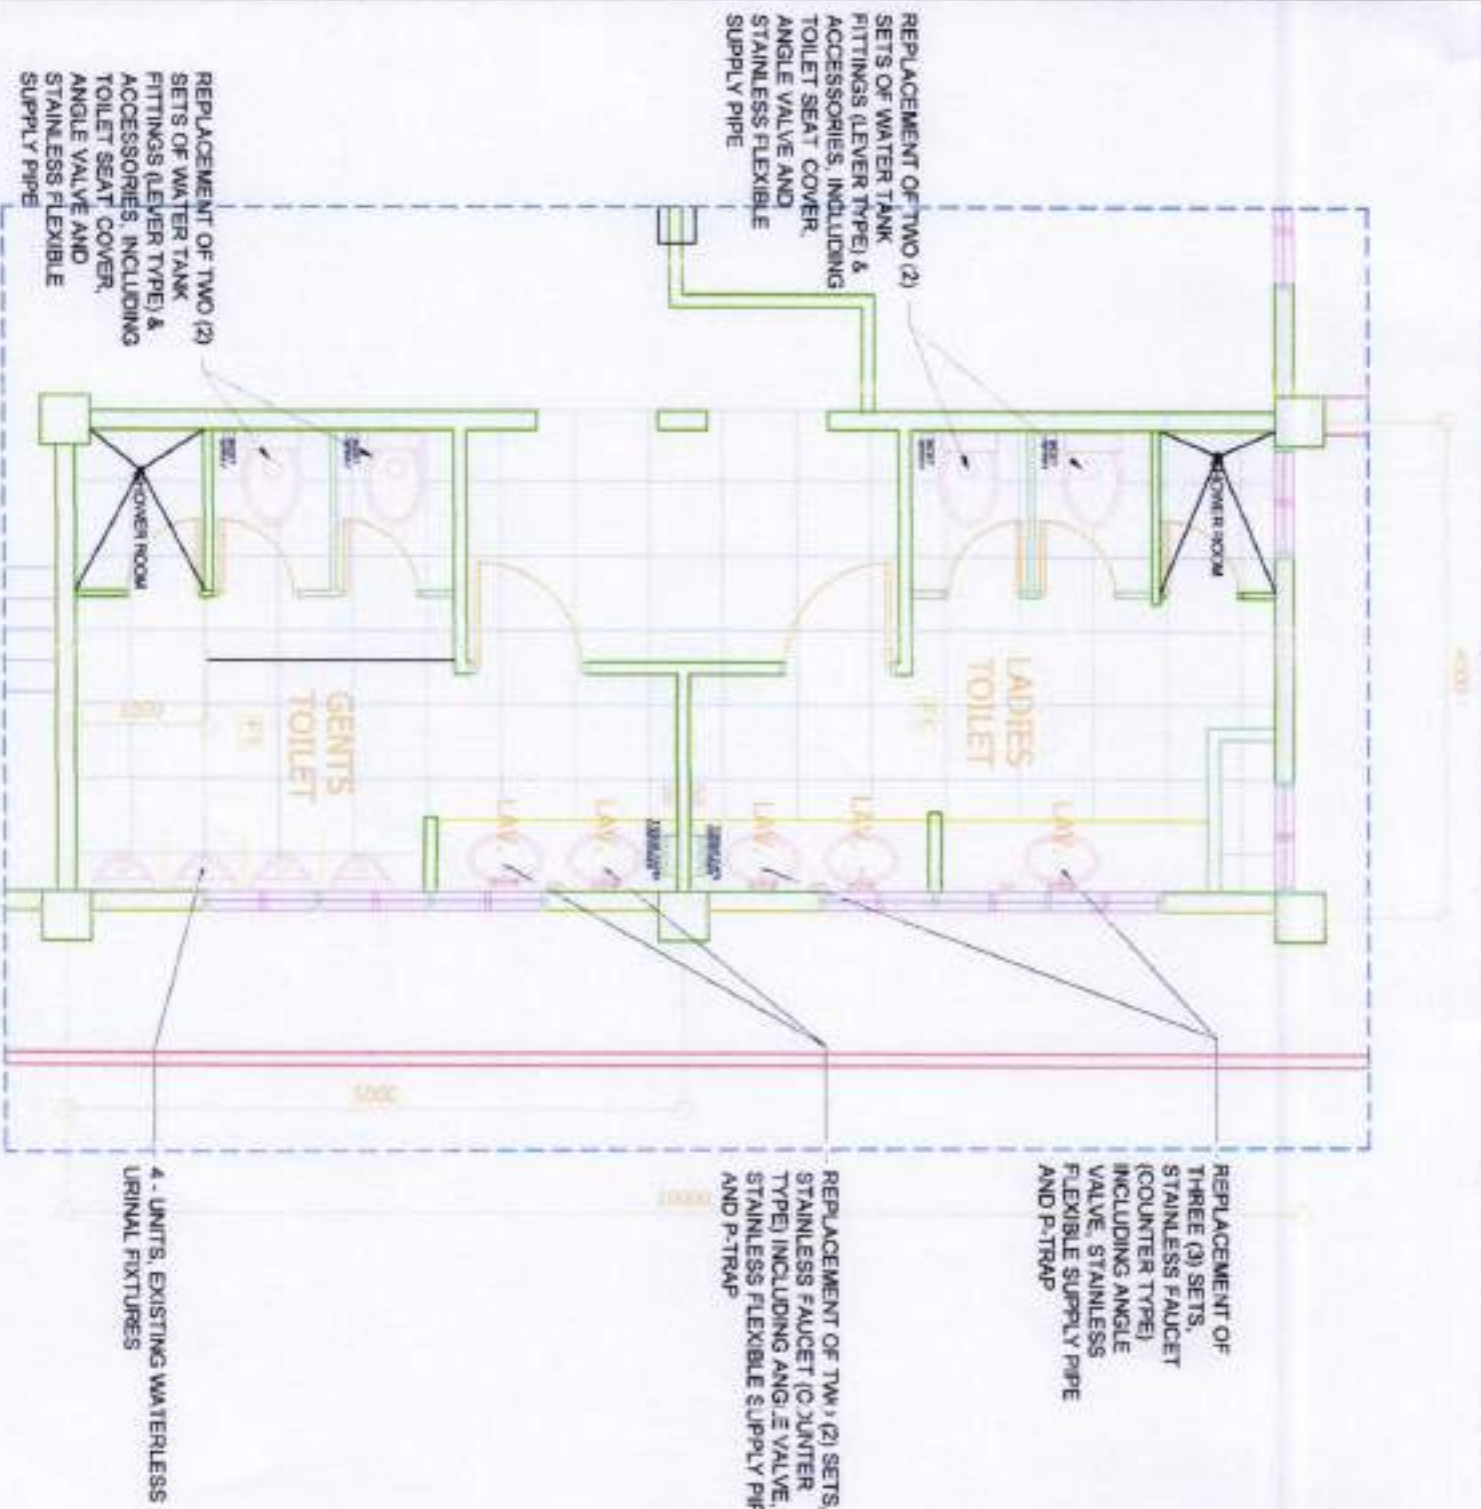

COMFORT ROOM PLAN (SECOND FLOOR - BASE PORT)

COMFORT ROOM REFLECTED CEILING PLAN (SECOND FLOOR)


SCALE

1:50

SCALE

1:50

PHILIPPINE PORTS AUTHORITY PORT MANAGEMENT OFFICE - MANILA	PROJECT/LOCATION: EMERGENCY MAINTENANCE OF COMFORT ROOMS AT PASSENGER TERMINAL BUILDING LUCENA CITY	PREPARED BY: MARK ANDREW S. PINEDA ACTING SUPERVISING ENGINEER A	CHECKED/REVIEWED BY: GERIE B. TABOCO PRINCIPAL ENGINEER A	RECOMMENDED BY: RAULVA LIBRANO E27 MANAGER	APPROVED BY: ANNA THEA BISCOCHO E27 MANAGER	SHEET CONTENT: ● COMFORT ROOM P.L.A. ● SECOND FLOOR - BASE PORT ● COMFORT ROOM REFLECTED CEILING PLAN (SECOND FLOOR) 5 / 7
--	---	--	---	--	---	--

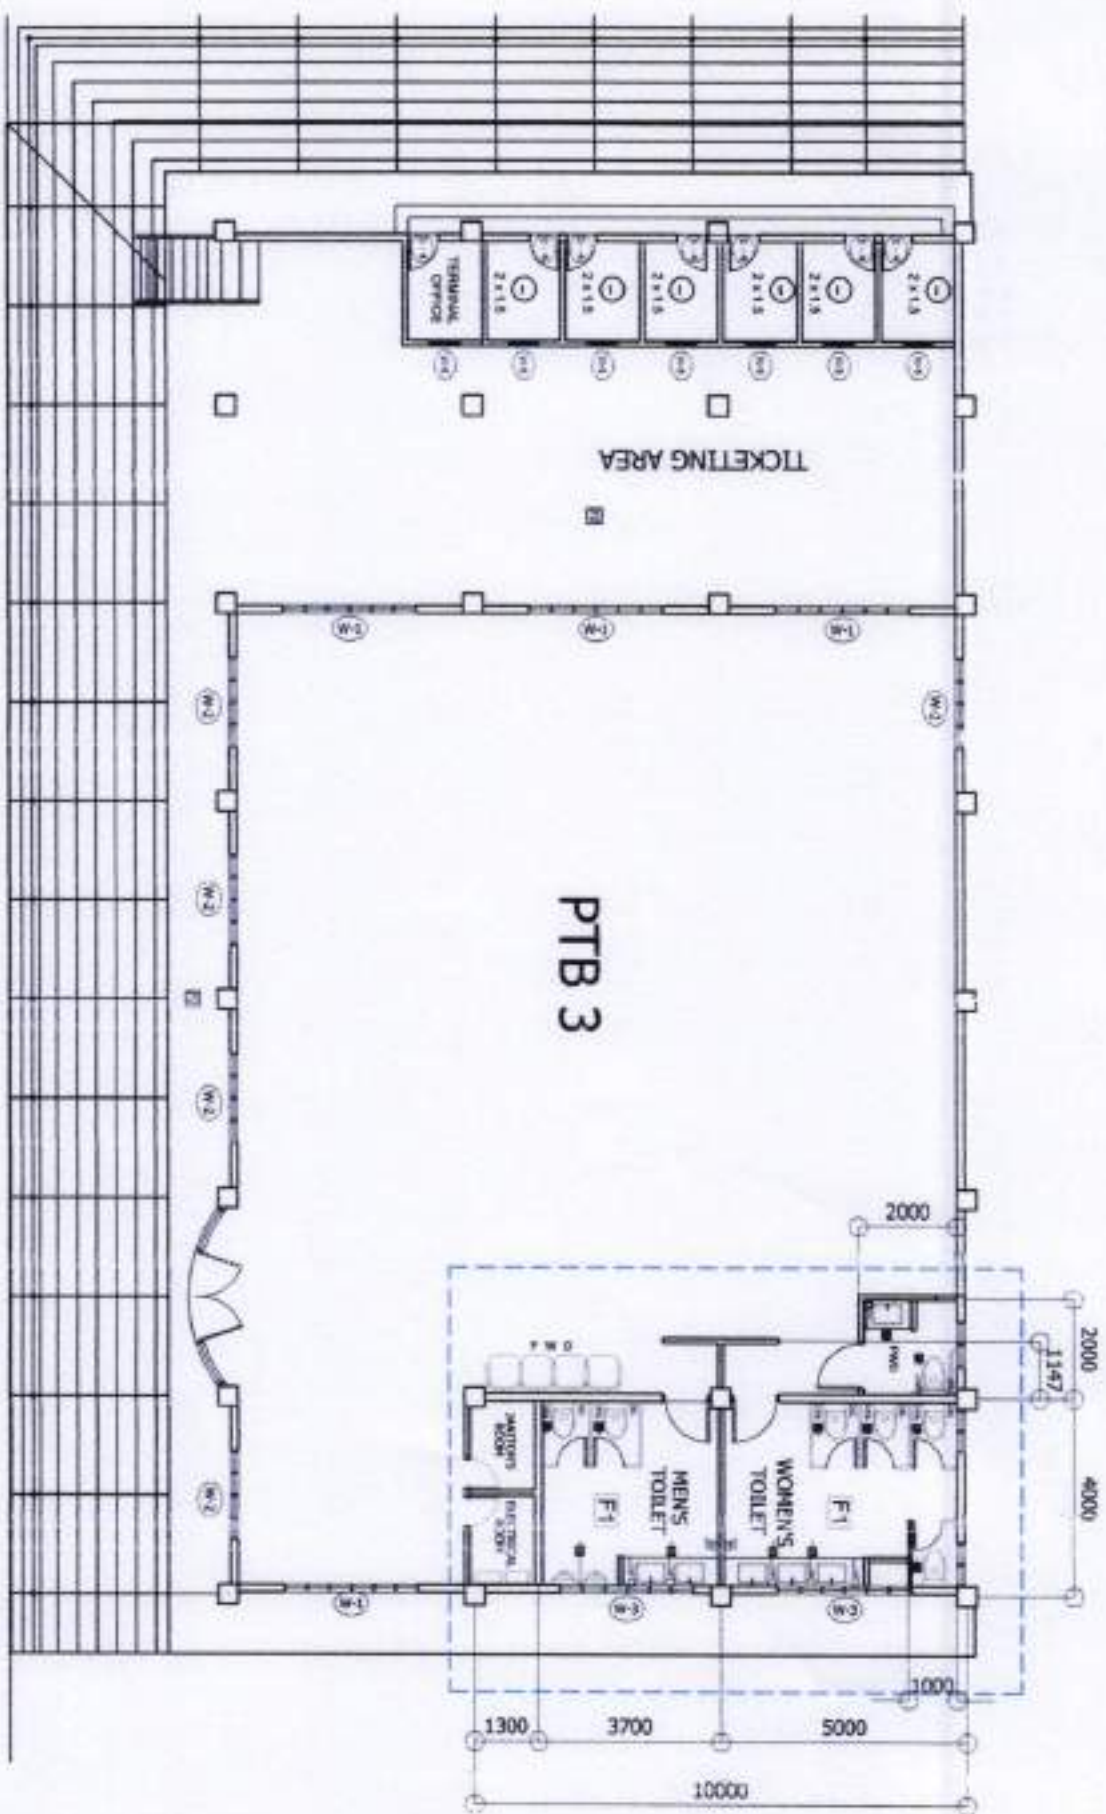


PTB 3 FLOOR PLAN
SCALE 1:150

- FEMALE COMFORT ROOM**
- REPLACEMENT OF TWO (2) SETS OF WATER TANK COMPLETE WITH TANK FITTINGS PUSH BUTTON INCLUDING TOILET SEAT COVER, ANGLE VALVE (2-WAY) AND STAINLESS FLEXIBLE SUPPLY PIPE
 - REPLACEMENT OF ONE (1) SET OF WATER TANK FITTINGS LEVER TYPE INCLUDING TOILET SEAT COVER, ANGLE VALVE (2-WAY) AND STAINLESS FLEXIBLE SUPPLY PIPE
 - REPLACEMENT OF FOUR (4) SETS OF STAINLESS BIDET HOSE SPRAY
 - REPLACEMENT OF THREE (3) SETS, STAINLESS FAUCET FOR LAVATORY INCLUDING ANGLE VALVE, STAINLESS FLEXIBLE SUPPLY PIPE AND P-TRAP
 - REPLACEMENT OF THREE (3) SETS OF WALL MOUNTED LIQUID SOAP DISPENSER
 - REPLACEMENT OF ONE (1) SET OF AUTOMATIC HAND DRYER
 - REPLACEMENT OF ONE (1) SET OF WALL MOUNTED JUMBO ROLL TOILET PAPER DISPENSER
 - REPLACEMENT OF TWO (2) SETS OF WINDOW TYPE EXHAUST FAN
 - REPLACEMENT OF ONE (1) SET DOWNLIGHT RECESSED MOUNTED W/ 1-11W LED PINLIGHT E27

- MALE COMFORT ROOM**
- REPLACEMENT OF TWO (2) SETS OF URINAL FLUSH VALVE
 - REPLACEMENT OF TWO (2) SETS OF STAINLESS BIDET HOSE SPRAY
 - REPLACEMENT OF TWO (2) SETS STAINLESS FAUCET FOR LAVATORY INCLUDING ANGLE VALVE, STAINLESS FLEXIBLE SUPPLY PIPE AND P-TRAP
 - REPLACEMENT OF TWO (2) SETS OF WALL MOUNTED LIQUID SOAP DISPENSER
 - REPLACEMENT OF ONE (1) SET OF AUTOMATIC HAND DRYER
 - REPLACEMENT OF ONE (1) SET OF WALL MOUNTED JUMBO ROLL TOILET PAPER DISPENSER
 - REPLACEMENT OF TWO (2) SETS OF WINDOW TYPE EXHAUST FAN
 - REGROUTING AND REPLACEMENT OF 600MM x 600MM WALL TILES, 2.13 SQ.M.

- PWD COMFORT ROOM**
- REPLACEMENT OF ONE (1) SET OF WATER TANK FITTINGS LEVER TYPE INCLUDING TOILET SEAT COVER, ANGLE VALVE (2-WAY) AND STAINLESS FLEXIBLE SUPPLY PIPE
 - REPLACEMENT OF ONE (1) SET OF STAINLESS BIDET HOSE SPRAY
 - REPLACEMENT OF ONE (1) SET STAINLESS FAUCET FOR LAVATORY INCLUDING ANGLE VALVE, STAINLESS FLEXIBLE SUPPLY PIPE AND P-TRAP
 - REPLACEMENT OF ONE (1) SET OF WALL MOUNTED LIQUID SOAP DISPENSER
 - REGROUTING AND REPLACEMENT OF 600MM x 600MM WALL TILES, 2.64 SQ.M.
 - REPLACEMENT OF ONE (1) SET DOWNLIGHT RECESSED MOUNTED W/ 1-11W LED PINLIGHT E27

 PHILIPPINE PORTS AUTHORITY PORT MANAGEMENT OFFICE - MANILA	PROJECT/LOCATION: EMERGENCY MAINTENANCE OF COMFORT ROOMS AT PASSENGER TERMINAL BUILDING LUCENA CITY	PREPARED BY: MARK ANDREW S. PINEDA ACTING SUPERVISING ENGINEER A	CHECKED/REVIEWED BY: GERILDE D. TABOZO SENIOR ENGINEER A	RECOMMENDED BY: RAUL A. LIBATONQUE ESD MANAGER	APPROVED BY: ANITA BISCOCHO PORT MANAGER	SHEET CONTENT: PTB 3 FLOOR PLAN 6 / 7
---	---	---	---	---	---	---

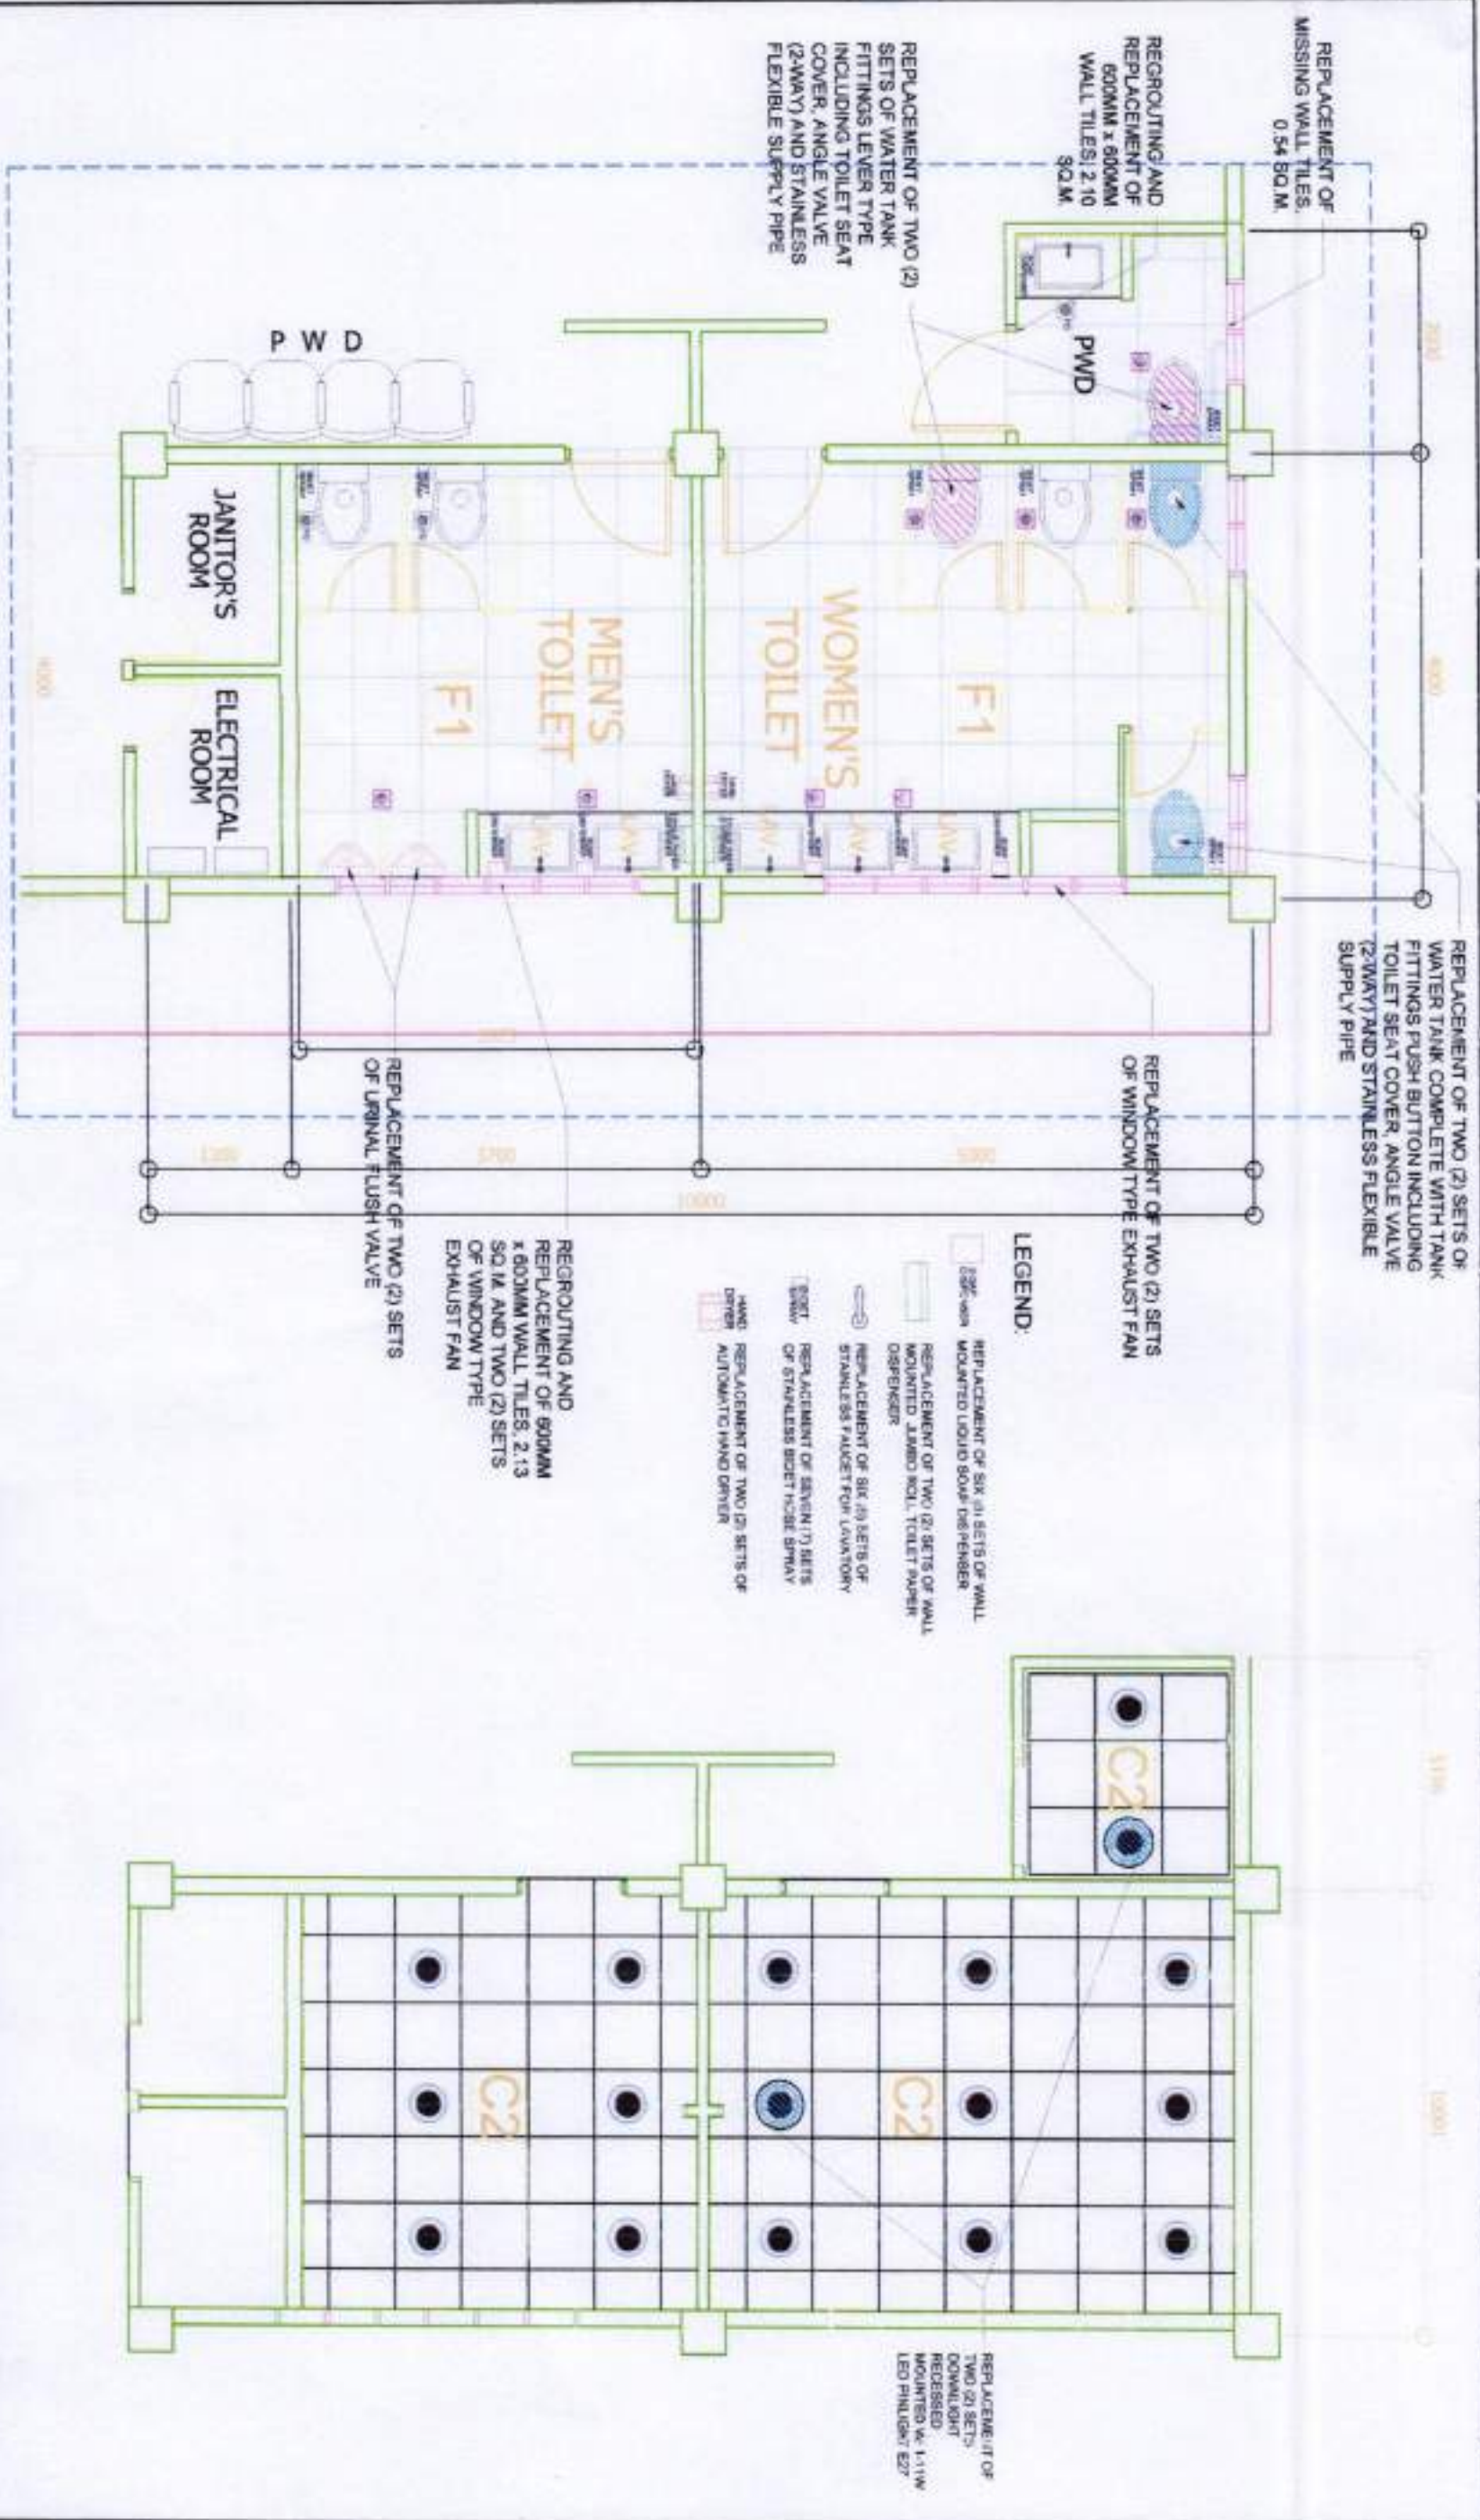

COMFORT ROOM PLAN (PTB 3)
SCALE 1:50

COMFORT ROOM REFLECTED CEILING PLAN (PTB 3)
SCALE 1:50

PHILIPPINE PORTS AUTHORITY	PROJECT/LOCATION: EMERGENCY MAINTENANCE OF COMFORT ROOMS AT PASSENGER TERMINAL BUILDING PORT OF LUCENA LUCENA CITY	PREPARED BY: MARK ANDREW S. PINEDA ACTING SUPERVISING ENGINEER A	CHECKED/REVIEWED BY: GERLIE B. TABO PRINCIPAL ENGINEER A	RECOMMENDED BY: RAUL A. LIBATIQUE SR. MANAGER	APPROVED BY: ANNA THERESA BISCOCHO PORT MANAGER	SHEET CONTENT: - COMFORT ROOM PLAN (PTB 3) - COMFORT ROOM REFLECTED CEILING PLAN (PTB 3) 7 / 7
-----------------------------------	--	---	---	--	--	--