



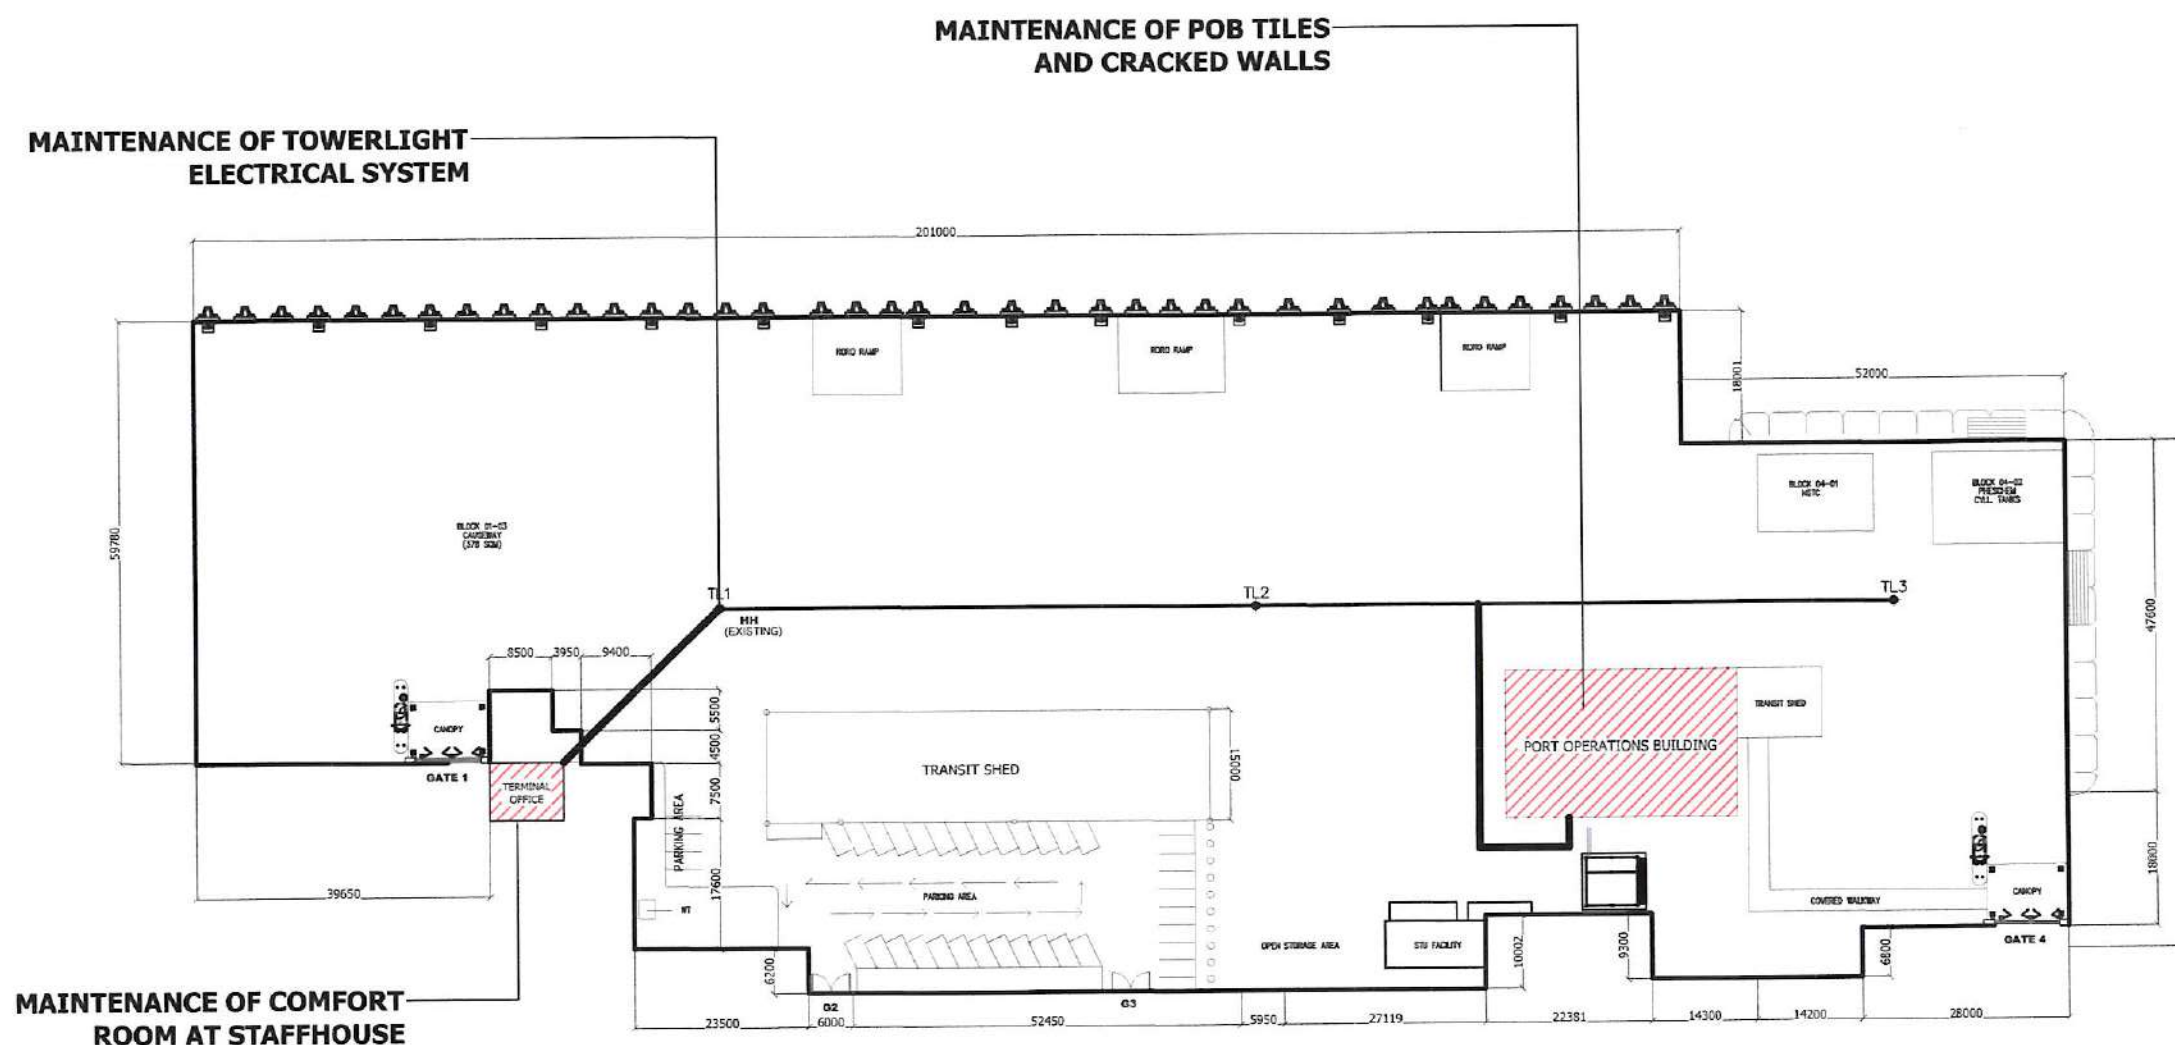

SITE DEVELOPMENT PLAN

PORT OF PALOMPON, LEYTE

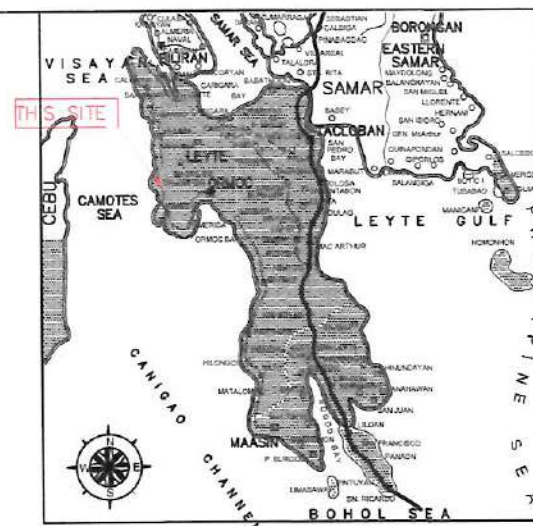

PROJECT TITLE:
MAINTENANCE OF TOWERLIGHT ELECTRICAL SYSTEM, STAFFHOUSE COMFORT ROOM, POB OFFICE TILES AND CRACKED WALLS CAUSED BY MAGNITUDE 6.9 EARTHQUAKE

LOCATION: PORT OF PALOMPON, LEYTE

SHEET CONTENT:
AS SHOWN

PREPARED BY:

AILYNNE E. DAGOHOY
DRAFTSMAN III

REVIEWED AND CHECKED BY:

LORD TYRONE L. AGATON
PRINCIPAL ENGINEER

RECOMMENDING APPROVAL:

GERRY D. LIQUIDO
ESD MANAGER

APPROVED BY:

BERNARD CALLEDO
PORT MANAGER

SHEET NO.

1
7



SHEET CONTENT:

AS SH

AS SHOWN

PREPARED BY: ALLYN D

ALLYNNE E. DAGOHY
DRAFTSMAN III

REVIEWED AND CHECKED BY: 
LORD TYRONEL A. LORD
PRINCIPAL ENGINEER


LORD TYRONE L. AGATON
PRINCIPAL ENGINEER

RECOMMENDING APPROVAL: _____
GERRY D. LIQU
ESD MANAGER


ESD MANAGER



APPROVED BY: _____

BERNARD



BERNARD ~~DE~~ CALLEDOR
PORT MANAGER

SHEET NO. $\frac{2}{7}$

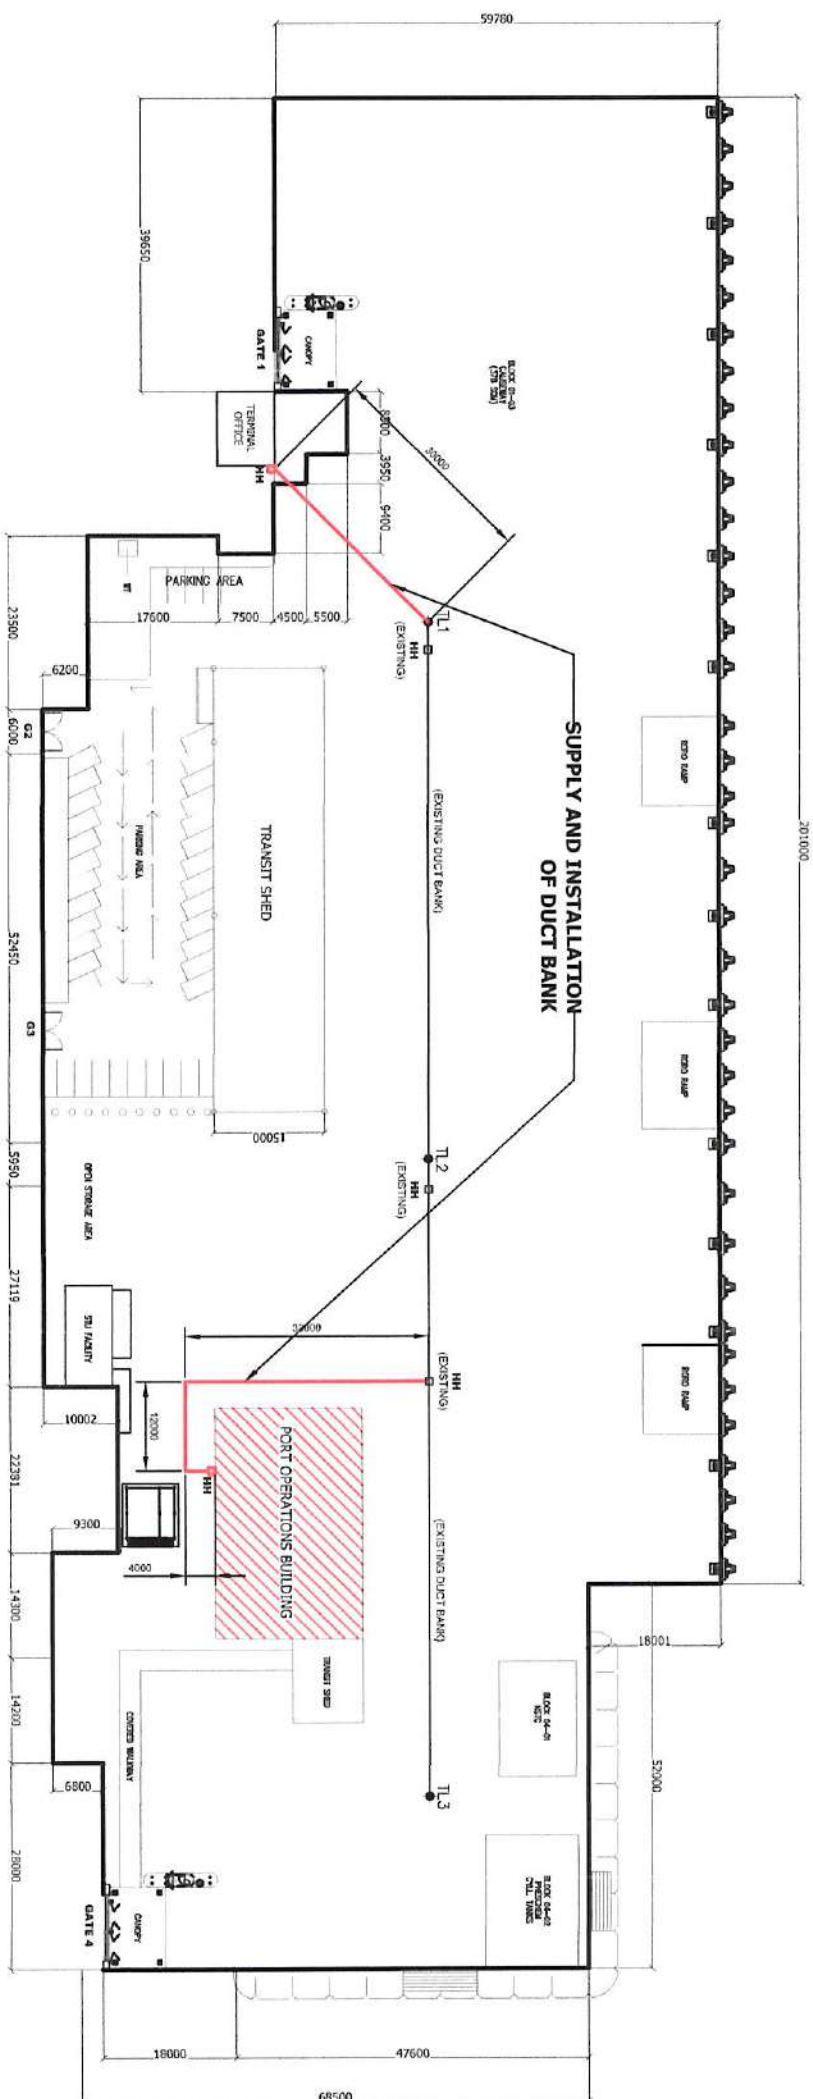


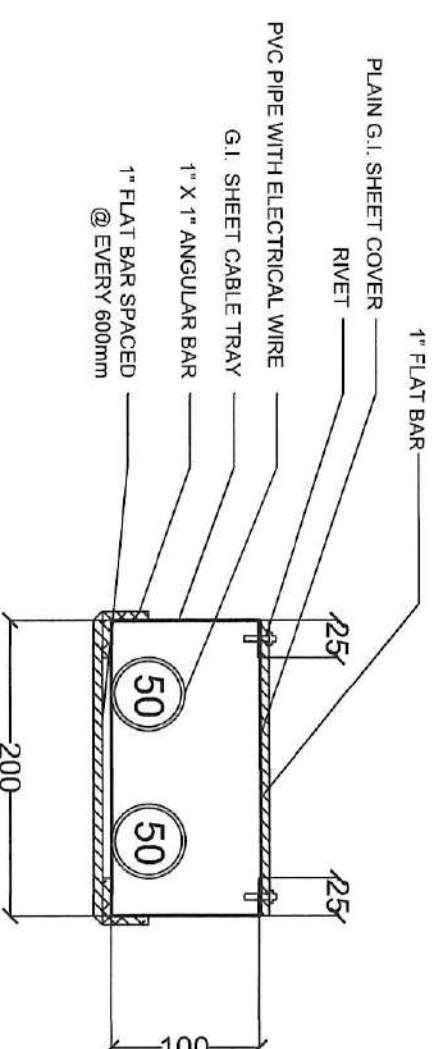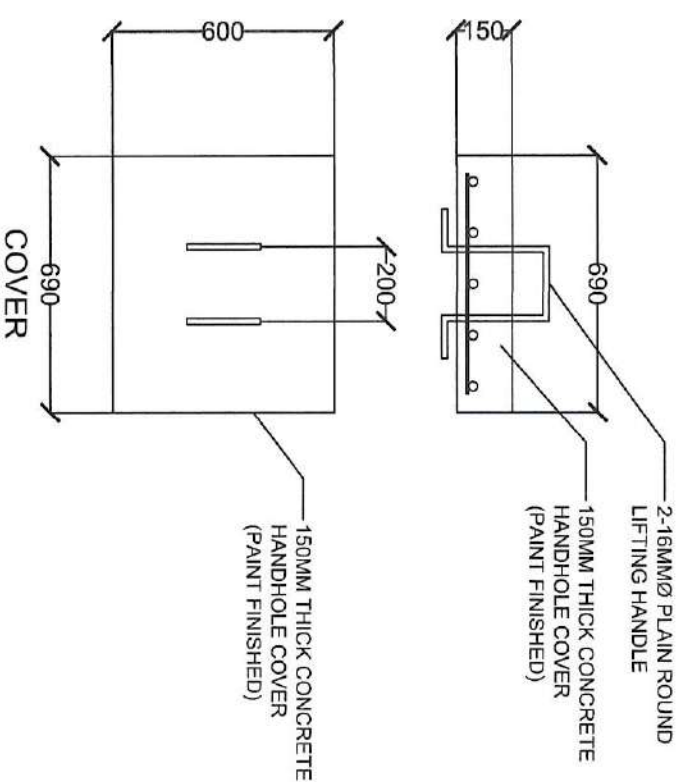

DETAIL OF CABLE TRAY

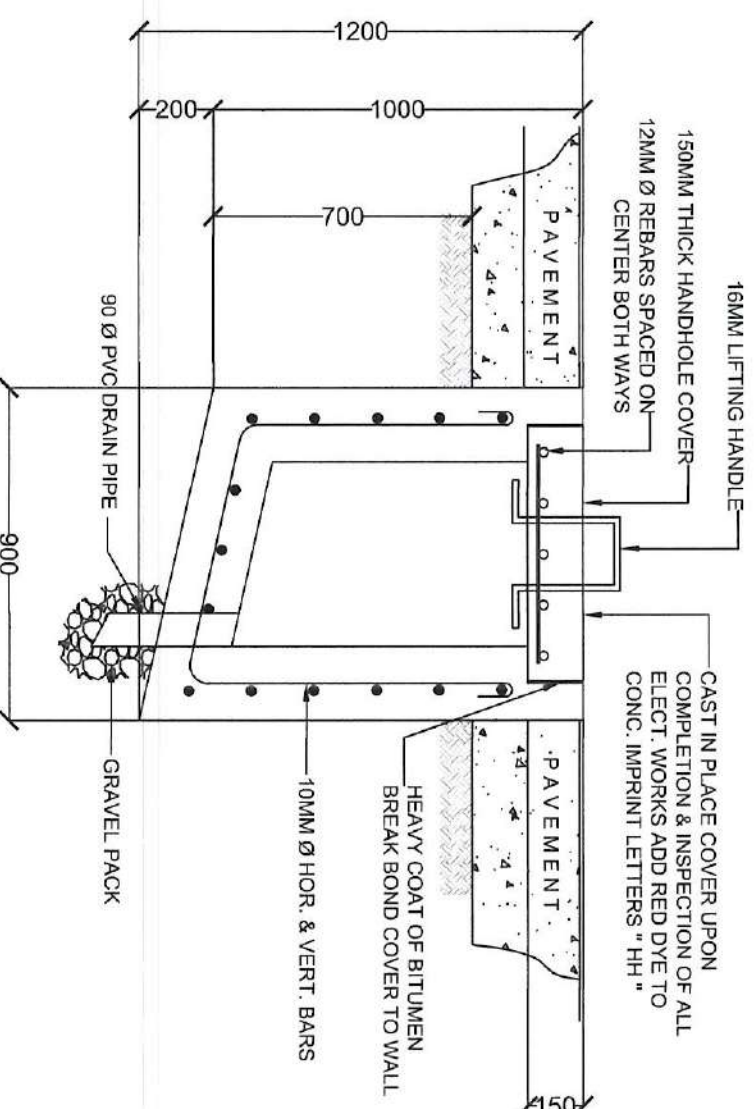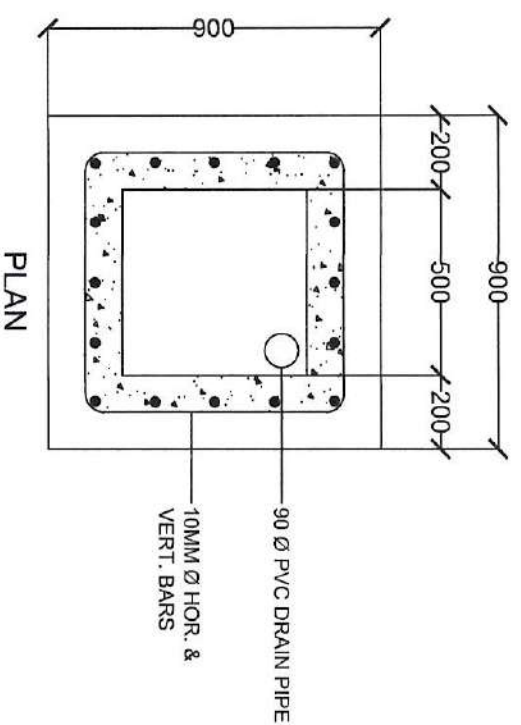


DETAIL OF HANDHOLE (HH)

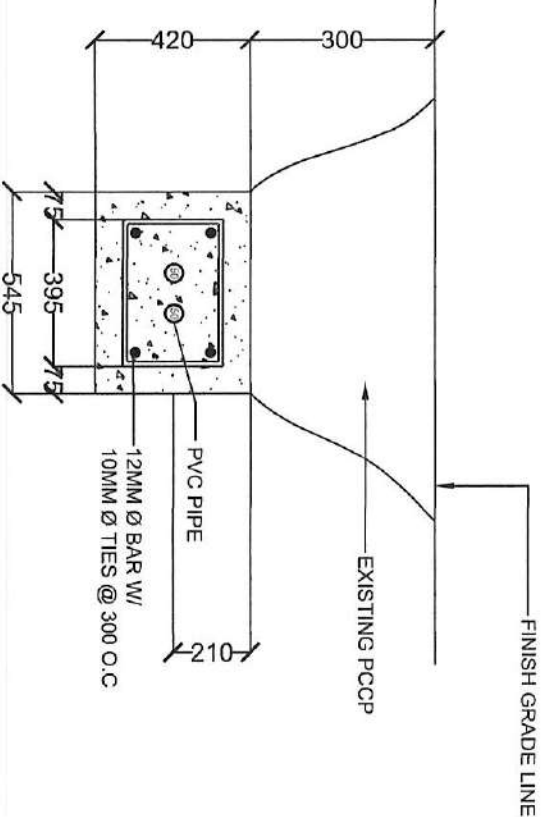


	PROJECT TITLE: MAINTENANCE OF TOWERLIGHT ELECTRICAL SYSTEM, STAFFHOUSE COMFORT ROOM, POB OFFICE TILES AND CRACKED WALLS CAUSED BY MAGNITUDE 6.9 EARTHQUAKE LOCATION: PORT OF PALOMPON, LEYTE	SHEET CONTENT: AS SHOWN	PREPARED BY: ALLYNNE DRAGOHAY DRAFTSMAN III	REVIEWED AND CHECKED BY: LORD TYRONE L. AGATON PRINCIPAL ENGINEER	RECOMMENDING APPROVAL: GERRY D. LIQUIDO ESD MANAGER	APPROVED BY: BERNARD D. ALLEDO PORT MANAGER	SHEET NO. 3 / 7
--	---	-----------------------------------	--	--	--	--	---------------------------

REMOVE AND REPLACE
CEILING BOARD

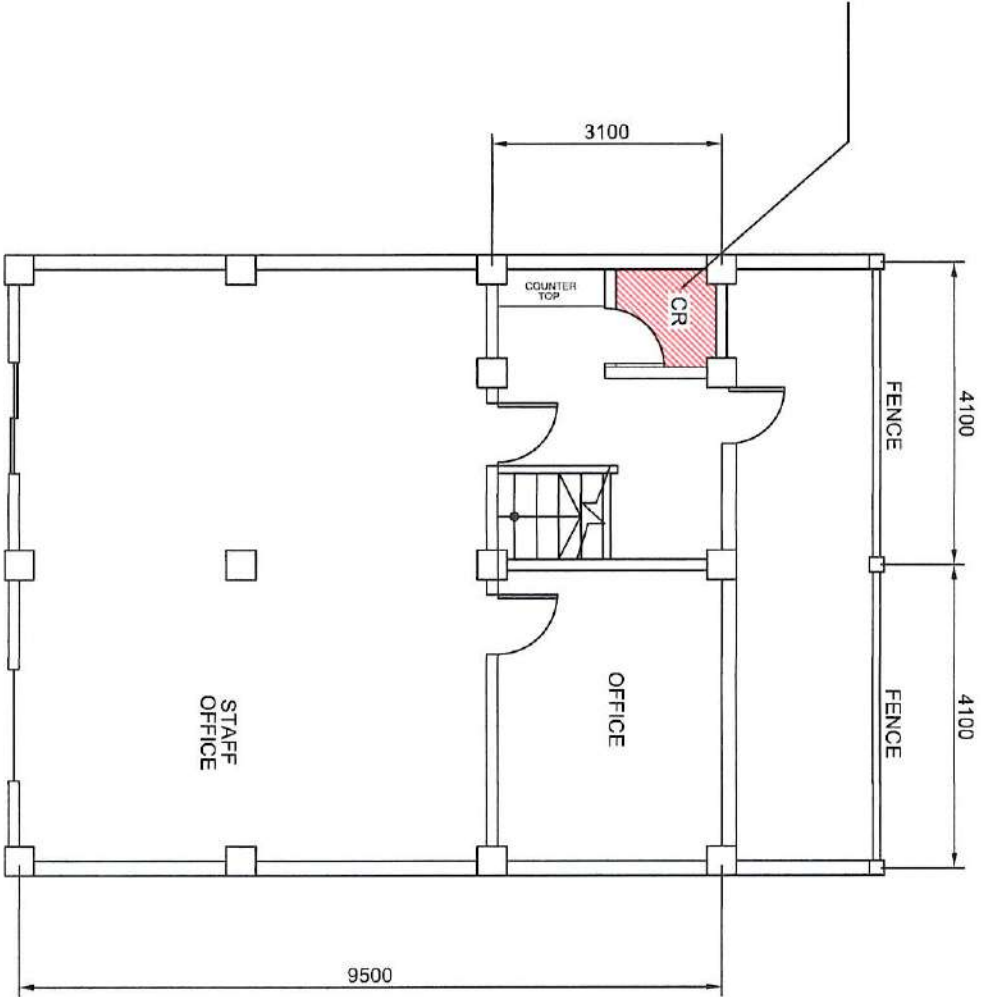


GROUND FLOOR PLAN @ STAFF HOUSE
SCALE: 1:100


	PROJECT TITLE:	SHEET CONTENT:	PREPARED BY:	REVIEWED AND CHECKED BY:	RECOMMENDING APPROVAL:	APPROVED BY:	SHEET NO.
	MAINTENANCE OF TOWERLIGHT ELECTRICAL SYSTEM, STAFFHOUSE COMFORT ROOM, POB OFFICE TILES AND CRACKED WALLS CAUSED BY MAGNITUDE 6.9 EARTHQUAKE LOCATION: PORT OF PALOMPON, LEYTE	AS SHOWN	ALVIN E. DAGOHAY DRAFTSMAN III	LORD TYRONE L. AGATON PRINCIPAL ENGINEER	GERRY D. LIQUIDO ESD MANAGER	BERNARD CALLEDO PORTMANAGER	4 7

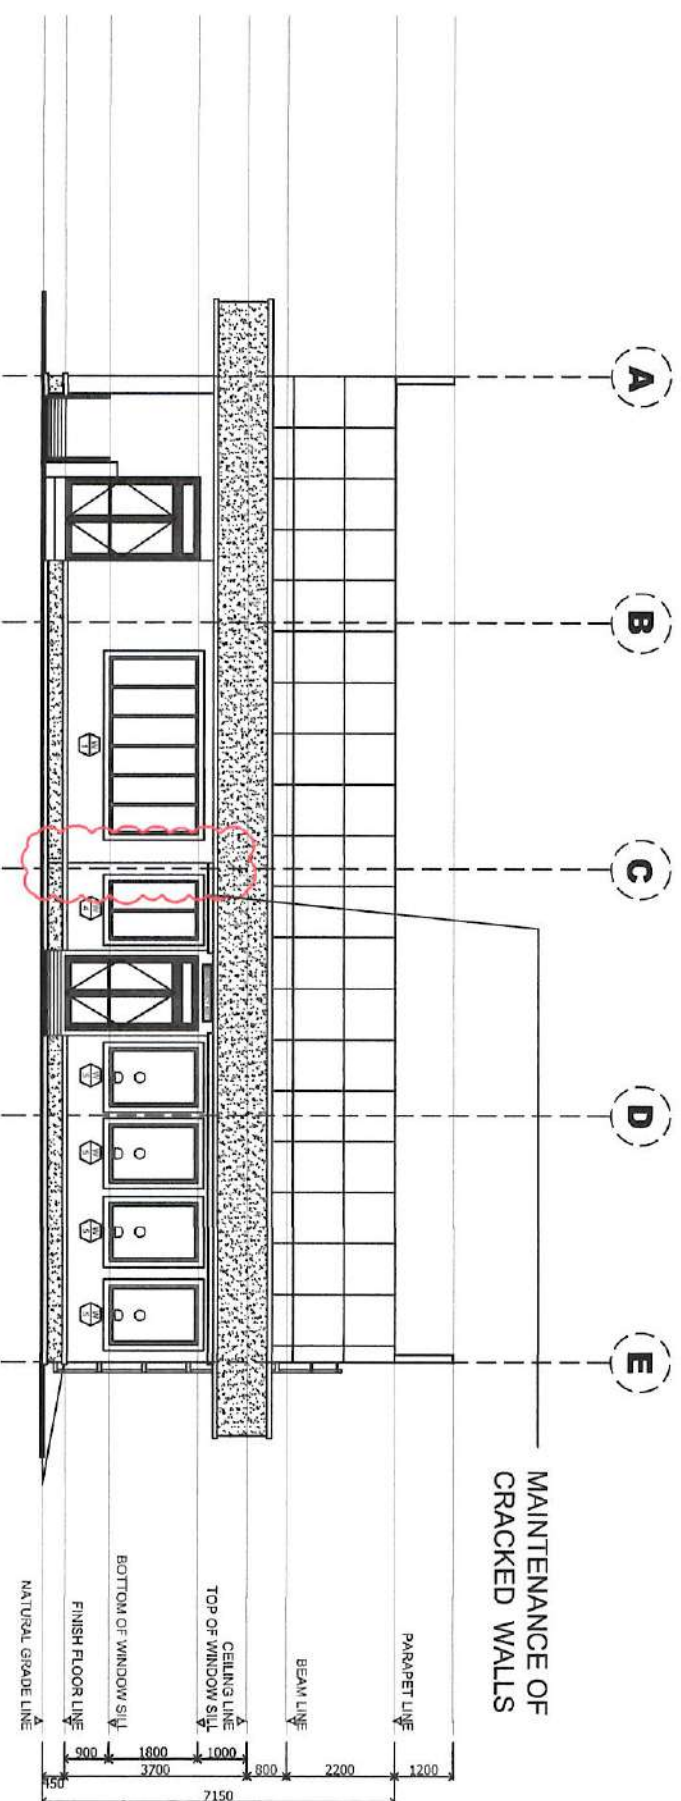

RIGHT SIDE ELEVATION
SCALE: 1:150

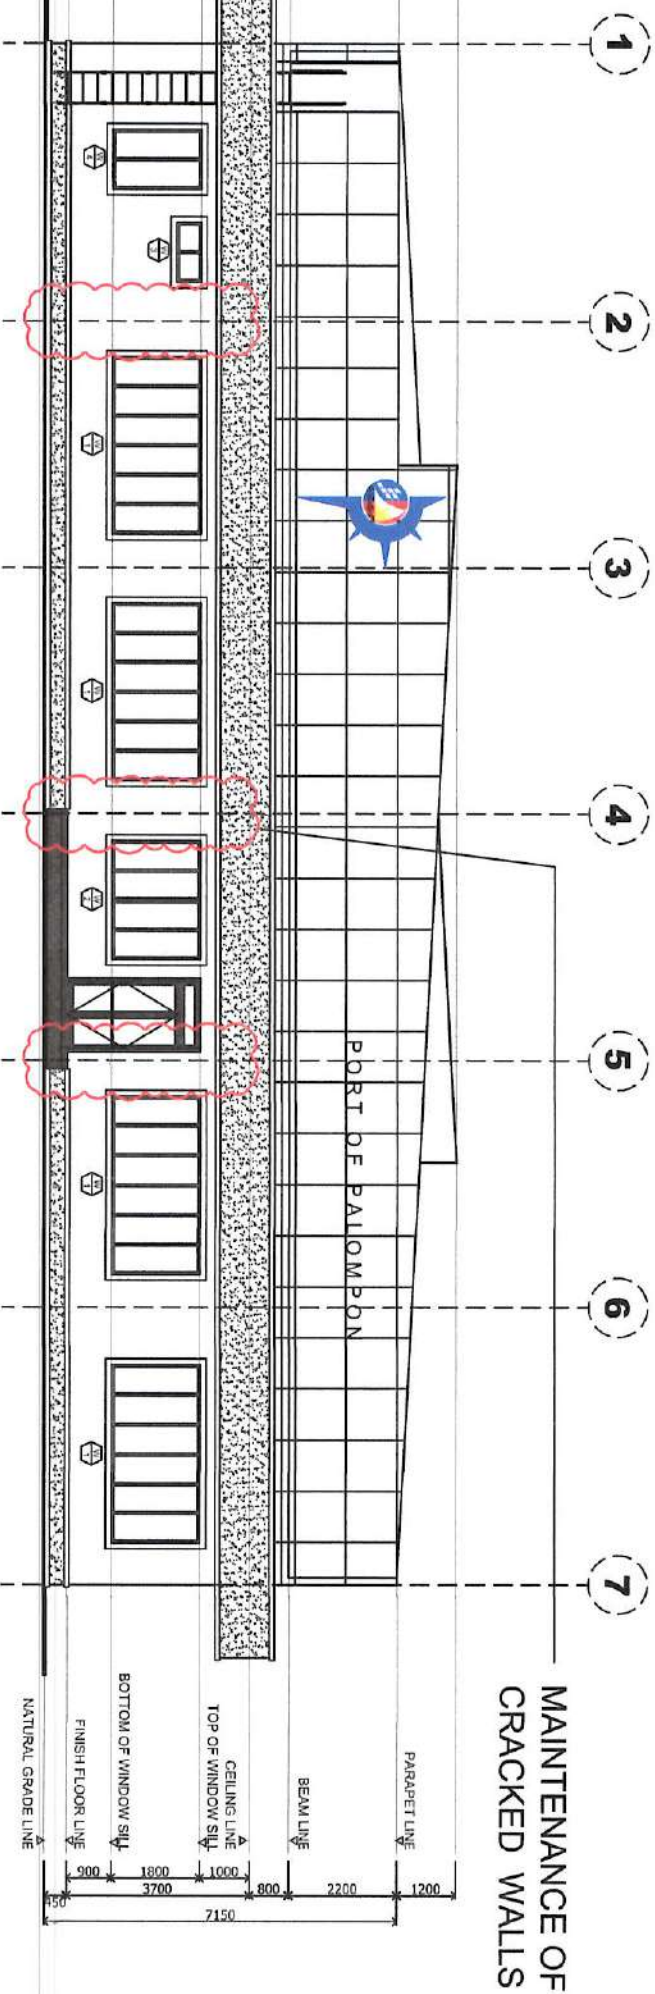

REAR ELEVATION
SCALE: 1:150

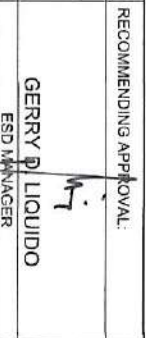	PROJECT TITLE: MAINTENANCE OF TOWERLIGHT ELECTRICAL SYSTEM, STAFFHOUSE COMFORT ROOM, POB OFFICE TILES AND CRACKED WALLS CAUSED BY MAGNITUDE 6.9 EARTHQUAKE LOCATION: PORT OF PALOMPON, LETYE	SHEET CONTENT: AS SHOWN	PREPARED BY:  ALVIN E. DAGOHAY DRAFTSMAN III	REVIEWED AND CHECKED BY:  LORD TYRONEC. AGATON PRINCIPAL ENGINEER	RECOMMENDING APPROVAL:  GERRY D. LIQUIDO ESD MANAGER	APPROVED BY:  BERNABE S. ALLEDO REGISTERED ENGINEER	SHEET NO. 5 7
---	---	-----------------------------------	--	---	--	---	----------------------------

