
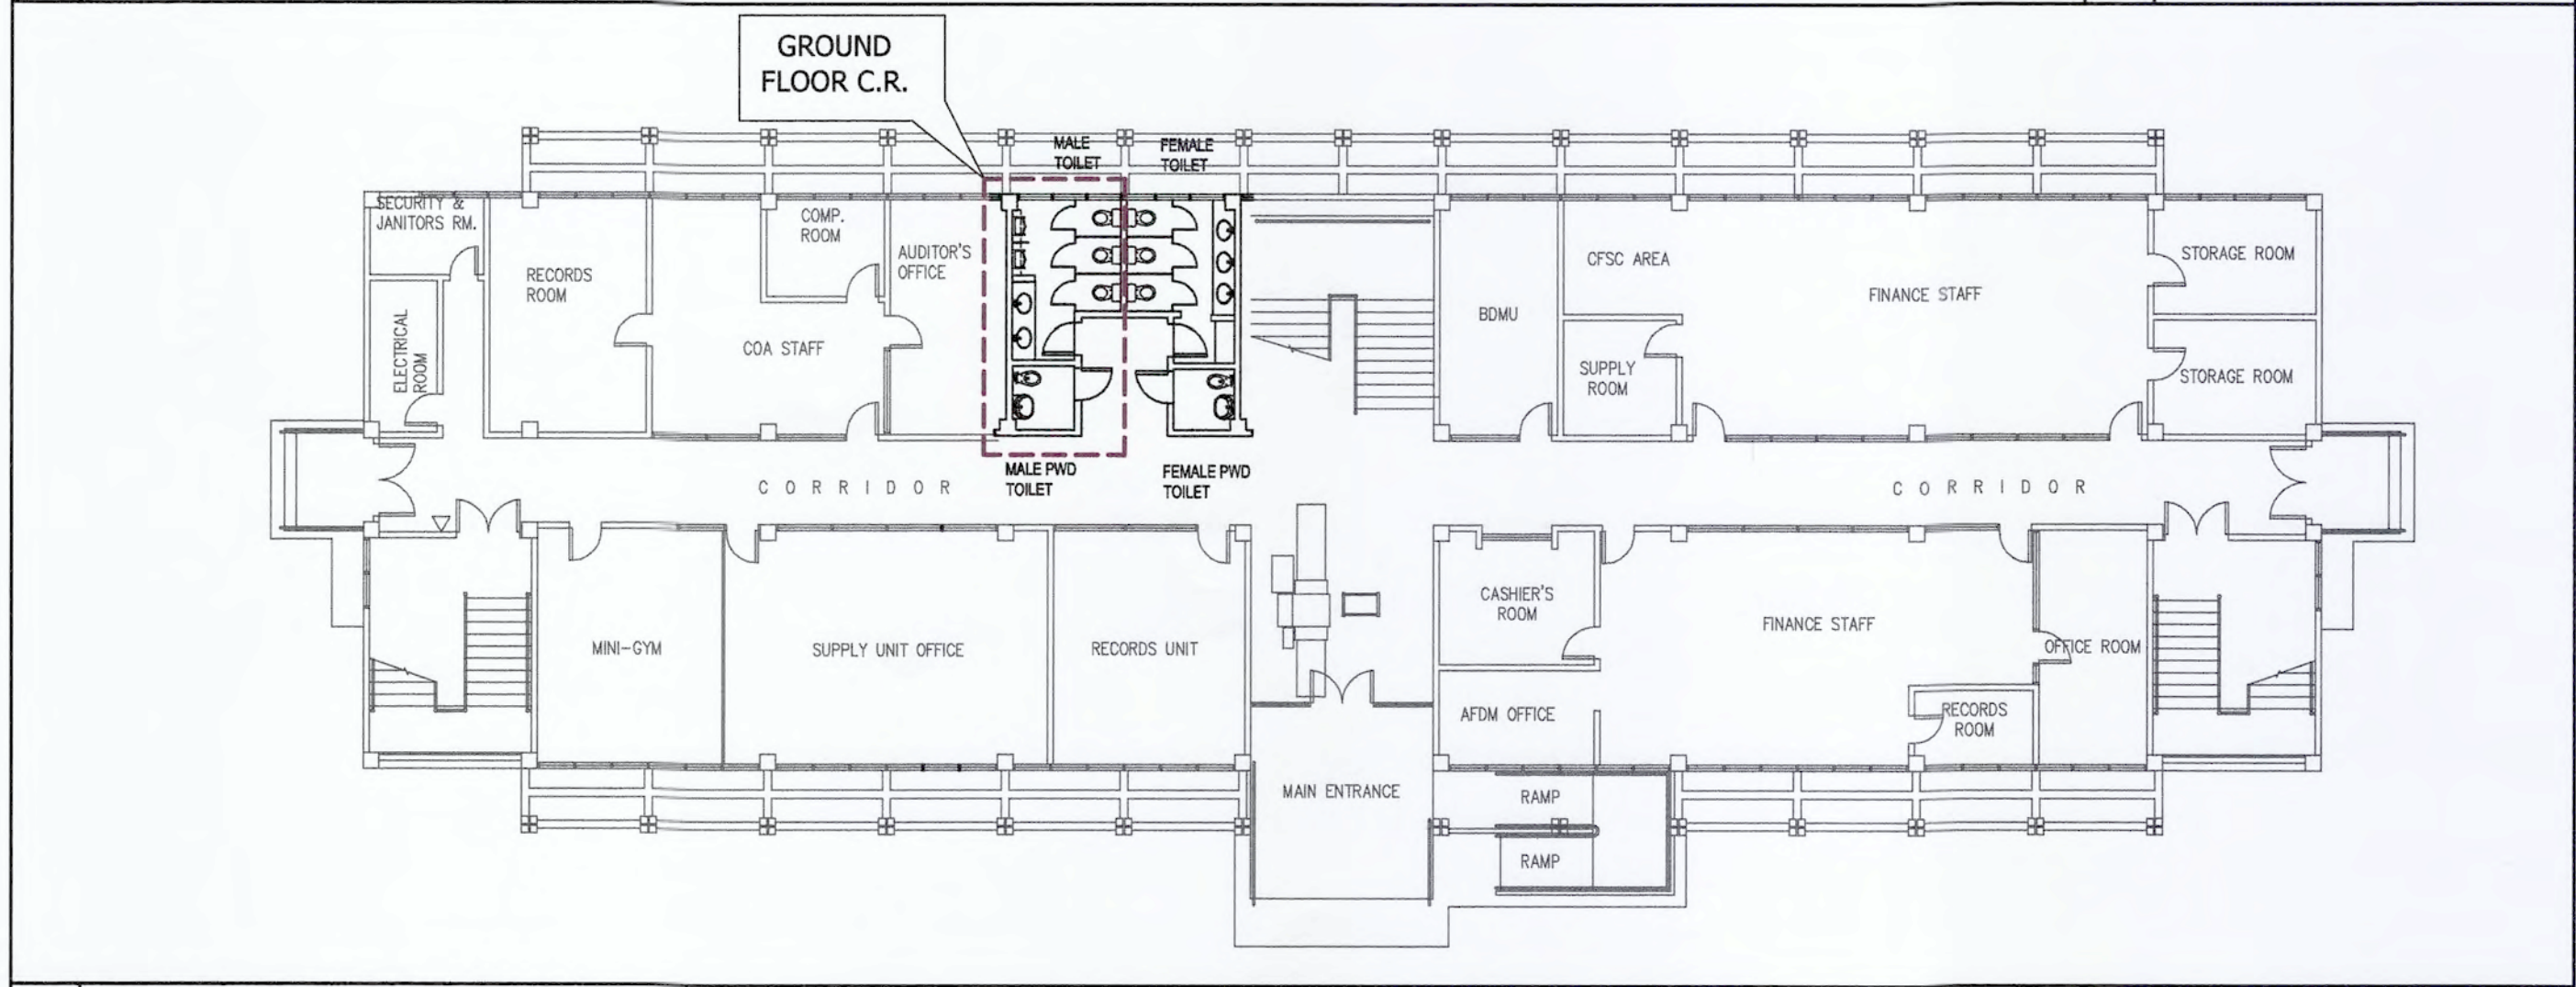
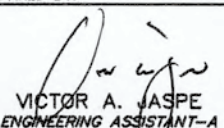
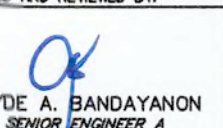
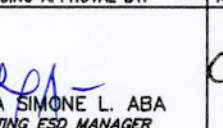


SHT. NO.		DESCRIPTION
01		PORT LOCATION MAP, PROJECT LOCATION PLAN, SHEET CONTENTS, AND GROUND FLOOR PLAN - KEY PLAN
02		MALE AND PWD C.R. AS-BUILT FLOOR PLAN, CROSS SECTION ELEVATION OF MALE AND PWD C.R., AND LONGITUDINAL SECTION ELEVATION OF MALE AND PWD C.R.
03		COA BILLBOARD FRAME DETAIL AND MALE AND PWD C.R. REFLECTED CEILING PLAN
04		MALE AND PWD LIGHTING AND POWER LAYOUT AND ELECTRICAL LEGENDS
05		GROUND FLOOR C.R. PLUMBING LAYOUT, PLUMBING LEGEND, AND ISOMETRIC LAYOUT


01.1	PORT LOCATION MAP SCALE 1:NTS METERS	01.2	PROJECT LOCATION PLAN SCALE 1:6000 METERS	01.3	SHEET CONTENTS SCALE 1:NTS METERS
------	---	------	--	------	--------------------------------------

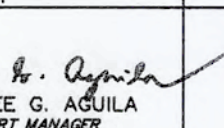


01.4	GROUND FLOOR PLAN - KEY PLAN SCALE 1:175 METERS
------	--

	PREPARED BY:  VICTOR A. JASPE ENGINEERING ASSISTANT-A	CHECKED AND REVIEWED BY:  CLYDE A. BANDAYANON SENIOR ENGINEER A	RECOMMENDING APPROVAL BY:  LARA SIMONE L. ABA ACTING ESD MANAGER	APPROVED BY:  ANALEE G. AGUILA PORT MANAGER	OWNER: ANALEE G. AGUILA PORT MANAGER	PROJECT TITLE: MAINTENANCE OF MALE AND PWD COMFORT ROOM AT GROUND FLOOR, ADMINISTRATIVE BUILDING, SASA PORT	LOCATION: KM. 10, PORT AREA, SASA, DAVAO CITY	REVISIONS DATE REMARKS ADDENDUM NO. PROJECT DATE DRAWN	SHEET NO. OF 01 5 CADD BY: VJ DATE: 07/12/2024 DATE: 07/12/2024 DATE: 07/12/2024
---	---	--	--	---	--	--	--	---	---


CAD FILE: C:\Users\VC\AppData\Local\Temp\AcPublish_7868\2025-SAS--F-00-Re-Repair CR Plumbing floor ties GF Admin Bldg-0325-2026.dwg
 LAST PLOTTED: 3/31/2026 8:39:14 PM
 PLOTSTYLE: monochrome.ctb

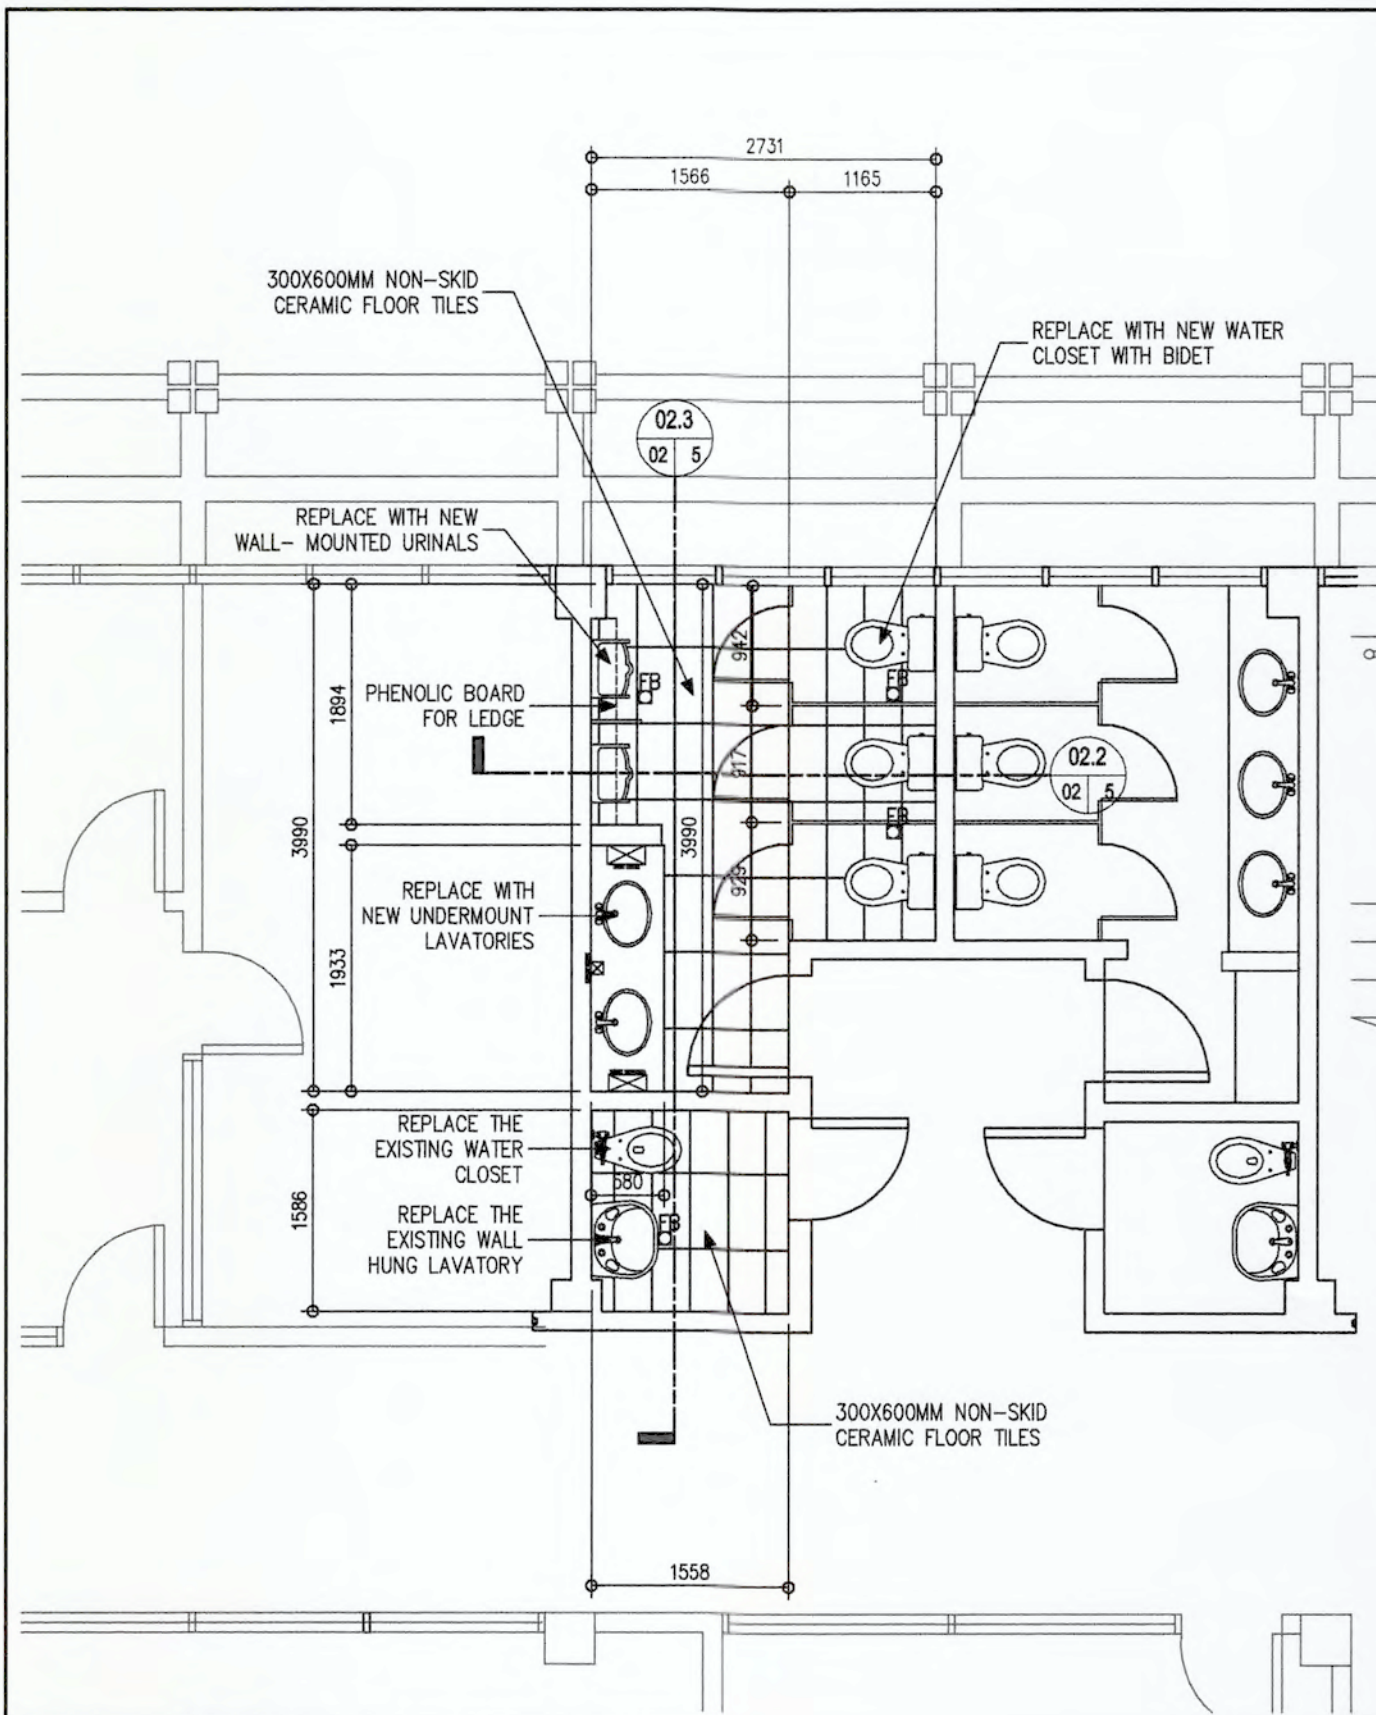

02.1 MALE AND PWD C.R. AS-BUILT FLOOR PLAN
SCALE 1:60 METERS

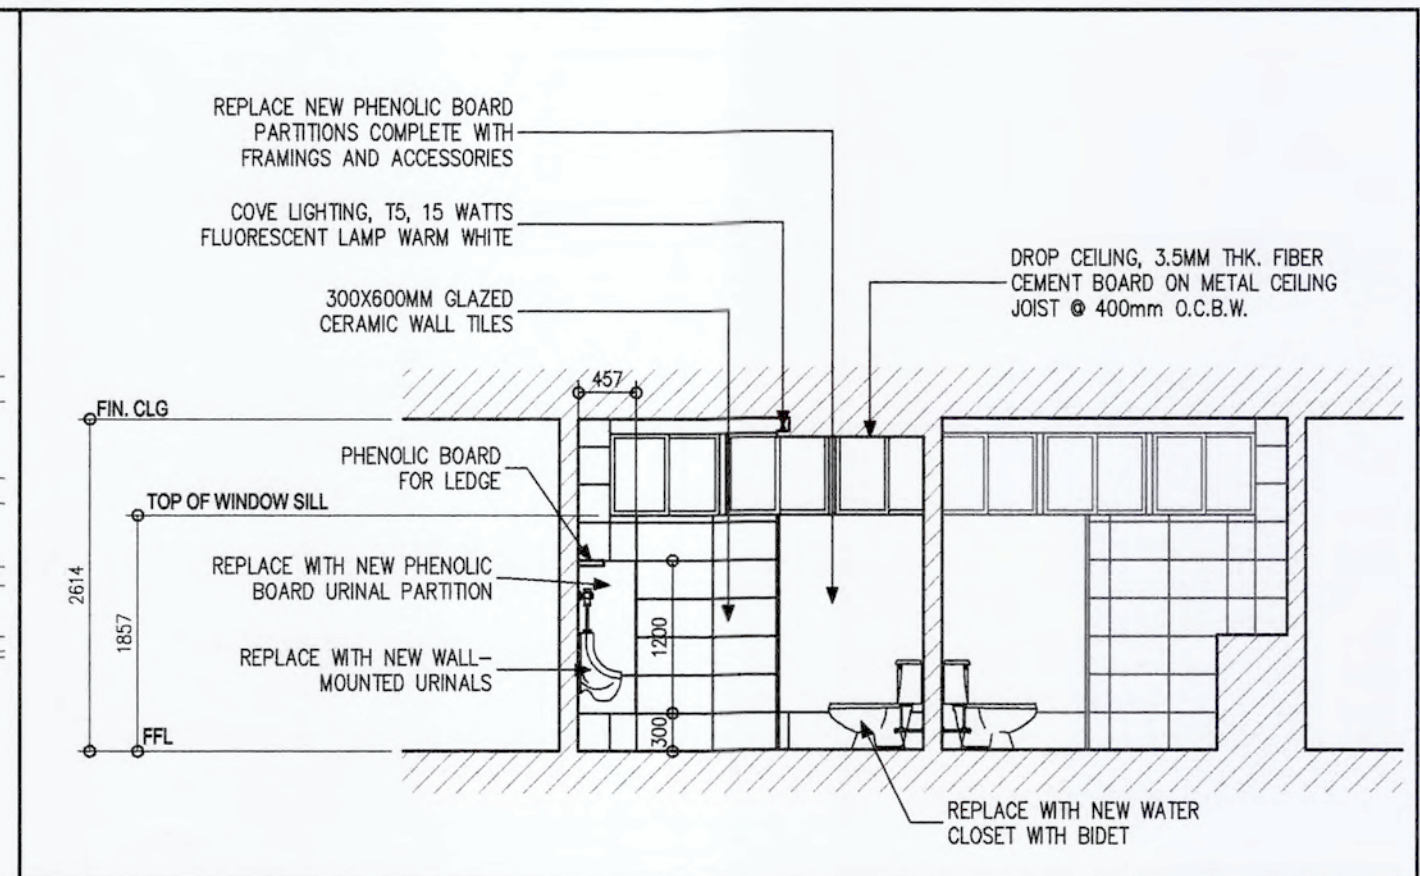


02.2 CROSS SECTION ELEVATION OF MALE C.R.
SCALE 1:60 METERS

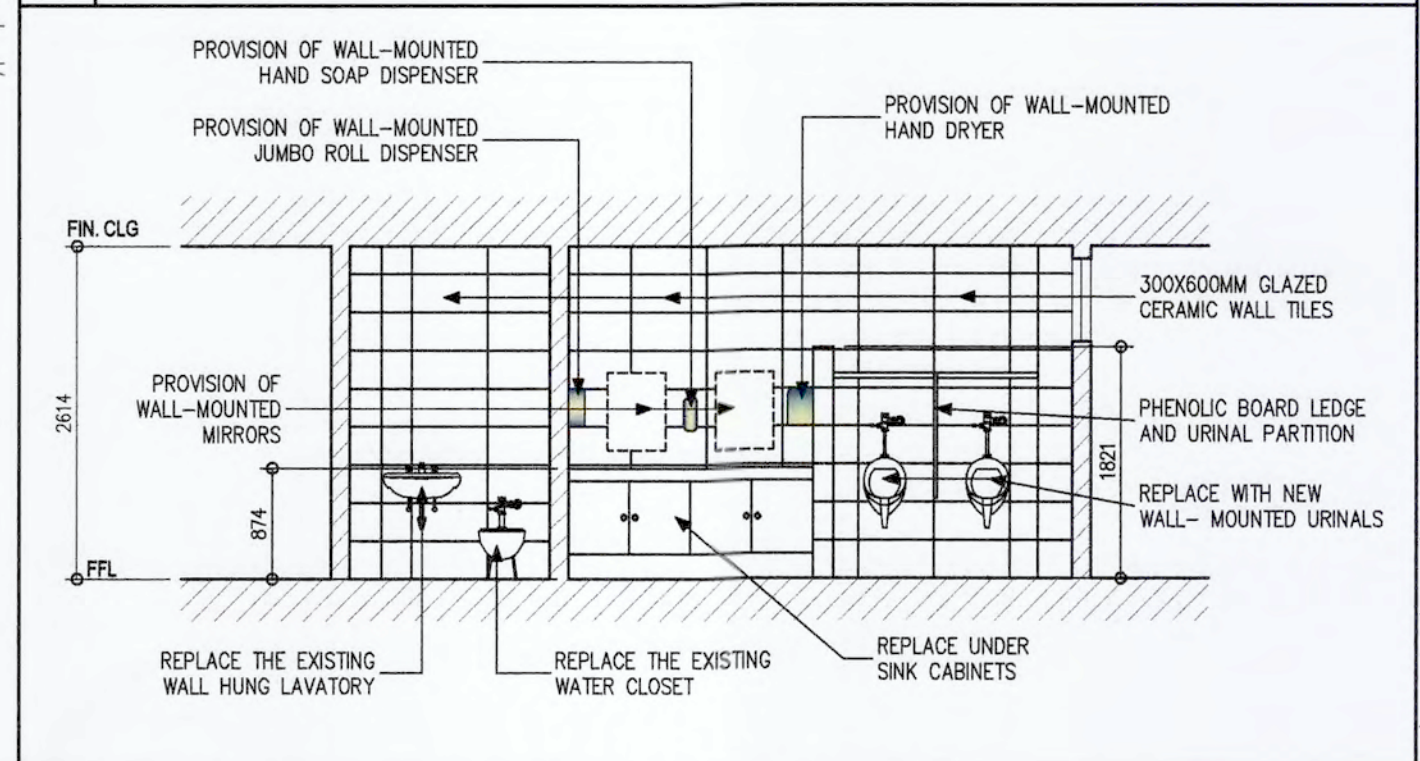


02.3 LONGITUDINAL SECTION ELEVATION @ MALE AND PWD C.R.
SCALE 1:60 METERS

 PHILIPPINE PORTS AUTHORITY PMD DAVAO	PREPARED BY:	CHECKED AND REVIEWED BY:	RECOMMENDING APPROVAL BY:	APPROVED BY:	OWNER:	PROJECT TITLE:	REVISIONS		SHEET NO.	OF
	 VICTOR A. JASPE ENGINEERING ASSISTANT-A	 CLYDE A. BANDAYANON SENIOR ENGINEER A	 LARA SIMONE L. ABA ACTING ESD MANAGER	 ANALEE G. AGUILA PORT MANAGER	ANALEE G. AGUILA PORT MANAGER	MAINTENANCE OF MALE AND PWD COMFORT ROOM AT GROUND FLOOR, ADMINISTRATIVE BUILDING, SASA PORT	DATE	REMARKS	02	5
SHEET CONTENTS:		ADDENDUM								
MALE AND PWD C.R. AS-BUILT FLOOR PLAN, CROSS SECTION ELEVATION OF MALE AND PWD C.R., AND LONGITUDINAL SECTION ELEVATION OF MALE AND PWD C.R.		LOCATION:		NO.		PROJECT:		CADD BY: VAW		
		KM. 10, PORT AREA, SASA, DAVAO CITY				DRAWN BY:		DATE DWN: 07/12/2024		
						DATE		DATE UPD: 3/21/2025		

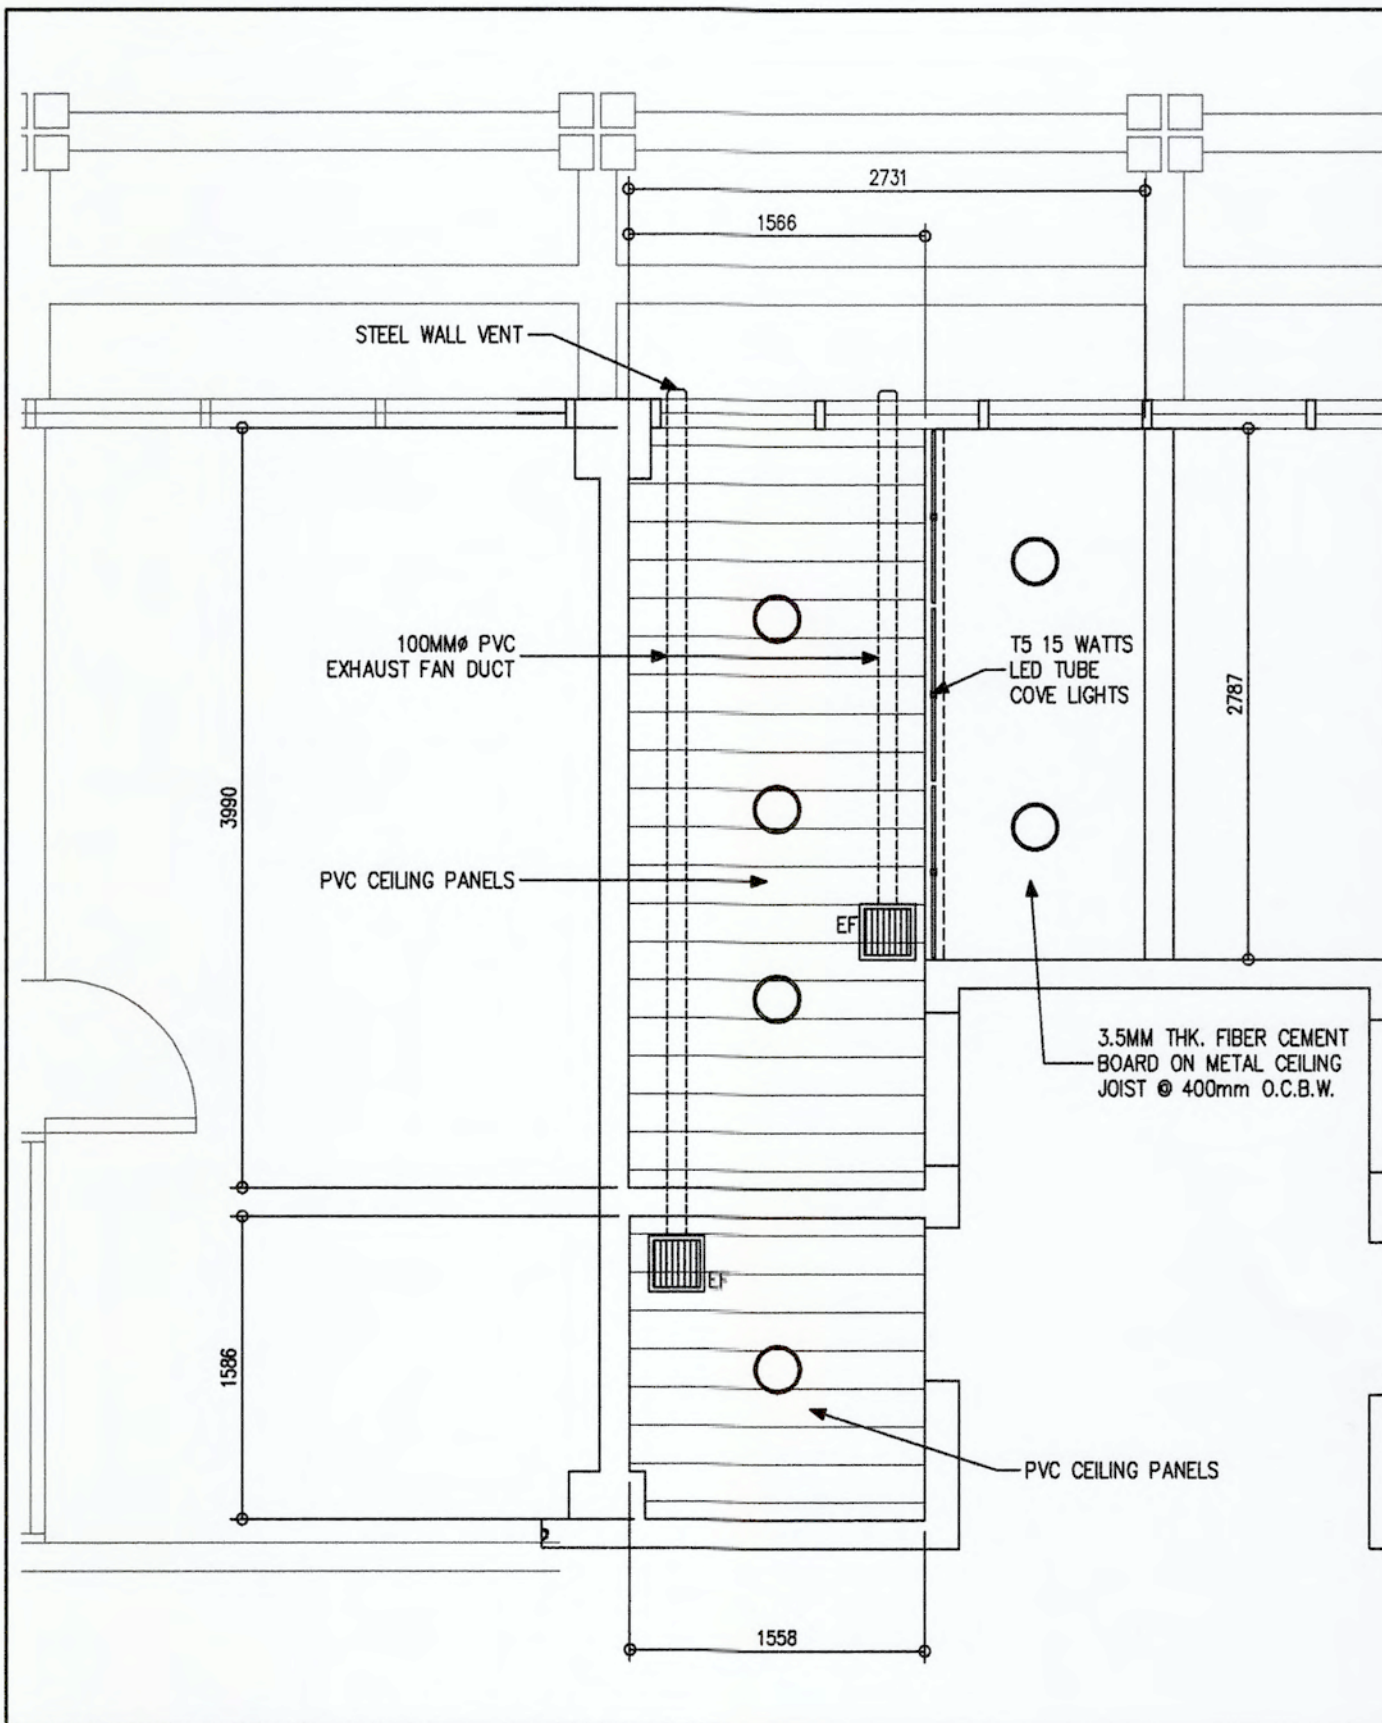


03.1 MALE C.R. REFLECTED CEILING PLAN
SCALE 1:40 METERS

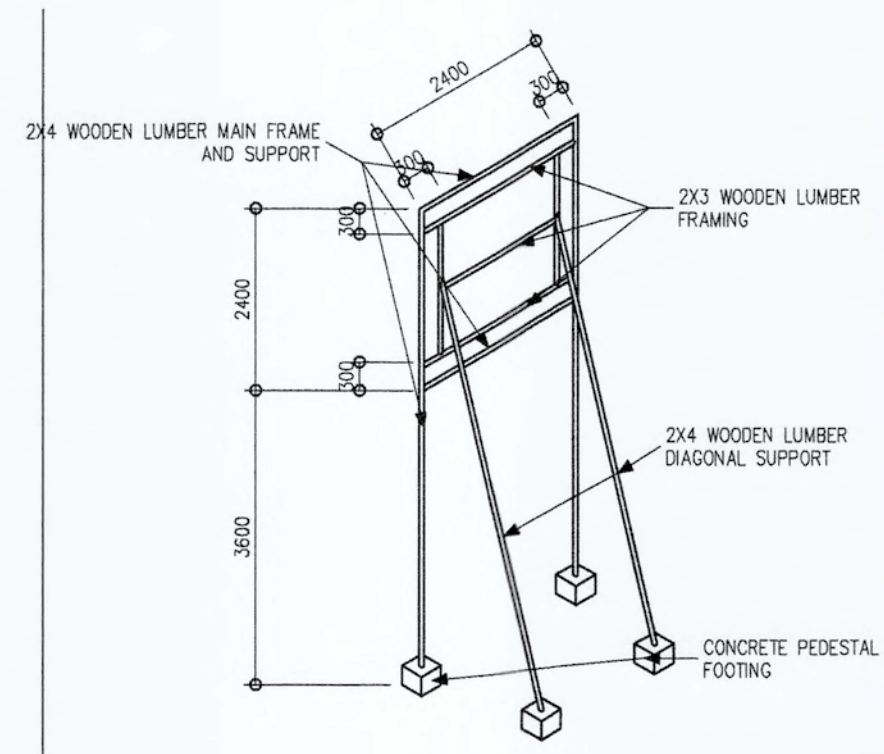

03.2 COA BILLBOARD FRAME DETAIL
SCALE 1:100 METERS

 PHILIPPINE PORTS AUTHORITY PMO DAVAO	PREPARED BY:	CHECKED AND REVIEWED BY:	RECOMMENDING APPROVAL BY:	APPROVED BY:	OWNER:	PROJECT TITLE:	REVISIONS		SHEET NO.	OF
	VICTOR A. VASPE ENGINEERING ASSISTANT-A	CLYDE A. BANDAYANON SENIOR ENGINEER A	LARA SIMONE L. ABA ACTING ESD MANAGER	ANALEE G. AGUILA PORT MANAGER	ANALEE G. AGUILA PORT MANAGER	MAINTENANCE OF MALE AND PWD COMFORT ROOM AT GROUND FLOOR, ADMINISTRATIVE BUILDING, SASA PORT	DATE	REMARKS	03	5
SHEET CONTENTS:						LOCATION:	NO.	ADDENDUM		
COA BILLBOARD FRAME DETAIL AND MALE AND PWD C.R. REFLECTED CEILING PLAN						KM. 10, PORT AREA, SASA, DAVAO CITY	PROJECT			
							DATE			
							DRAWN			
							DATE			
							DATE			

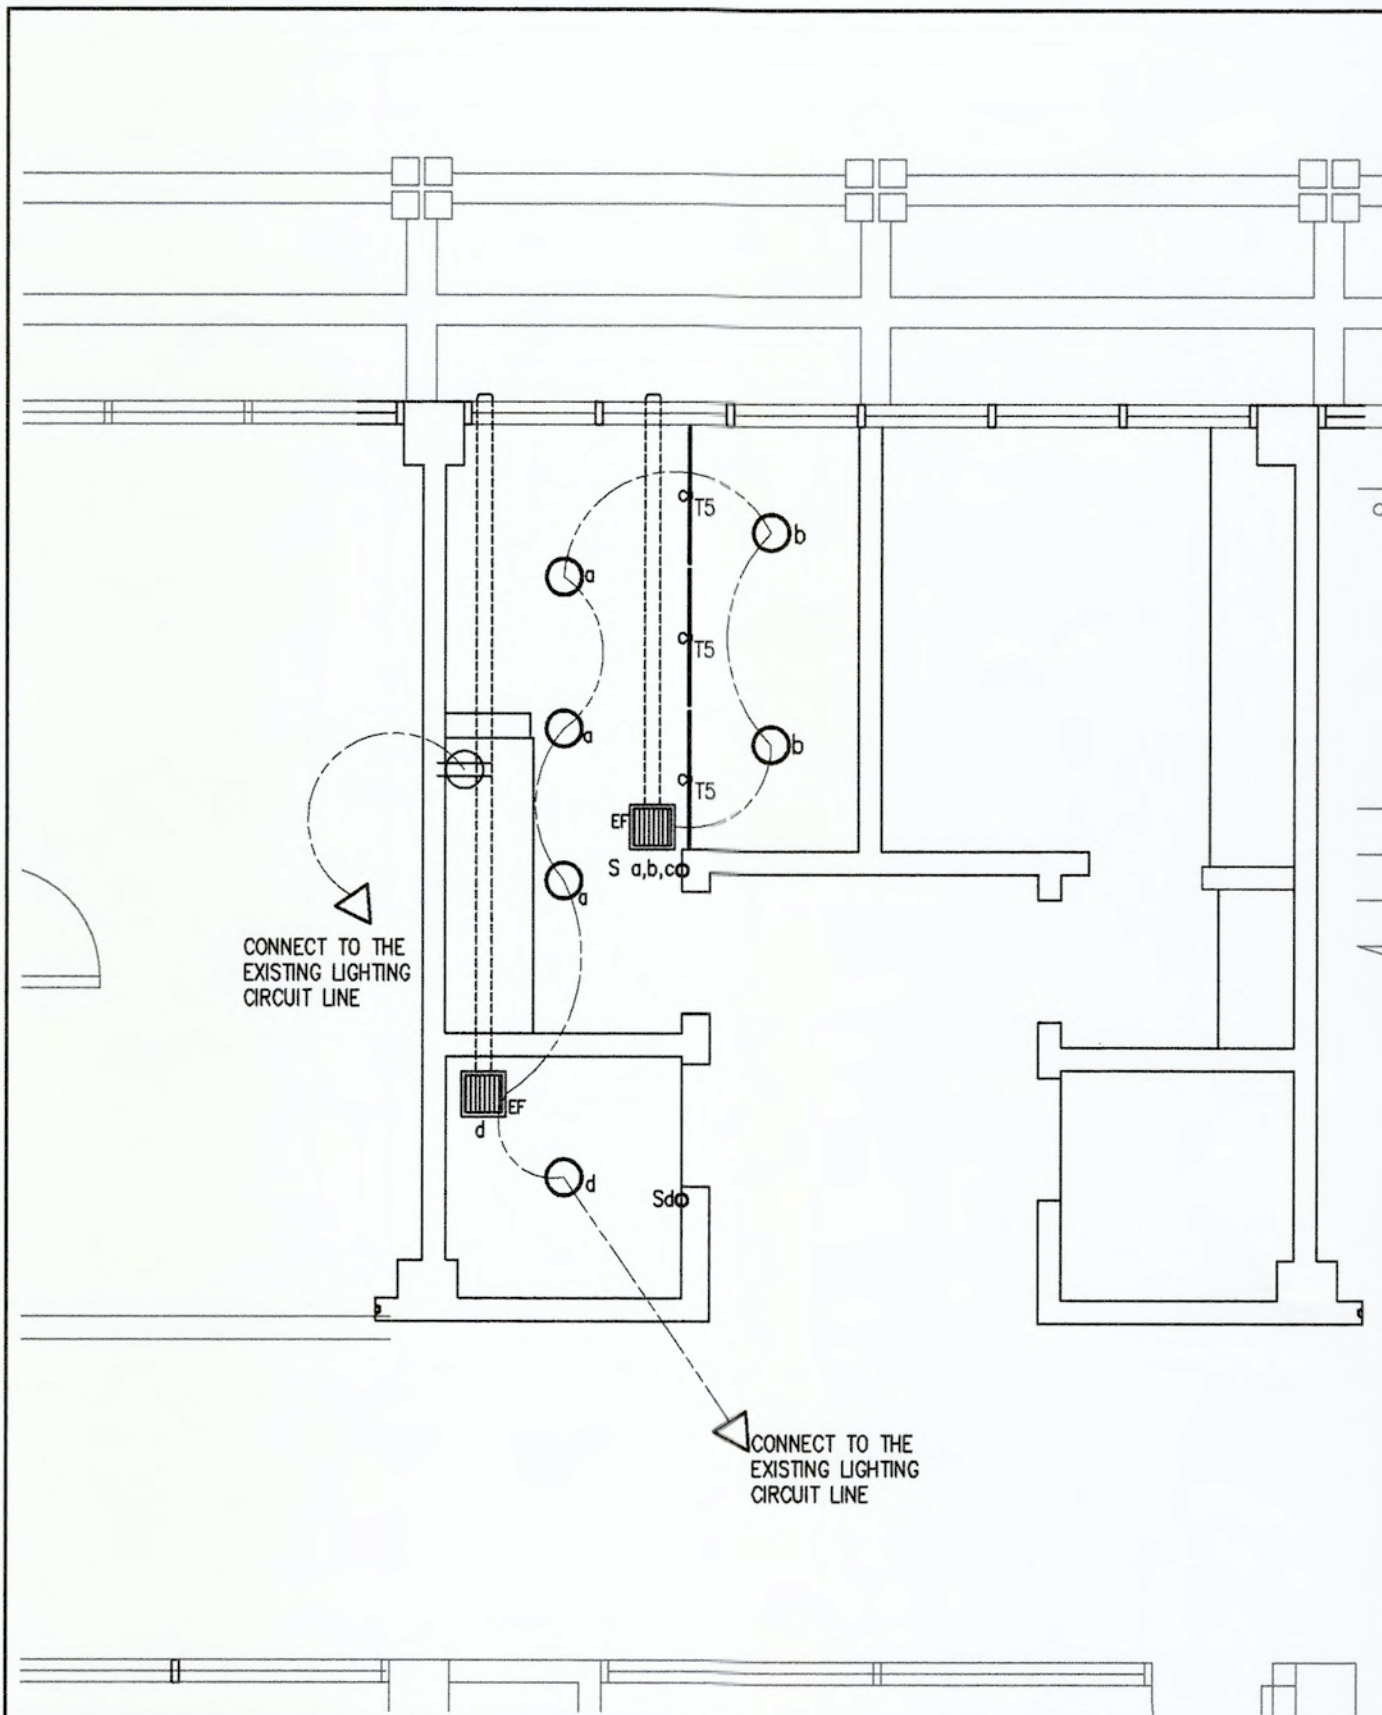

SYMBOL	DESCRIPTION
T5	T5-15 WATTS LED TUBE LIGHTS
○	16 WATTS LED RECESSED DOWNLIGHTS
EF	EXHAUST FAN CEILING MOUNTED
---	CIRCUIT LINE (2-3.5MM ² THW WIRE IN 1/2" Ø FLEXIBLE PVC HOSE)
⊕	DUPLEX FLUSH TYPE CONVENIENCE OUTLET
S a,b,c	LIGHT SWITCH FLUSH TYPE (LETTER DENOTES GANG)

04.1 MALE AND FEMALE C.R. LIGHTING AND POWER LAYOUT

SCALE 1:50 METERS

04.2 ELECTRICAL LEGENDS

SCALE 1: NTS METERS

	PREPARED BY:	CHECKED AND REVIEWED BY:	RECOMMENDING APPROVAL BY:	APPROVED BY:	OWNER:	PROJECT TITLE:	REVISIONS	SHEET NO.	OF
	VICTOR A. JASPE ENGINEERING ASSISTANT-A	CLYDE A. BANDAYANON SENIOR ENGINEER A	LARA SIMONE L. ABA ACTING ESD MANAGER	ANALEE G. AGUILA PORT MANAGER	ANALEE G. AGUILA PORT MANAGER	MAINTENANCE OF MALE AND PWD COMFORT ROOM AT GROUND FLOOR, ADMINISTRATIVE BUILDING, SASA PORT	DATE REMARKS	04	5
SHEET CONTENTS:							ADDENDUM		
MALE AND PWD LIGHTING AND POWER LAYOUT AND ELECTRICAL LEGENDS							NO.		
LOCATION:							PROJECT		
KM. 10, PORT AREA, SASA, DAVAO CITY							DATE		
							DRAWN		
							DATE UPD		
							3/31/2028		

DRAWING AND SPECIFICATION DULY SIGNED, STAMPED OR SEALED AS INSTRUMENTS OF SERVICE ARE THE PROPERTY OF THE ARCHITECT, WHETHER THE OBJECTS FOR WHICH THEY ARE MADE IS EXECUTED OR NOT. IT SHALL BE UNLAWFUL FOR ANY PERSON WITHOUT THE WRITTEN CONSENT OF THE ARCHITECT OF THE SAID DOCUMENTS TO DUPLICATE OR TO MAKE COPIES OF THE SAID DOCUMENTS FOR USE IN REPETITION OF AND FOR PROJECTS OR BUILDINGS WHETHER PARTLY OR WHOLELY EXECUTED. R.A.545 SECTION 25(4).


CAD FILE: C:\Users\VC\AppData\Local\Temp\AcPublish_7868\2025-SAS--F-00-Re-Repair CR Plumbing floor tiles GF Admin Bldg-0325-2026.dwg
 LAST PLOTTED: 3/31/2026 3:39:18 PM
 PLOTSTYLE: monochrome.ctb

LEGEND:

- SV - STACK VENT
- VS - VENT STACK
- LAV - LAVATORY
- WC - WATER CLOSET
- UR - URINAL
- FD - FLOOR DRAIN
- SS - SLOP SINK
- FCO - FLOOR CLEAN OUT
- 2" Ø PVC PIPE, S-1000
- 3" Ø PVC PIPE, S-1000
- 4" Ø PVC PIPE, S-1000
- - WATERLINE

NOTES:

- LAVATORY, URINAL, AND SLOP SINK SHALL USE 50MMØ PVC PIPE
- WATER CLOSET SHALL USE 100MMØ PVC PIPE
- VENT PIPE SHALL USE 50MMØ PVC PIPE
- SV SHALL USED 75MMØ PVC PIPE

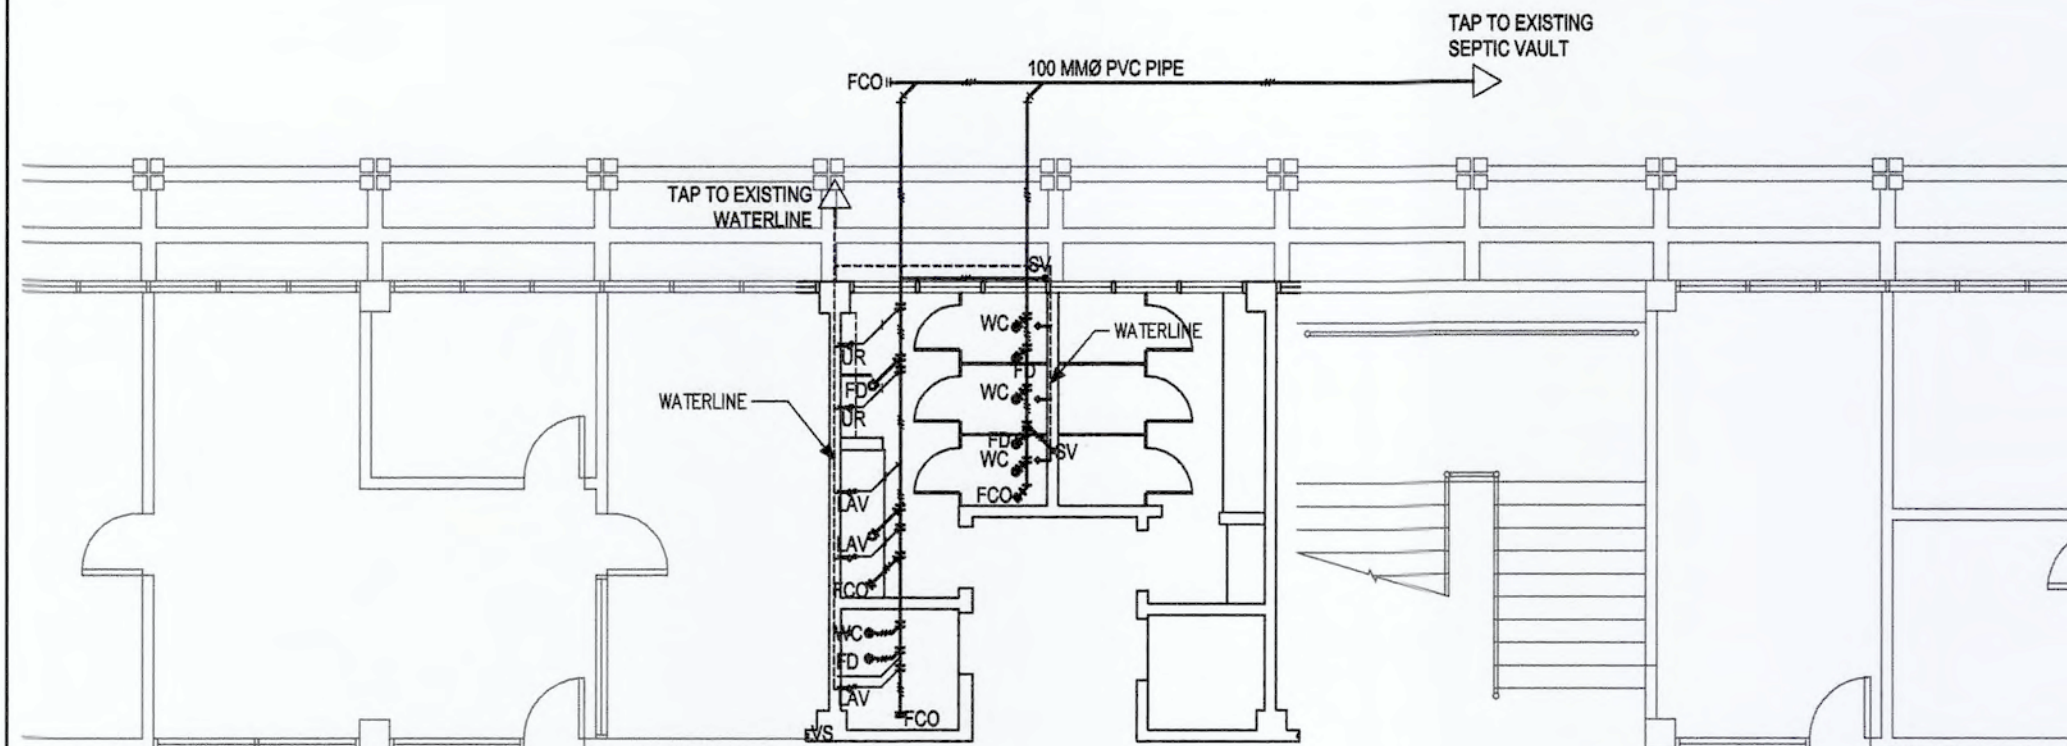


05.1 PLUMBING LEGEND AND NOTES

SCALE 1: NTS METERS

05.2 GROUND FLOOR C.R. PLUMBING LAYOUT

SCALE 1: 100 METERS

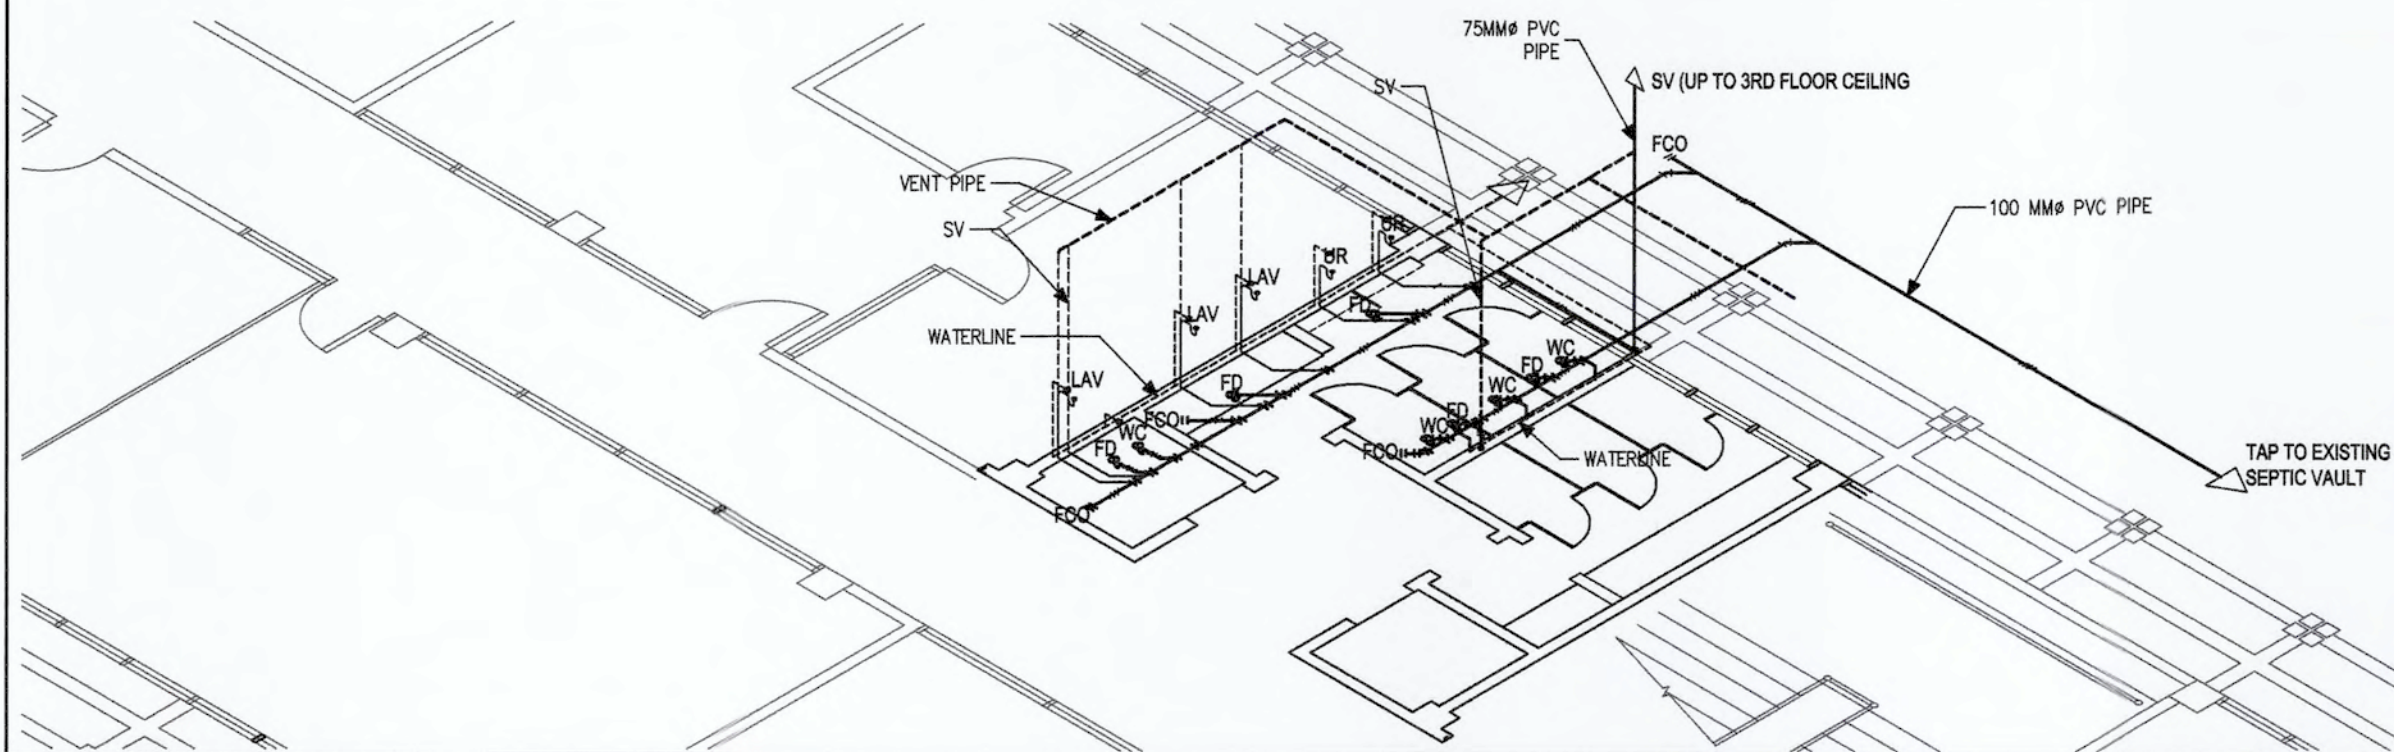

05.3 ISOMETRIC LAYOUT

SCALE 1: 75 METERS



PREPARED BY:
[Signature]
VICTOR A. JASPE
ENGINEERING ASSISTANT-A

CHECKED AND REVIEWED BY:
[Signature]
CLYDE A. BANDAYANON
SENIOR ENGINEER A

RECOMMENDING APPROVAL BY:
[Signature]
LARA SIMONE L. ABA
ACTING ESD MANAGER

APPROVED BY:
[Signature]
ANALEE G. AGUILA
PORT MANAGER

OWNER:
ANALEE G. AGUILA
PORT MANAGER

SHEET CONTENTS:
PLUMBING LEGEND AND NOTES,
GROUND FLOOR C.R. PLUMBING
LAYOUT, AND ISOMETRIC LAYOUT

PROJECT TITLE:
MAINTENANCE OF MALE AND PWD
COMFORT ROOM AT GROUND FLOOR,
ADMINISTRATIVE BUILDING, SASA PORT

LOCATION:
KM. 10, PORT AREA, SASA, DAVAO CITY

DATE	REVISIONS	REMARKS

SHEET NO. **05** OF **5**

DATE DRAWN: 07/12/2024
DATE UPDASH: 3/31/2026