


THIS SITE

REPAIR OF ELECTRICAL AND PLUMBING FITTINGS/FIXTURES AT PPA ADMIN AND POSS BUILDING, PORT OF ZAMBOANGA, ZAMBOANGA CITY

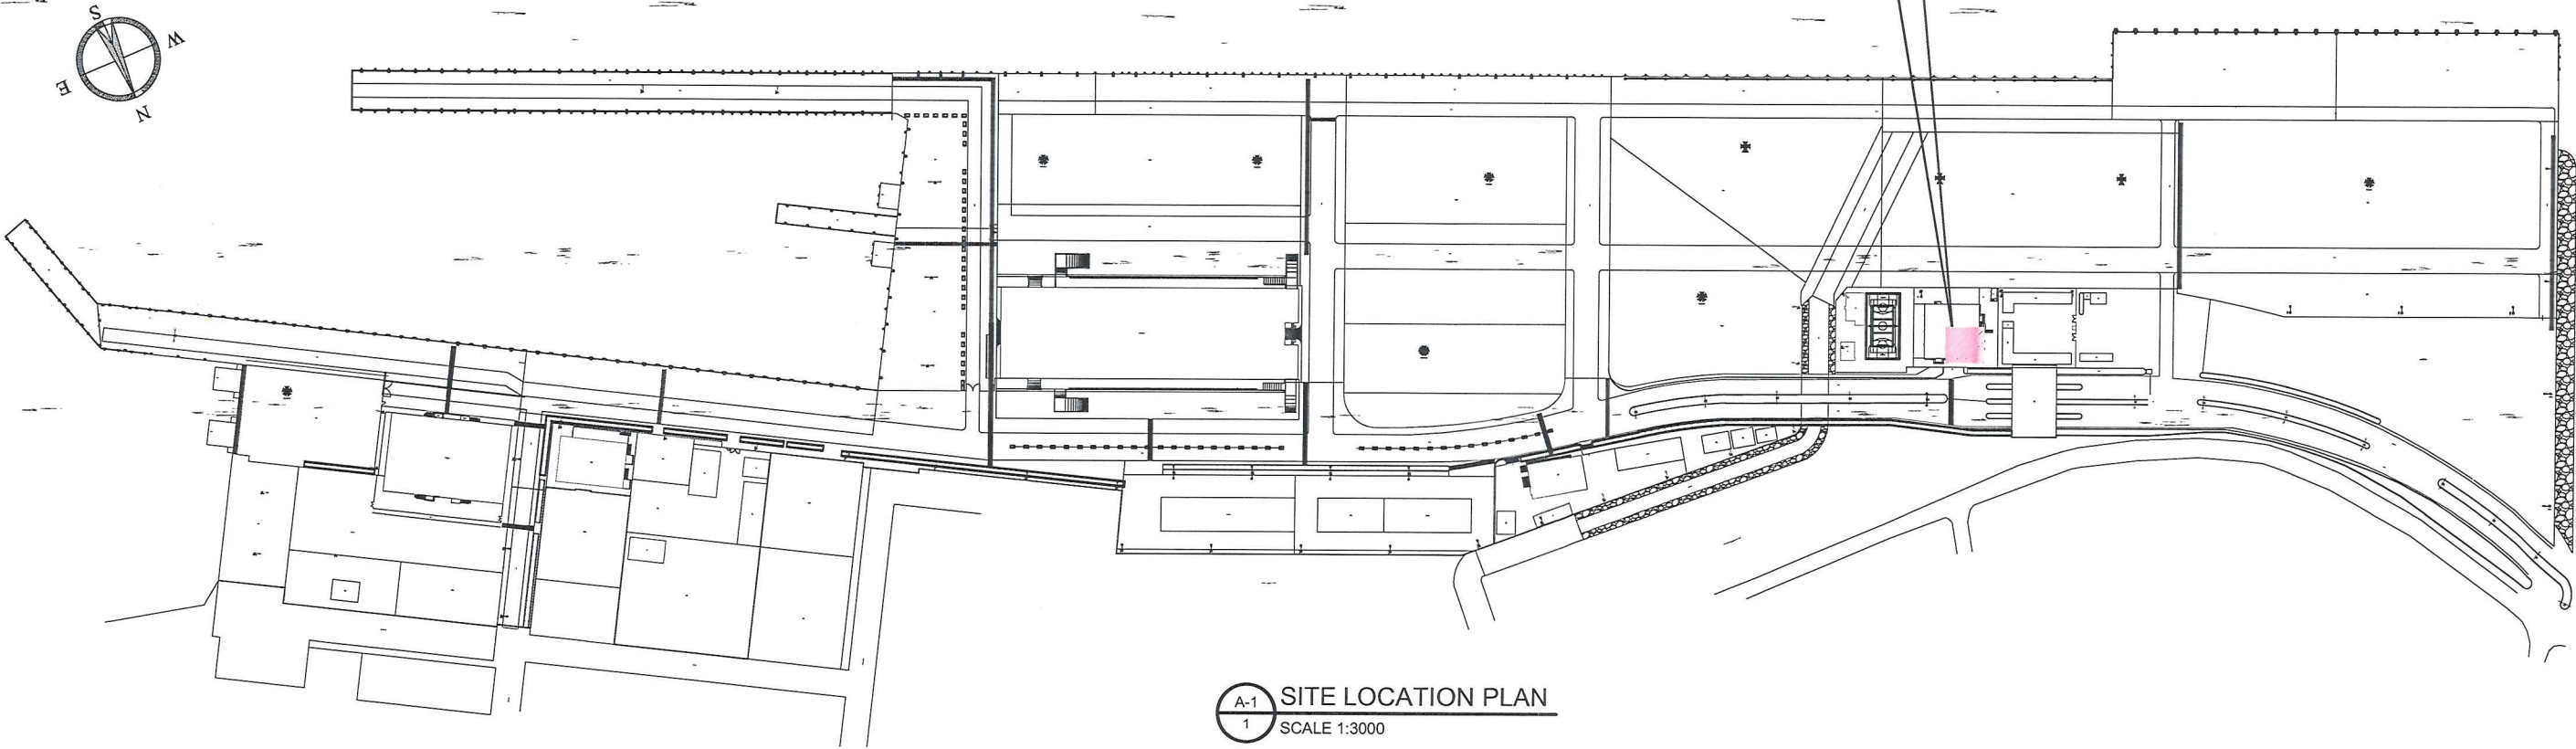

A-1


1

SITE LOCATION PLAN

SCALE 1:3000

REF: C:\MSERS\HAF\DESIGN\PORT\PPA\WORKS\POSS\AS-MAU CONDENSED

PHILIPPINE PORTS AUTHORITY PMO ZAMBOANGA SEPTEMBER 2024	TITLE: REPAIR OF ELECTRICAL AND PLUMBING FITTINGS/FIXTURES					SHEET CONTENT:		SHEET	
	LOCATION: PPA ADMIN AND POSS BUILDING, PORT OF ZAMBOANGA, ZAMBOANGA CITY					AS-SHOWN		SET	NO.
	PREPARED BY: SHARIFA SHEEYIN T. ARAP	CHECKED BY: EUGENIO B. GALVEZ	REVIEWED BY: MAHSON S. UKKOH	RECOMMENDED BY: TASHIMA H. ASID-MAADIL	APPROVED BY: ARCIDI S. JUMAANI				1
	SENIOR ENGINEER B (COS)	SUPERVISING ENGINEER A	ACTING PRINCIPAL ENGINEER A	ESD MANAGER	PORT MANAGER				3

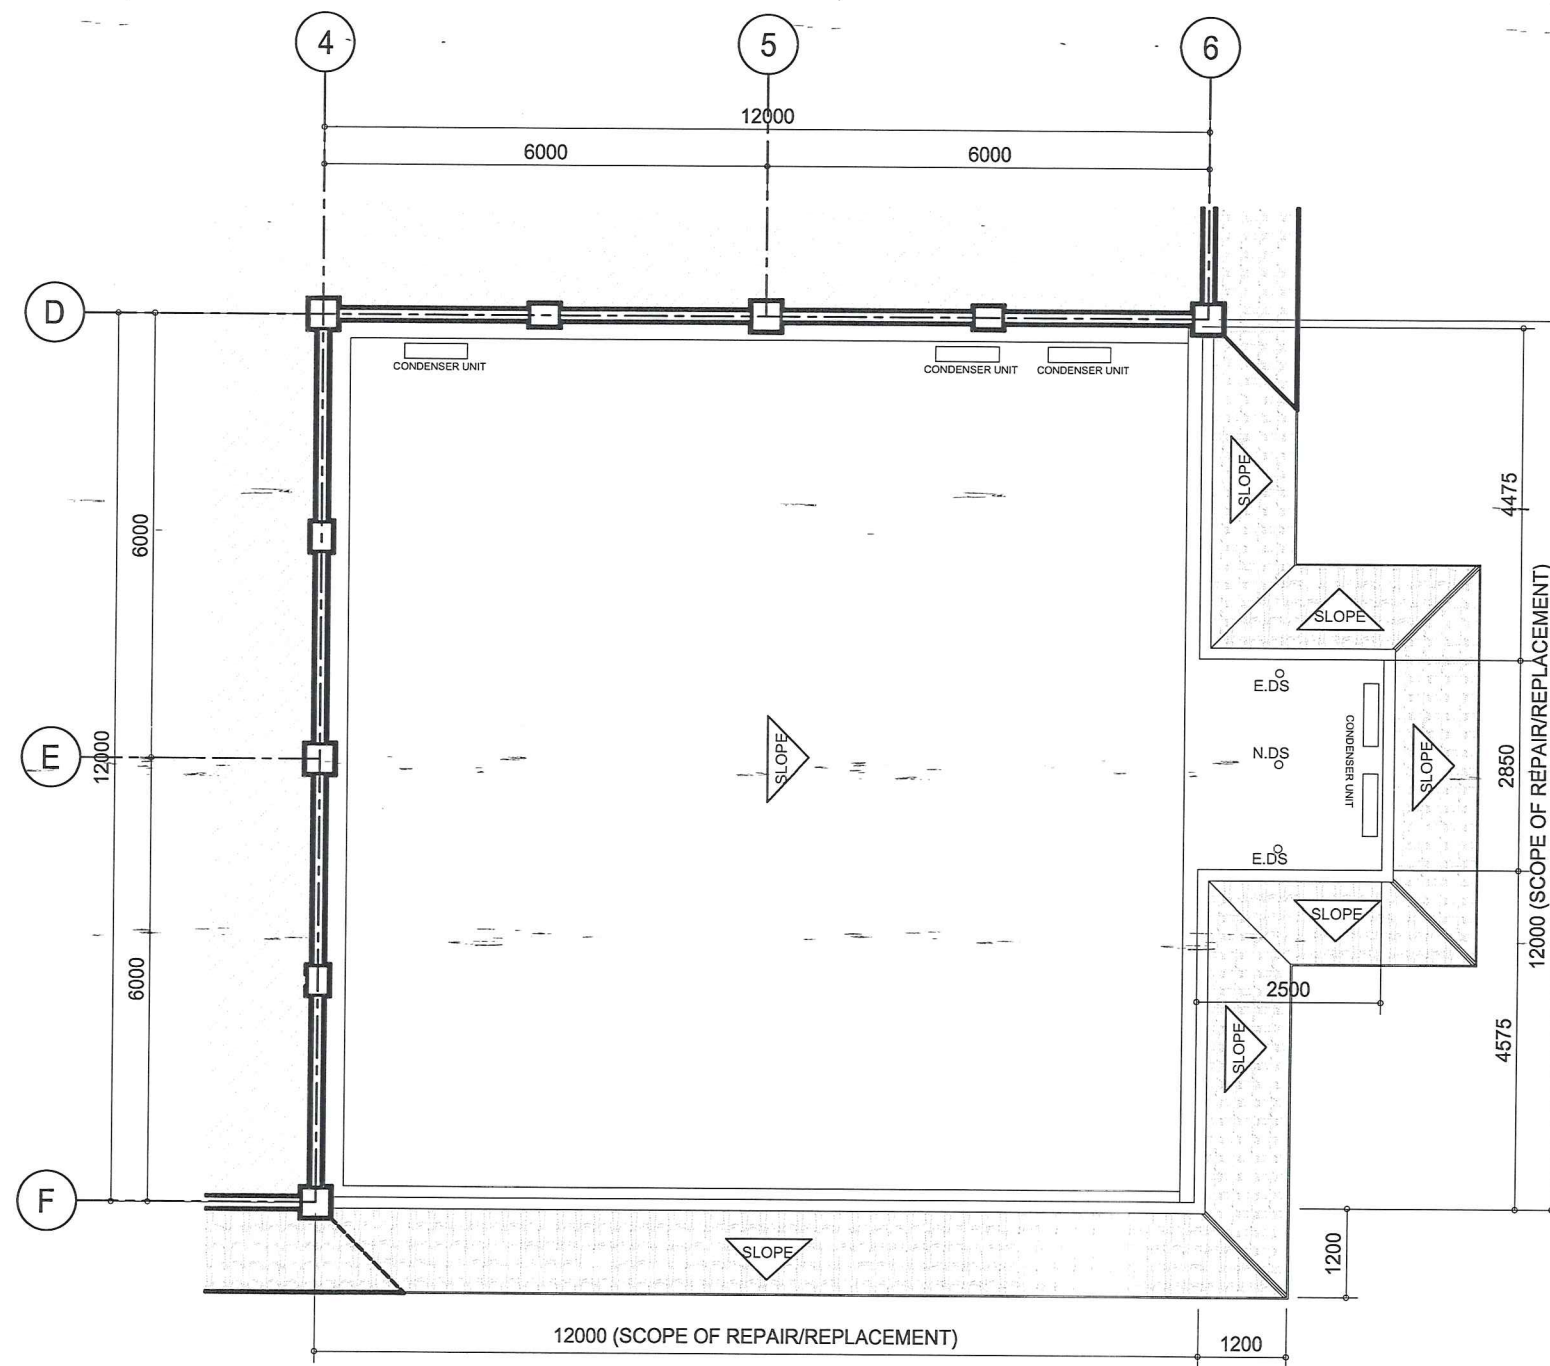


A-1
2
EXISTING PLAN
SCALE 1:100


REF: C:\MSR\SHARIFA\DESIGN\PPA-WORKS\SSA\CU CONDENSER




TITLE: REPAIR OF ELECTRICAL AND PLUMBING FITTINGS/FIXTURES					SHEET CONTENT:		SHEET		
LOCATION: PPA ADMIN AND POSS BUILDING, PORT OF ZAMBOANGA, ZAMBOANGA CITY					AS-SHOWN		SET	NO.	
PREPARED BY: SHARIFA SHEEYIN T. ARAP SENIOR ENGINEER B (COS)		CHECKED BY: EUGENIO B. GALVEZ SUPERVISING ENGINEER A		REVIEWED BY: MARSON S. UKKOH ACTING PRINCIPAL ENGINEER A				2	
				RECOMMENDED BY: TASHMA H. ASID-MAADIL ESD MANAGER			APPROVED BY: ARCIDI S. JUMAANI PORT MANAGER		

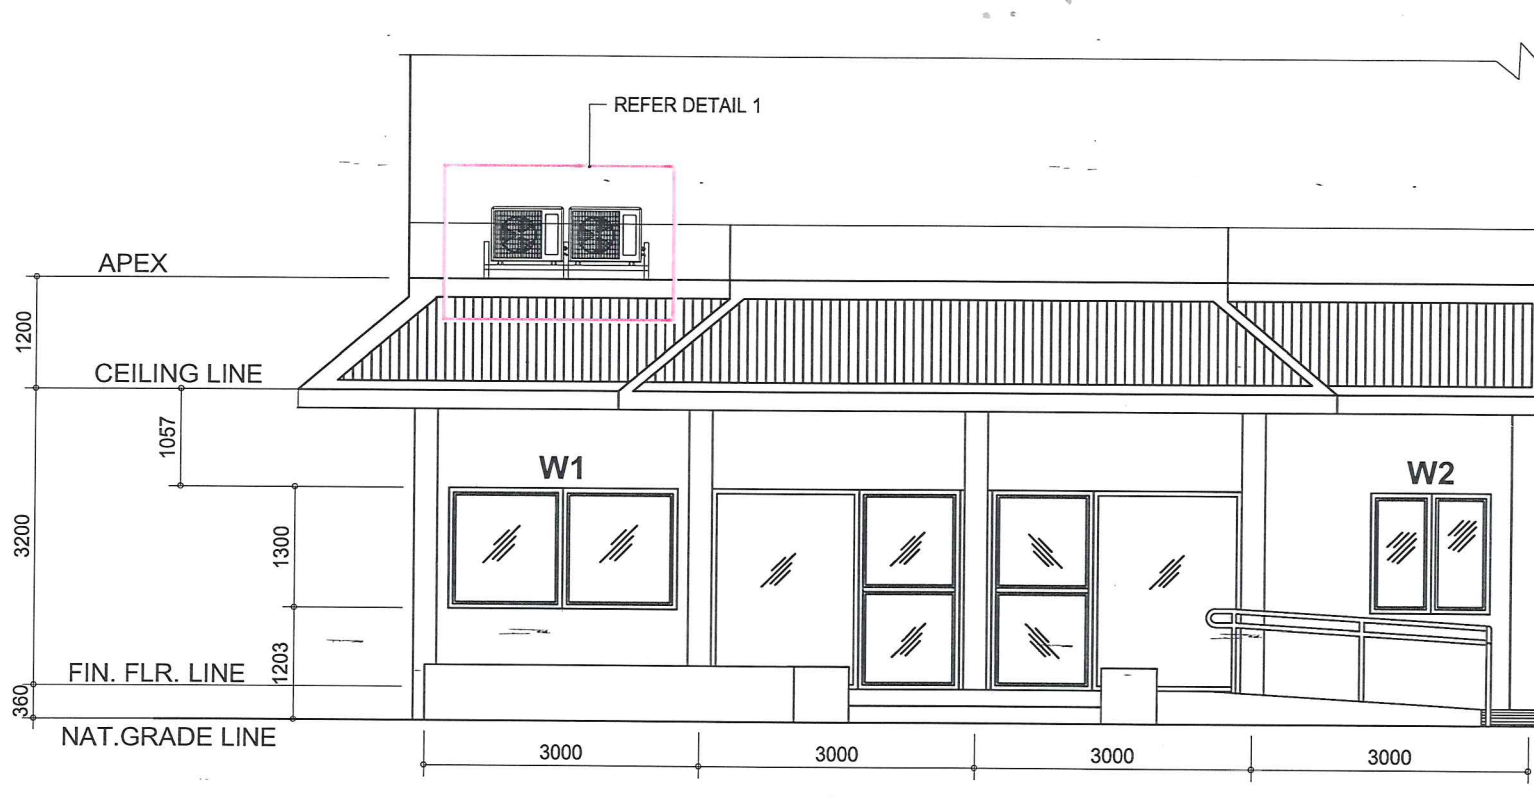


FRONT ELEVATION
SCALE 1:125

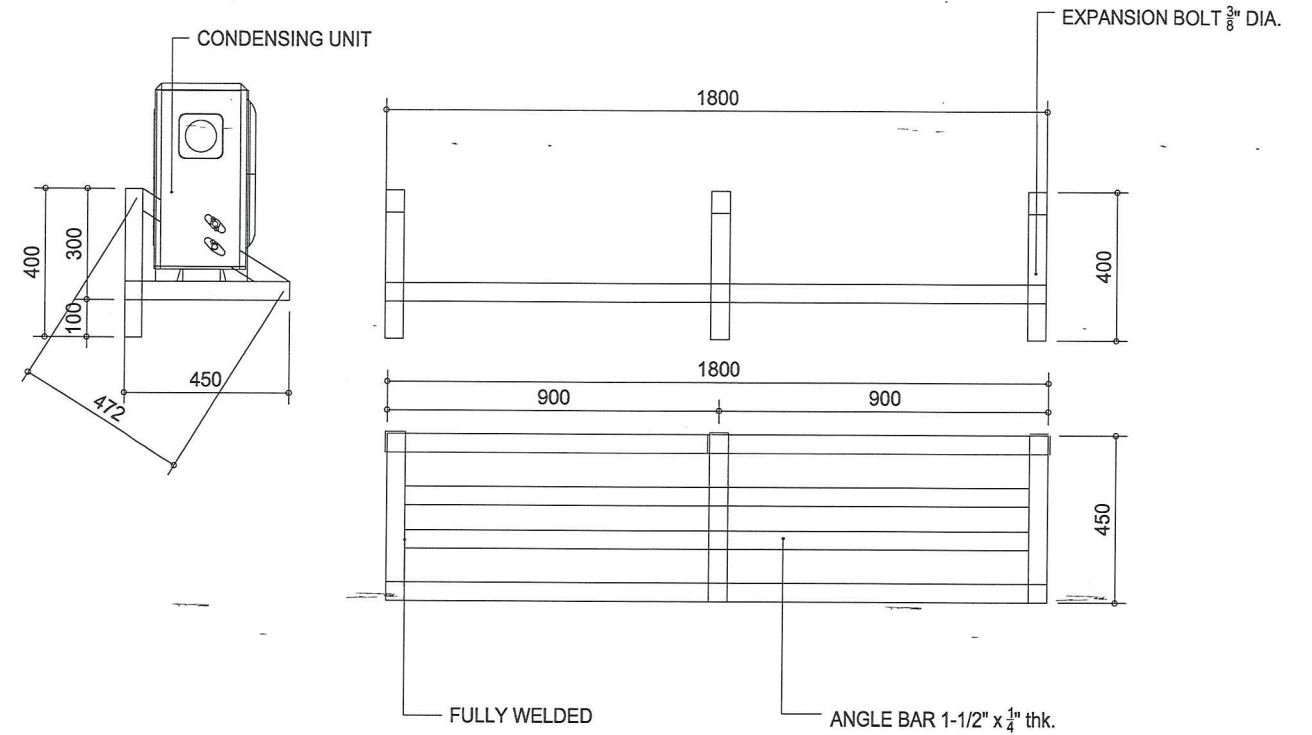

PROPOSED DETAIL PLAN 1
SCALE 1:20

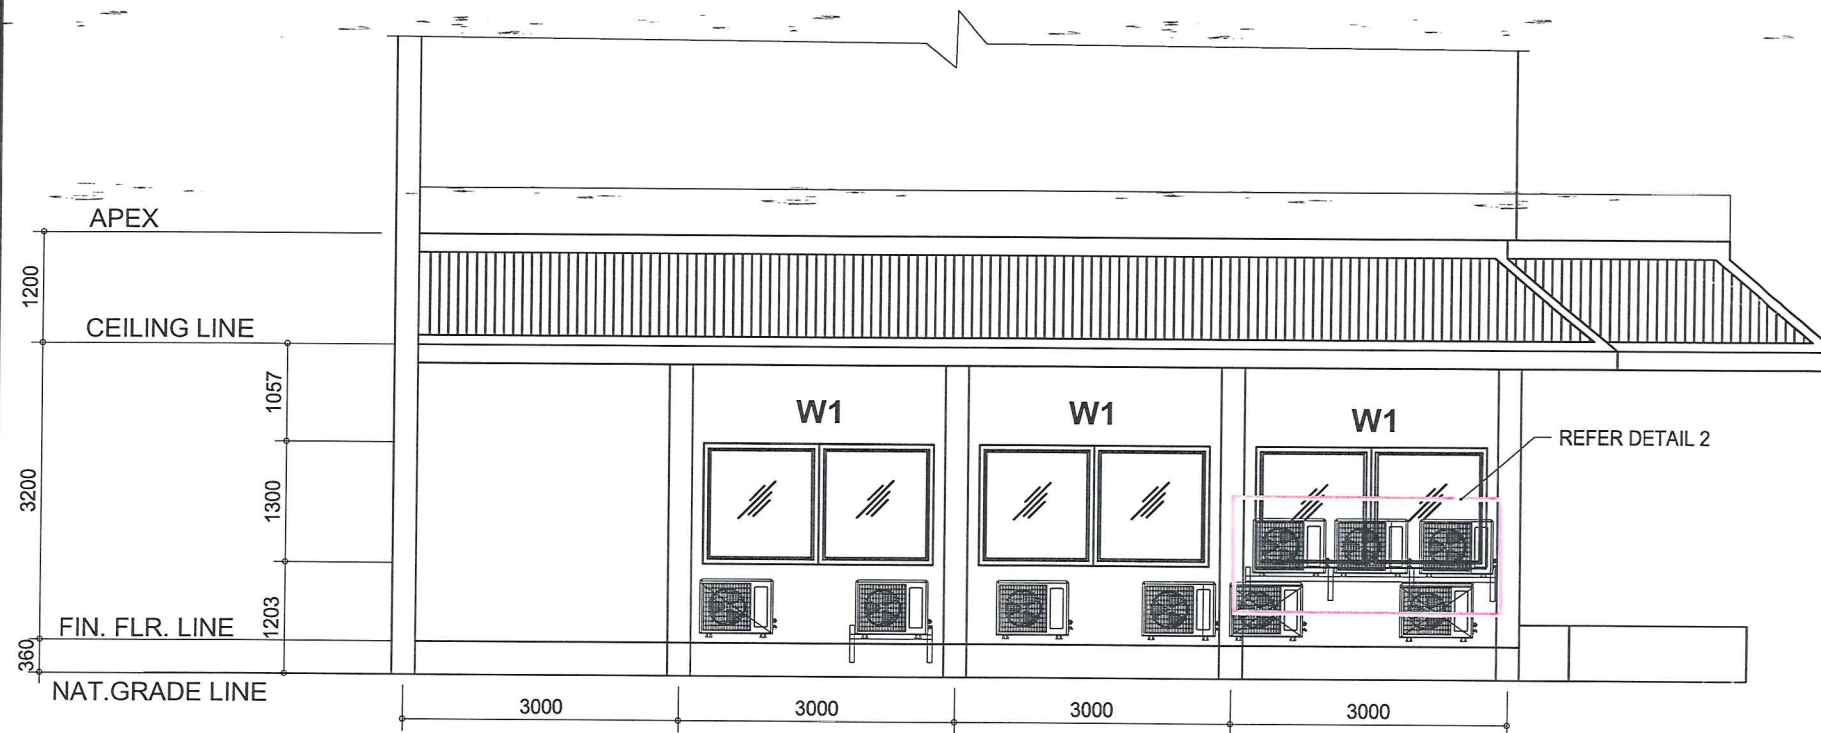

LEFT ELEVATION
SCALE 1:125

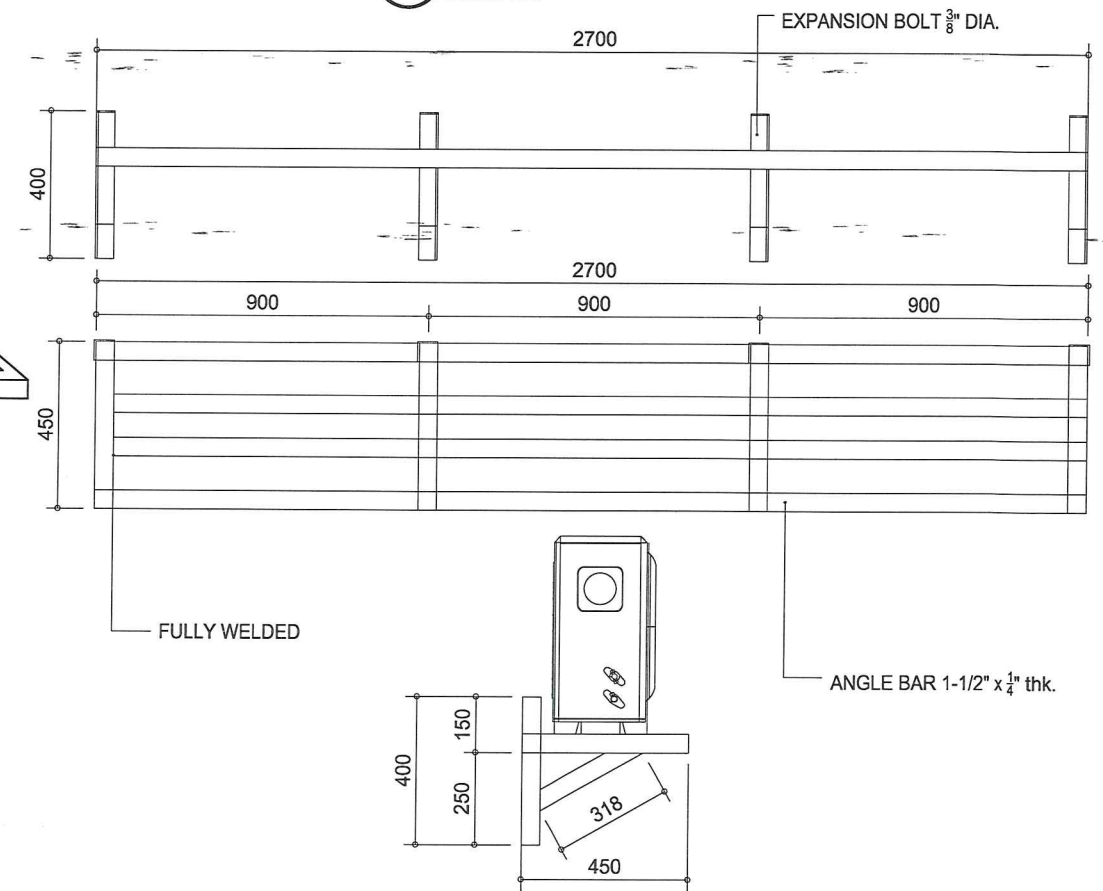

PROPOSED DETAIL PLAN 2
SCALE 1:20

REF: C:\USERS\SHARIFA\DESKTOP\PPA-WORKS\SSMAU CONDENSER



TITLE: REPAIR OF ELECTRICAL AND PLUMBING FIXTURES					SHEET CONTENT: AS-SHOWN		SHEET	
LOCATION: PPA ADMIN AND POSS BUILDING, PORT OF ZAMBOANGA, ZAMBOANGA CITY							SET	NO.
PREPARED BY: SHARIFA SHEEYIN T. ARAP SENIOR ENGINEER B (COS)		CHECKED BY: EUGENIO B. GALVEZ SUPERVISING ENGINEER A	REVIEWED BY: MAHSON S. UKKOH ACTING PRINCIPAL ENGINEER A	RECOMMENDED BY: TASHMA H. ASID-MAADIL ESD MANAGER			APPROVED BY: ARCIDI S. JUMAANI PORT MANAGER	